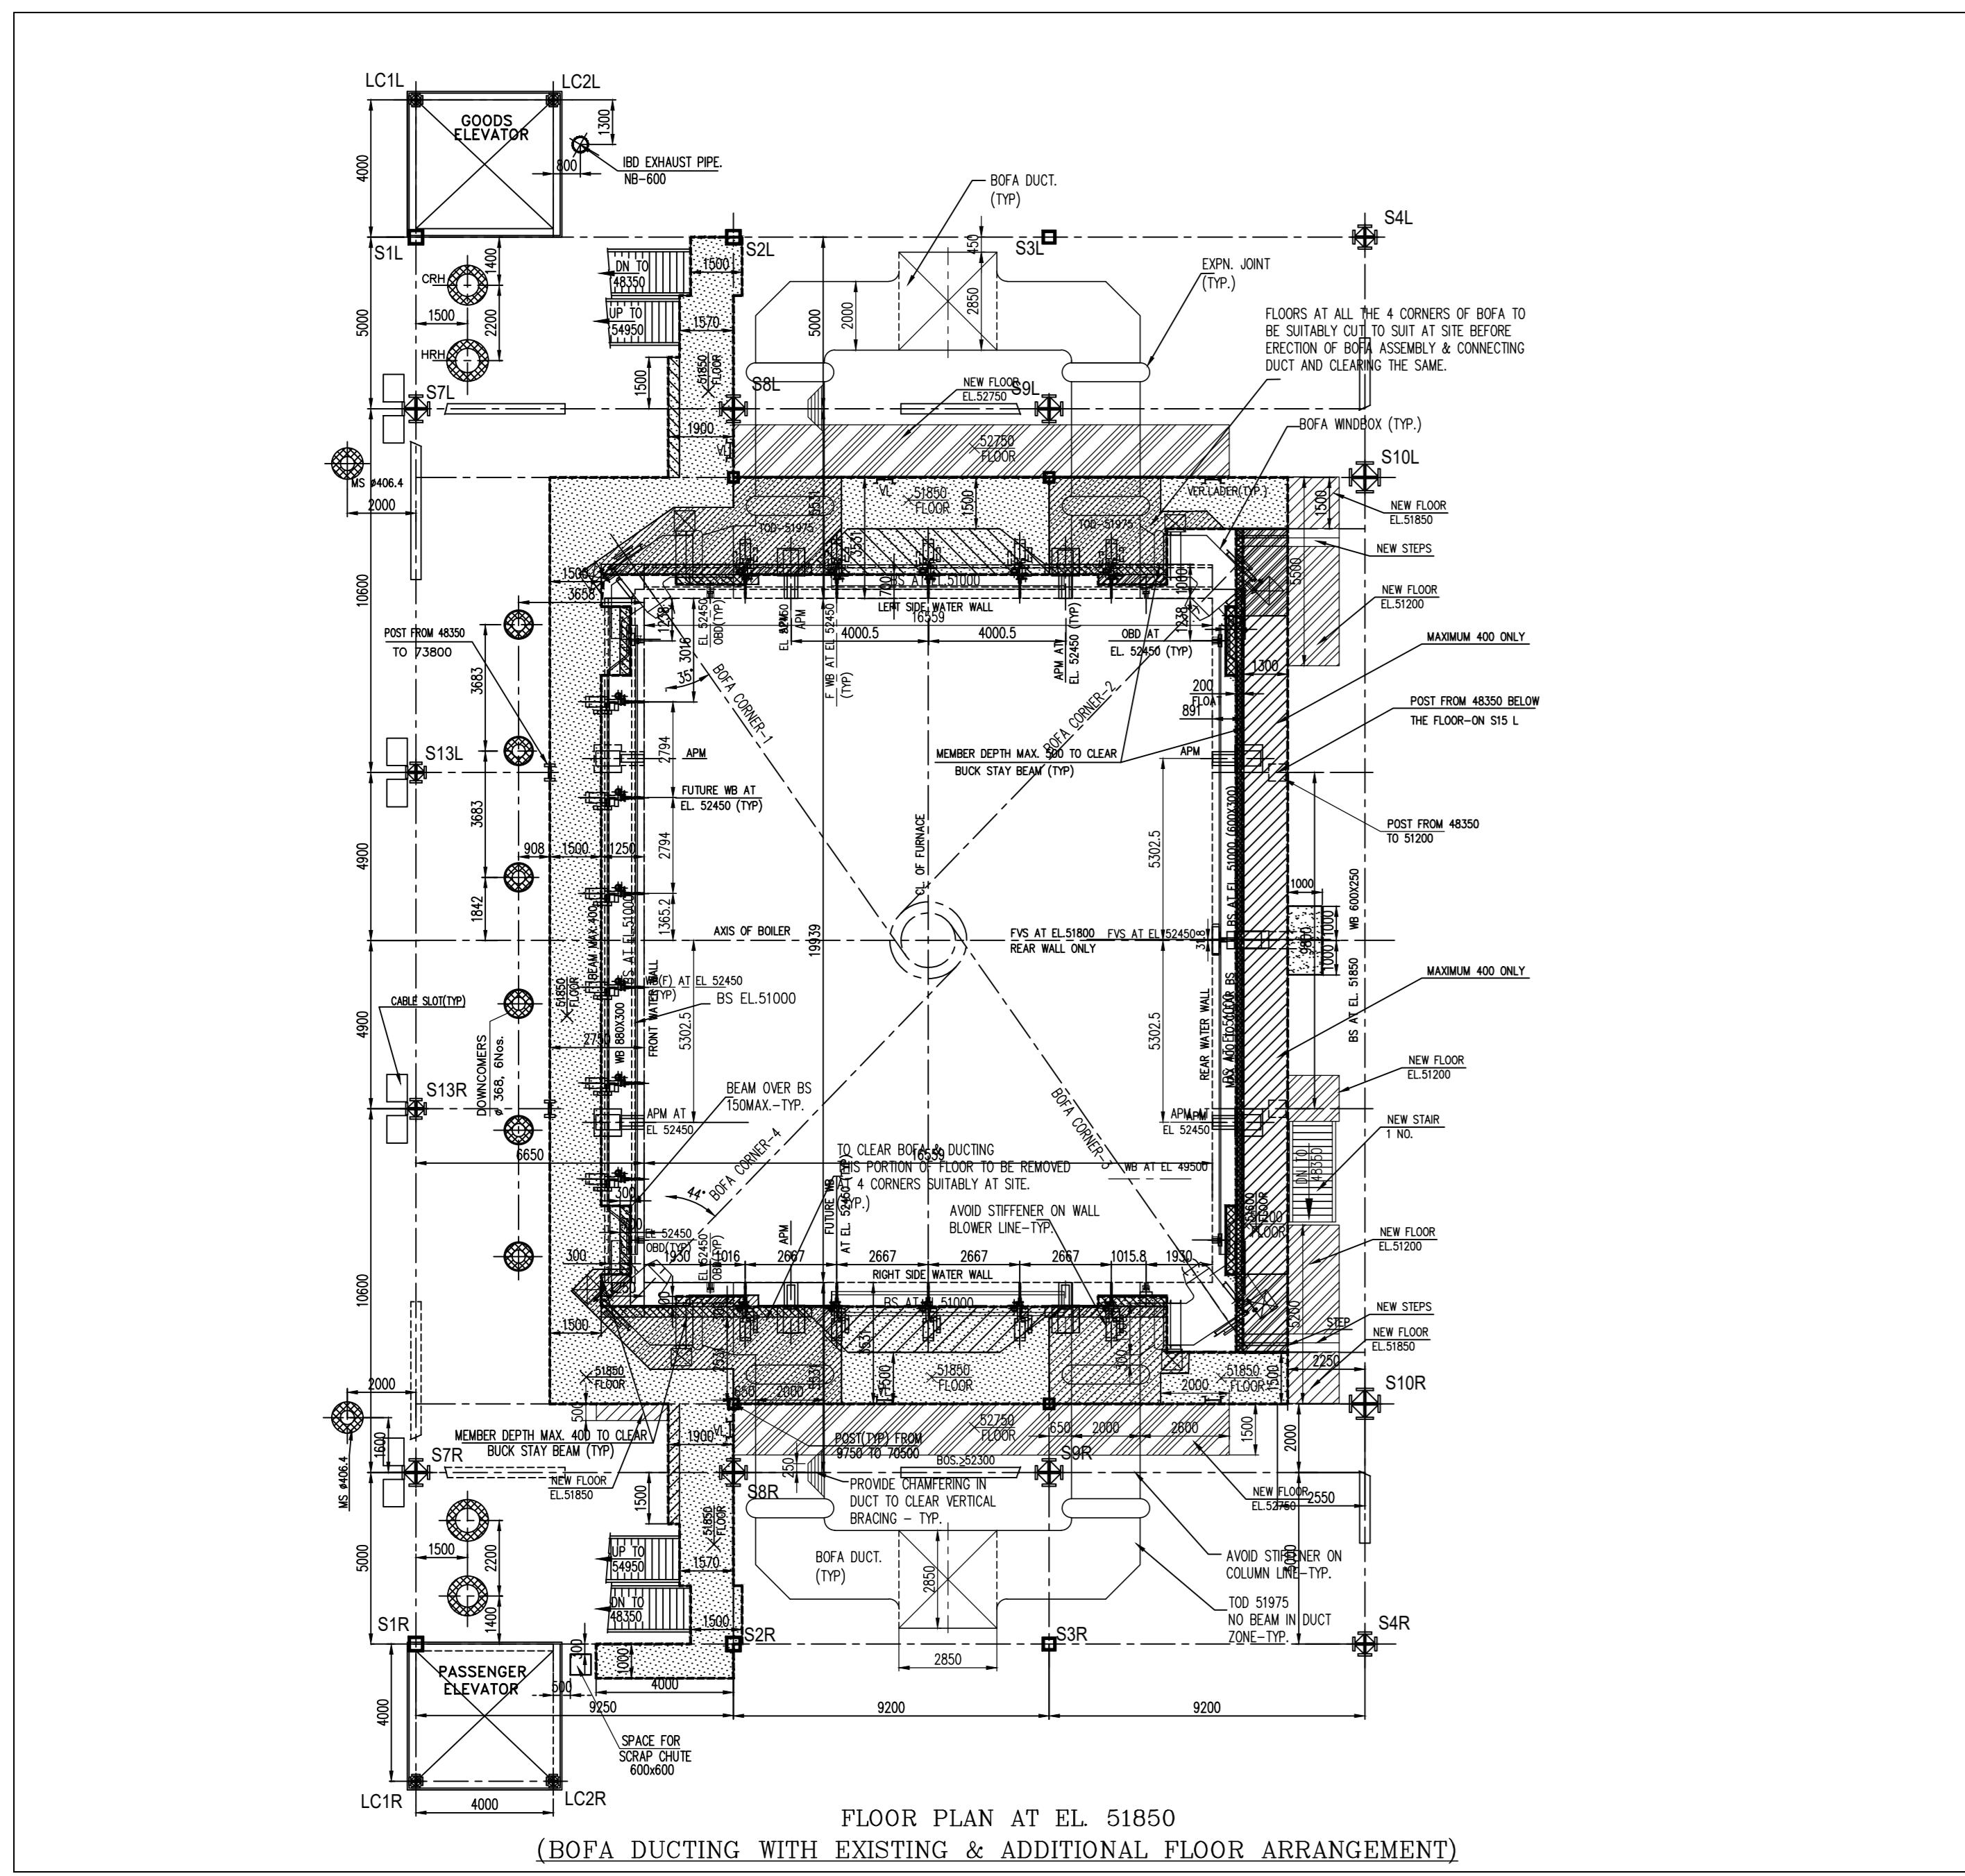
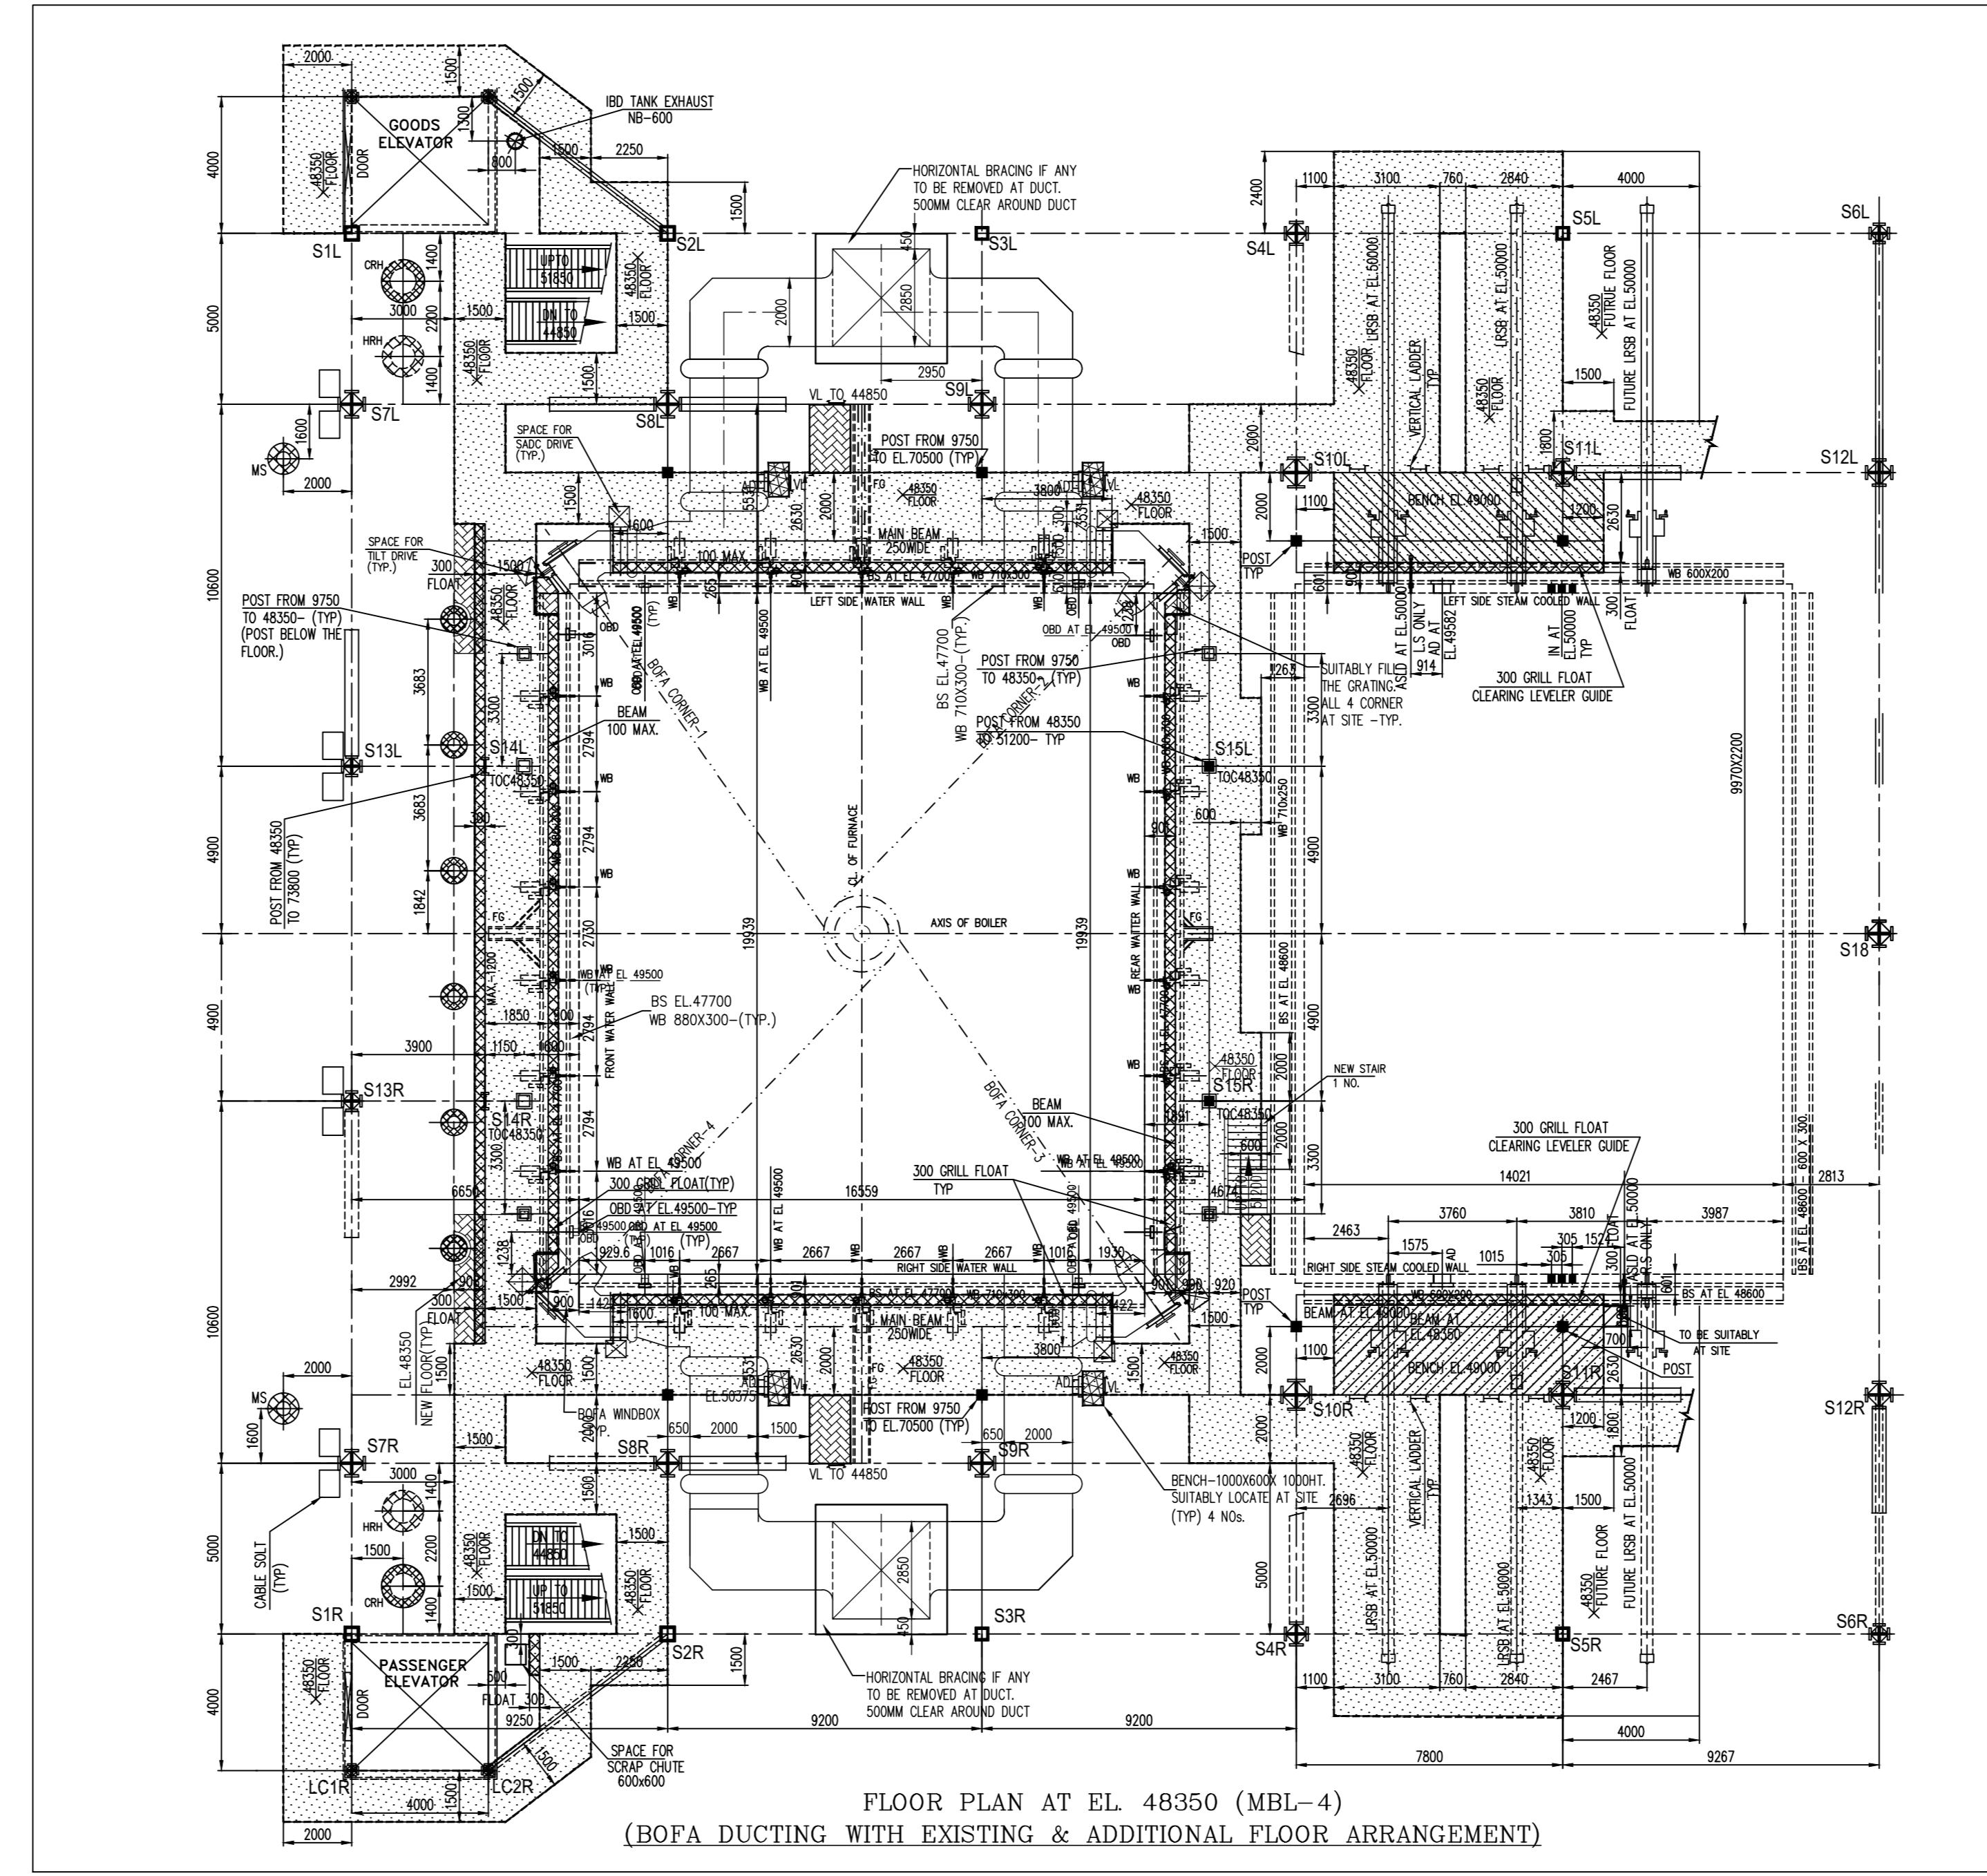


DRAWING NO: 0-00-022-77657

(BOFA DUCTING WITH EXISTING & ADDITIONAL FLOOR ARRANGEMENT)

FOR TENDER PURPOSE ONLY

ALIENT POINTS OF MODIFICATIONS:
BOFA SYSTEM IS INCORPORATED IN THE EXISTING ARRANGEMENT.
EXISTING FLOOR AT EL.51850 TO BE MODIFIED TO CLEAR BOFA
SSEMBLY & DUCTING.
ADDITIONAL FLOORS ARE ADDED AT. EL.44850, EL.48350 & EL.51850.
EXISTING BUCKSTAY AT EL.51000 TO BE MODIFIED. AT CORNERS.
APMS ARE NOT INSTALLED. HENCE RELOCATION IS NOT APPLICABLE.
ALL THE EXISTING FEATURES WHICH ARE INTERFERING WITH THE
ROPOSED ARRANGEMENT OF BOFA ARE TO BE SUITABLY RELOCATED AT
ITE TO THE EXTENT REQUIRED.
HORIZONTAL BRACINGS INTERFERING WITH BOFA SYSTEM TO BE
ODIFIED TO CLEAR BOFA & DUCTING.
DUCT STIFNERS & INSULATION AT EXISTING ITEMS TO BE ADJUSTED
OCALLY AT SITE. FOR CLEARANCE.


LEGEND: —

	— EL.52750 PLATFORM-NEW
	— EL.51200 PLATFORM-NEW
	— EL.51850 PLATFORM-NEW
	— EL.48350 PLATFORM-NEW
	— EL.44850 PLATFORM-NEW
	— BENCH-REFER DRG FOR ELEVATION.

 
AD ----- ACCESS DOOR
VL ----- VERTICAL LADDER
BS ----- BUCKSTAY
BOFA ---- BYPASSED OVERFIRE AIR

REFERENCE DRAWING NUMBERS: -

1. GA OF BOILER SEC. SIDE ELEVATION	- 0-00-022-73594
2. GA OF BOILER PLAN (SEC.AA)	- 0-00-022-73595
3. LAYOUT OF HOT AIR DUCTING (ELEVATION)	- 0-00-020-73602
4. LAYOUT OF HOT AIR DUCTING (PLAN)	- 0-00-020-73603
5. FLOOR PLAN AT EL.41350	- 0-00-021-73619
6. FLOOR PLAN AT EL.44850	- 0-00-021-73620
7. FLOOR PLAN AT EL.48350	- 0-00-021-73621
8. FLOOR PLAN AT EL.51850	- 1-00-021-70868

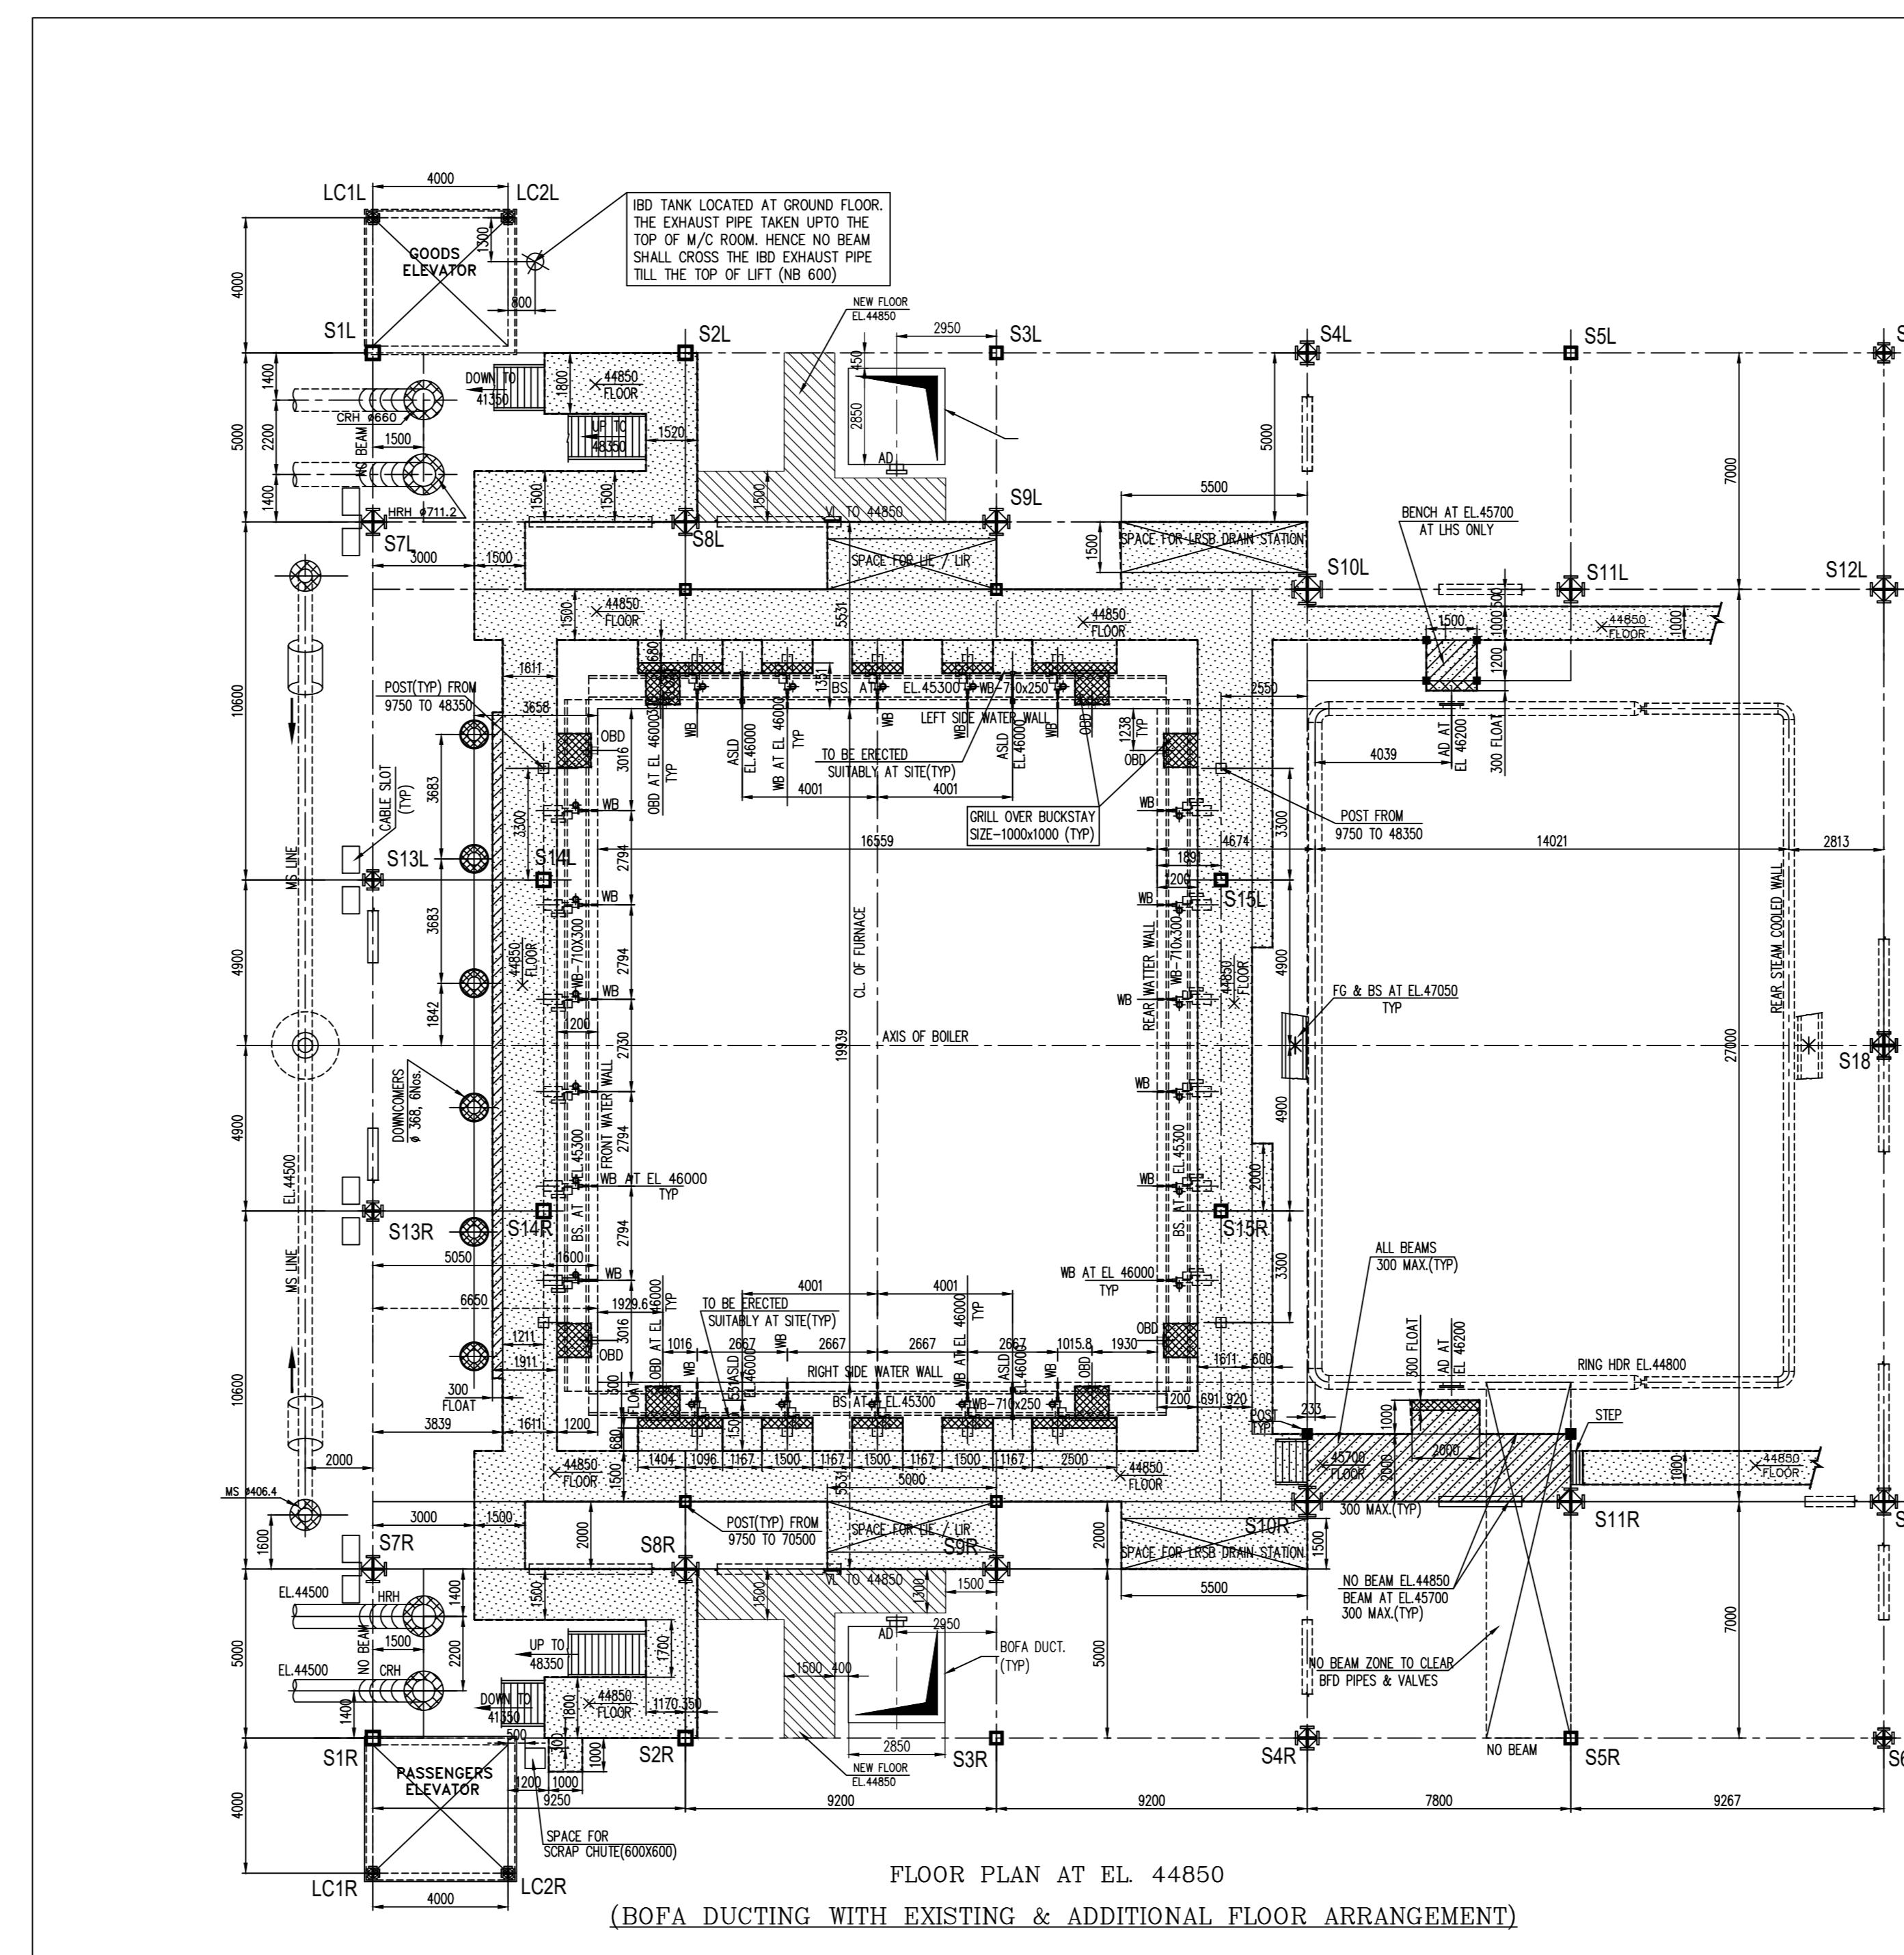

SECTIONAL SIDE ELEVATION

JOB NO:																								
STATUS: CONTRACT																								
DISTRIBUTION																								
TO																								
No. OF																								
REV	DATE	ALTD	CHD	APPD																				
<p>CAUTION: THE DRAWING IS THE PROPERTY OF BHARAT HEAVY ELECTRICALS LTD, AND IS NOT TO BE REPRODUCED OR USED FURNISH ANY INFORMATION FOR MAKING OF DRAWINGS OR APPD EXCEPT WHERE PROVIDED FOR AGREEMENT WITH SAID COMPANY</p>																								
 <p>BHEL</p> <p>BHARAT HEAVY ELECTRICALS LTD BOILER PLANT UNIT TIRUCHIRAPALLI -- 620 014</p>																								
<p>LOT-1 COMBUSTION MODIFICATION PACKAGE</p> <p>NAME SIGN DATE</p> <table border="1"> <tr> <td>DEPT CODE</td> <td>NAME</td> <td>SIGN</td> <td>DATE</td> </tr> <tr> <td>DRN</td> <td>H.MOHAN</td> <td>Signed . . .</td> <td>03.08.2019</td> </tr> <tr> <td>DESN</td> <td>K.A.P.</td> <td>Signed . . .</td> <td>03.08.2019</td> </tr> <tr> <td>CHD</td> <td>S.XAVIER</td> <td>Signed . . .</td> <td>03.08.2019</td> </tr> <tr> <td>APPD</td> <td>K.A.PALANIYAPPAN</td> <td>Signed . . .</td> <td>05.08.2019</td> </tr> </table>					DEPT CODE	NAME	SIGN	DATE	DRN	H.MOHAN	Signed . . .	03.08.2019	DESN	K.A.P.	Signed . . .	03.08.2019	CHD	S.XAVIER	Signed . . .	03.08.2019	APPD	K.A.PALANIYAPPAN	Signed . . .	05.08.2019
DEPT CODE	NAME	SIGN	DATE																					
DRN	H.MOHAN	Signed . . .	03.08.2019																					
DESN	K.A.P.	Signed . . .	03.08.2019																					
CHD	S.XAVIER	Signed . . .	03.08.2019																					
APPD	K.A.PALANIYAPPAN	Signed . . .	05.08.2019																					
<p>TITLE BOILER GA SHOWING HOT SEC. AIR DUCTING TO BOFA REGISTER ARRANGEMENT—PLAN & ELEVATION</p>																								
<p>DRAWING NO.</p> <p>0-00-022-77657</p>			<p>SCALE 1:150</p> 	<p>DRG No.</p> <p>-----</p>																				
				<p>SHEET 01 OF 01 REV 00</p>																				