

ALL INFORMATION CONTAINED IN THIS DOCUMENT IS CONFIDENTIAL AND THE PROPERTY OF TOSHIBA TRANSMISSION & DISTRIBUTION SYSTEMS (INDIA) PRIVATE LIMITED. REPRODUCTION OF THIS IN ANY FORM IS TO BE DONE WITH THE SPECIFIC PERMISSION OF THE ORGANIZATION.

UNIT No.	BAY NAME
D01	ICT-1
D02	220kV PRATAP SHASAN-1
D03	220kV PRATAP SHASAN-2
D04	BUS COUPLER
D05	220kV BUS PT
D06	220kV PARADEEP-1
D07	220kV PARADEEP-2
D08	ICT-2
D09	BUS SECTION
D10	FUTURE LINE-1
D11	FUTURE LINE-2
D12	FUTURE ICT-3
D13	FUTURE ICT-4

PHASE ARRANGEMENT			
PHASE	SIGN	MARK/ COLOUR	
FIRST	R	(R) RED	
SECOND	Y	(Y) YELLOW	
THIRD	B	(B) BLUE	

NOTES: (APPLICABLE FOR ALL SHEETS)

- LCC- LOCAL CONTROL CUBICLE.
- FFL- GIS FINISHED FLOOR LEVEL.
- TOC- TOP OF CONCRETE.
- EL - ELEVATION LEVEL.
- FGL- FINISH GROUND LEVEL.
- (*1) THE EXACT DIMENSIONS WILL BE FINALIZED BASED ON THE FINAL CUSTOMER APPROVAL ON THE LCC SCHEMATICS.
- POSITION OF SUPPORT STRUCTURES IN THE SECTIONAL VIEWS INDICATIVE ONLY & SAME WILL BE FINALISED IN THE FOUNDATION PLAN

APPROVED

REV 1

CHECKED

A.G.M (Elect)
ENGG. & QUALITY
OPTCL, BHUBANESWAR

APPROVED

G.M. (Elect)
ENGG. & QUALITY
OPTCL, BHUBANESWAR

02

Y - CO-ORDINATE UPDATED AS PER BH&L COMMENT

27.02.24

SIGN

YS

SM

KI

NAME

Y. SANDEEP

M. SREEDHAR

K. IKEDA

SIGN

YS

SM

KI

01

UPDATED AS PER CUSTOMER COMMENTS (BAY SEQUENCE CHANGED)

20.01.24

SIGN

YS

SM

KI

NAME

Y. SANDEEP

M. SREEDHAR

K. IKEDA

SIGN

YS

SM

KI

REV

DETAILS OF MODIFICATION

REV. MARK

DATE

MODIFIED

CHECKED

APPROVED

NAME

SIGN

DATE

DESIGNED

CH.BHAGAVAN

06.01.2024

DRAWN

Y.RAMBABU

06.01.2024

CHECKED

M.SREEDHAR

06.01.2024

APPROVED

K.IKEDA

06.01.2024

PRODUCT

245KV GIS

TOSHIBA

TOSHIBA TRANSMISSION & DISTRIBUTION SYSTEMS (INDIA) PRIVATE LIMITED

SCALE: 1:80

SWITCHGEAR PRODUCTS DIVISION

TITLE

220kV GIS-GENERAL ARRANGEMENT PLAN & SECTIONS-OPTCL ERSAMA

DRAWING NO.: DEDUGB18011005

SHEET NO: 01 OF 06

REV:02

PROJECT

400/220kV GIS SUBSTATION AT ERSAMA, ODISHA & 400kV AIS FEEDER BAY EXTENSION AT DUBURI, ODISHA

OWNER

ODISHA POWER TRANSMISSION CORPORATION LIMITED

OBTGM

BHARAT HEAVY ELECTRICALS LTD TRANSMISSION BUSINESS GROUP NOIDA

DEPT CODE

DRN

NAME

SIGN

DATE

M

CHD

06.01.2024

APPD

06.01.2024

TITLE

220kV GIS Indoor Layout, Plan & Section

SCALE

1:60

DRAWING NO.

TB-420-316-071-03A

SIGN

DATE

SHEET

01

OF

06

REV.02


F
G
H

K

K

L

ALL INFORMATION CONTAINED IN THIS DOCUMENT IS CONFIDENTIAL AND THE PROPERTY OF TOSHIBA TRANSMISSION & DISTRIBUTION SYSTEMS (INDIA) PRIVATE LIMITED. REPRODUCTION OF THIS IN ANY FORM IS TO BE DONE WITH THE SPECIFIC PERMISSION OF THE ORGANIZATION.

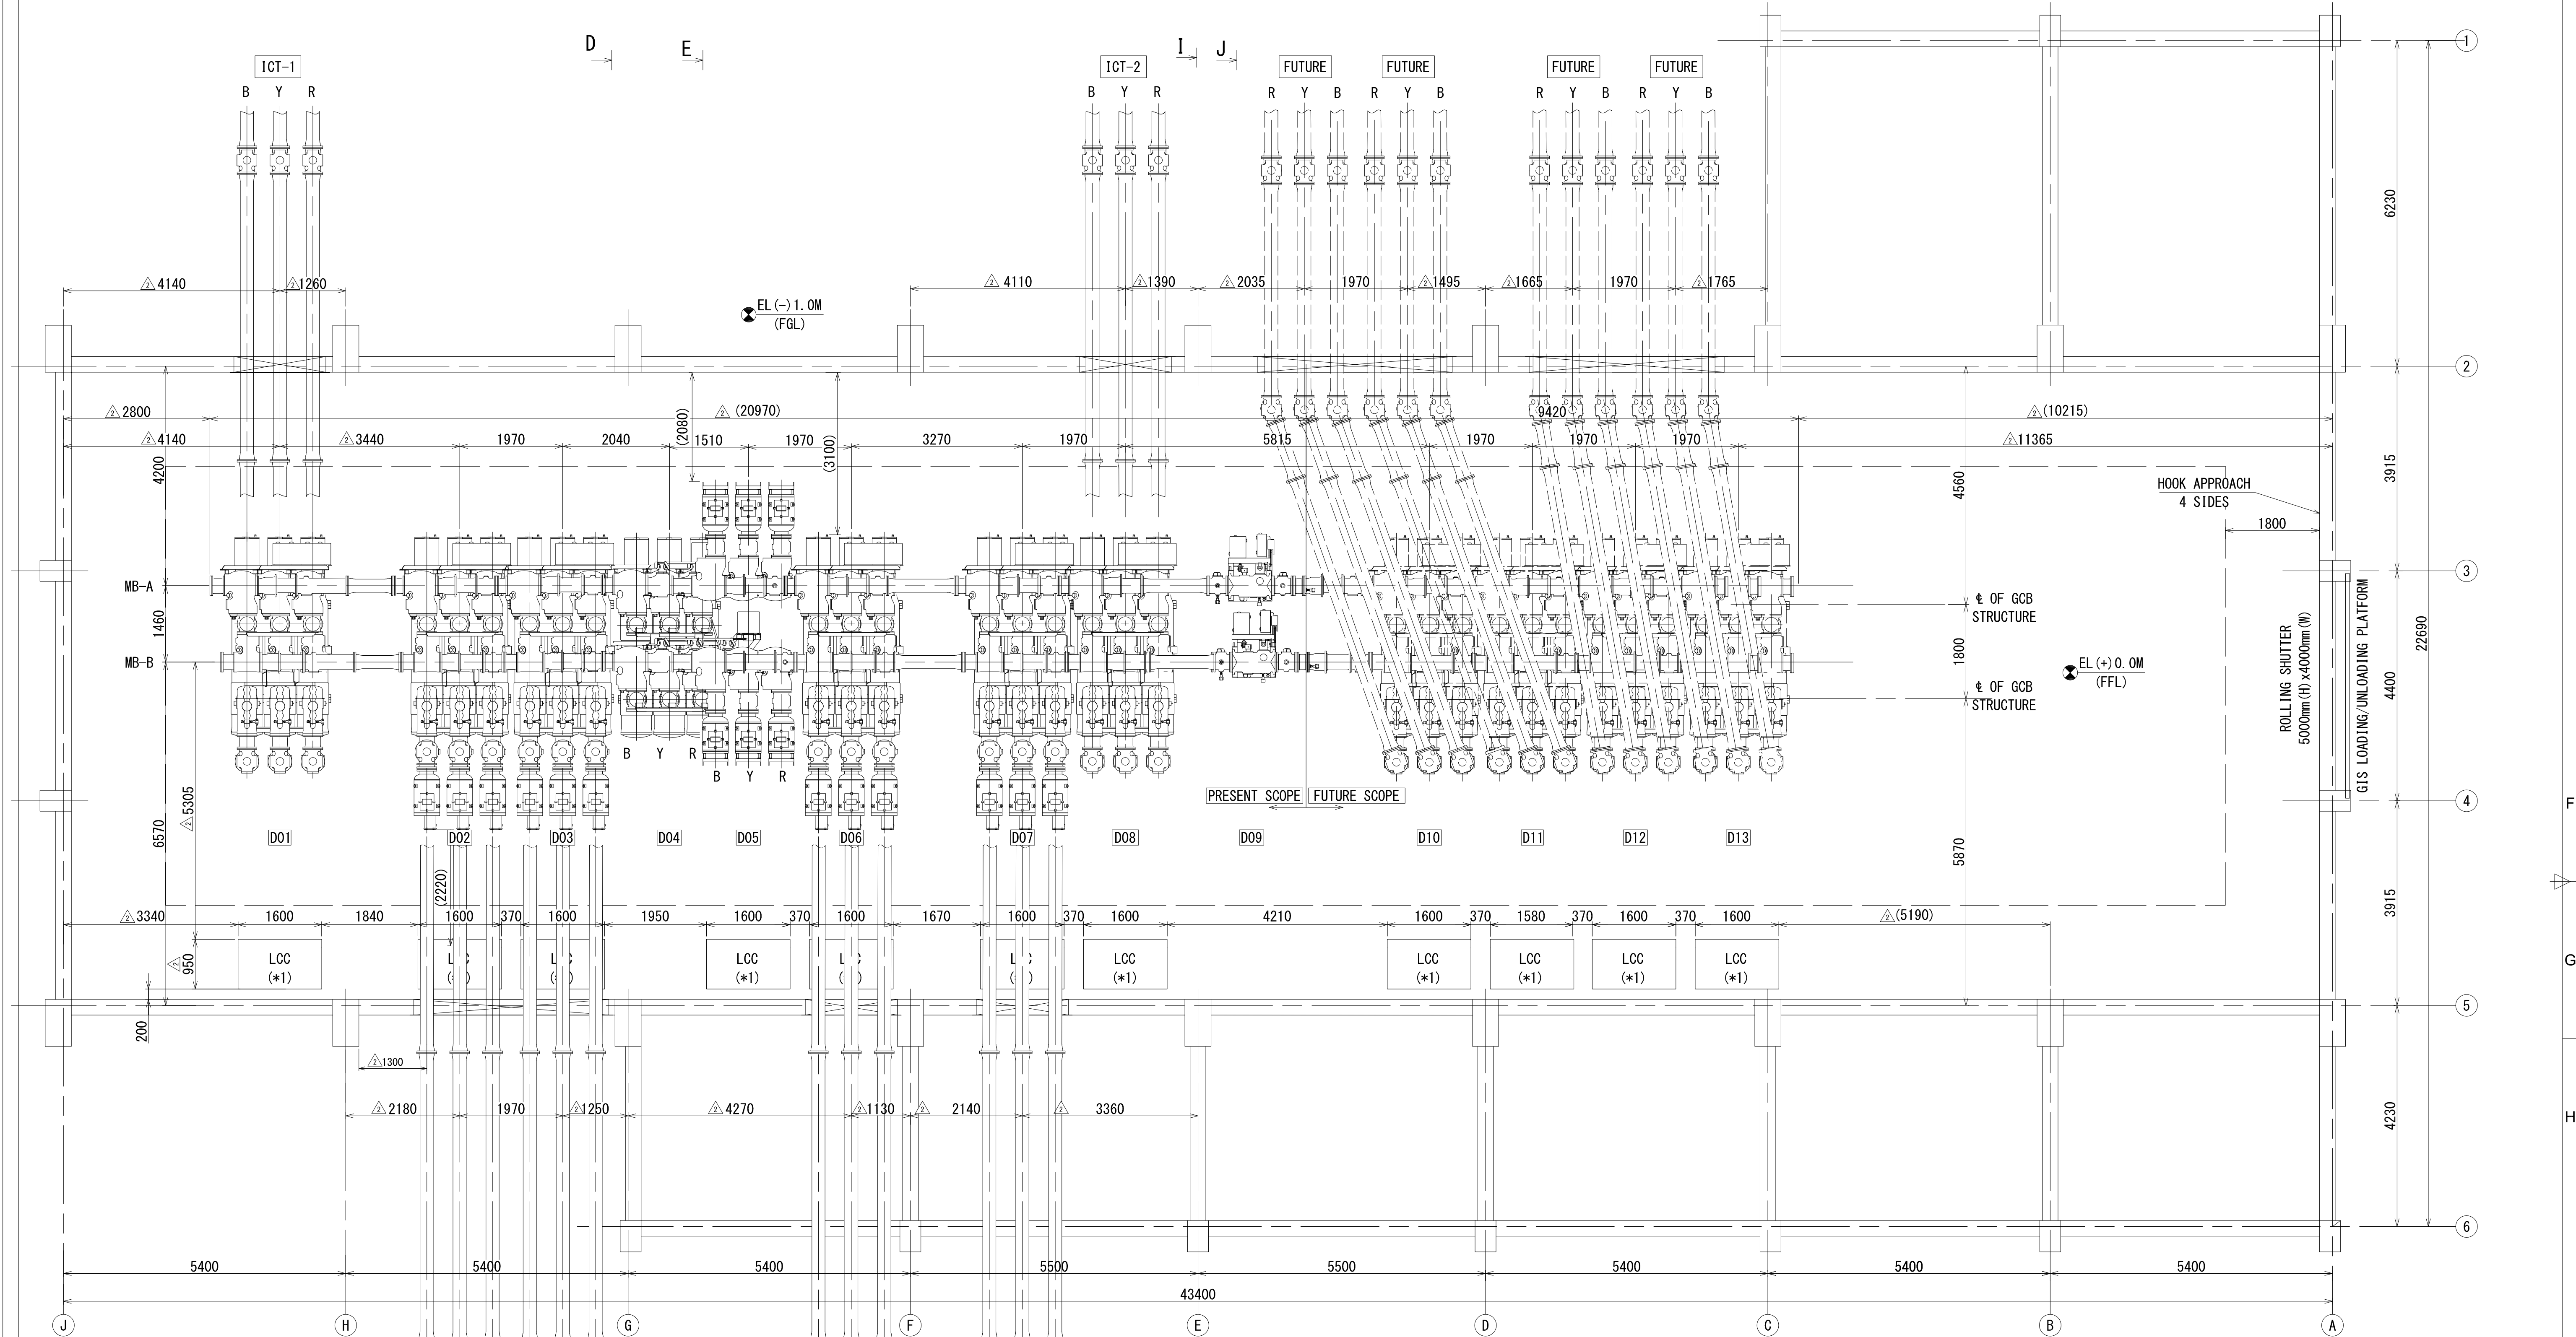

UNIT No.	BAY NAME	UNIT No.	BAY NAME
D01	ICT-1	D07	220kV PARADEEP-2
D02	220kV PRATAP SHASAN-1	D08	ICT-2
D03	220kV PRATAP SHASAN-2	D09	BUS SECTION
D04	BUS COUPLER	D10	△ FUTURE LINE-1
D05	220kV BUS PT	D11	△ FUTURE LINE-2
D06	220kV PARADEEP-1	D12	△ FUTURE ICT-3
		D13	△ FUTURE ICT-4

PHASE ARRANGEMENT		
PHASE	SIGN	MARK/ COLOUR
FIRST	R	(R) RED
SECOND	Y	(Y) YELLOW
THIRD	B	(B) BLUE

- NOTES:
1. LCC- LOCAL CONTROL CUBICLE.
 2. FFL- GIS FINISHED FLOOR LEVEL.
 3. TOC- TOP OF CONCRETE.
 4. EL - ELEVATION LEVEL.
 5. FGL- FINISH GROUND LEVEL.
 - △ 6. (*1) THE EXACT DIMENSIONS WILL BE FINALIZED BASED ON THE FINAL CUSTOMER APPROVAL ON THE LCC SCHEMATICS.
 7. POSITION OF SUPPORT STRUCTURES IN THE SECTIONAL VIEWS INDICATIVE ONLY & SAME WILL BE FINALISED IN THE FOUNDATION PLAN

02	Y - CO-ORDINATE UPDATED AS PER BHEL COMMENTS	△	27.02.24	SIGN	YS	SM	IK
				NAME	Y. SANDEEP	M. SREEDHAR	K. IKEDA
01	UPDATED AS PER CUSTOMER COMMENTS (BAY SEQUENCE CHANGED)	△	20.01.24	SIGN	YS	SM	IK
				NAME	Y. SANDEEP	M. SREEDHAR	K. IKEDA
REV	DETAILS OF MODIFICATION	REV. MARK	DATE	MODIFIED	CHECKED	APPROVED	
				NAME	SIGN	DATE	
				DESIGNED	CH.BHAGAVAN		06.01.2024
				DRAWN	Y.RAMABABU		06.01.2024
				CHECKED	M.SREEDHAR		06.01.2024
				APPROVED	K.IKEDA		06.01.2024
				PRODUCT	245KV GIS		
				DESIGNED NO.:	DEUDUGB8011005		
				SHEET NO.:	02 OF 06	REV.02	

PROJECT		400/220kV GIS SUBSTATION AT ERSAMA, ODISHA & 400kV AIS FEEDER BAY EXTENSION AT DUBURI, ODISHA									
OWNER		ODISHA POWER TRANSMISSION CORPORATION LIMITED									
QBTGM		BHARAT HEAVY ELECTRICALS LTD TRANSMISSION BUSINESS GROUP NOIDA				DEPT CODE	NAME	SIGN		DATE	
						M	DRN			06.01.2024	
							CHD			06.01.2024	
							APPD			06.01.2024	
TITLE											
220kV GIS Indoor Layout, Plan & Section											
				DEPT.	SCALE 1:60		DRAWING NO.				
				SIGN		TB-420-316-071-03A					
				DATE		SHEET 02 OF 06		REV. 02			

CHECKED

Sandeep

A.G.M (Elect)

ENGG. & QUALITY

OPTCL, BHUBANESWAR


APPROVED

G.M.

G.M. (Elect)

ENGG. & QUALITY

OPTCL, BHUBANESWAR

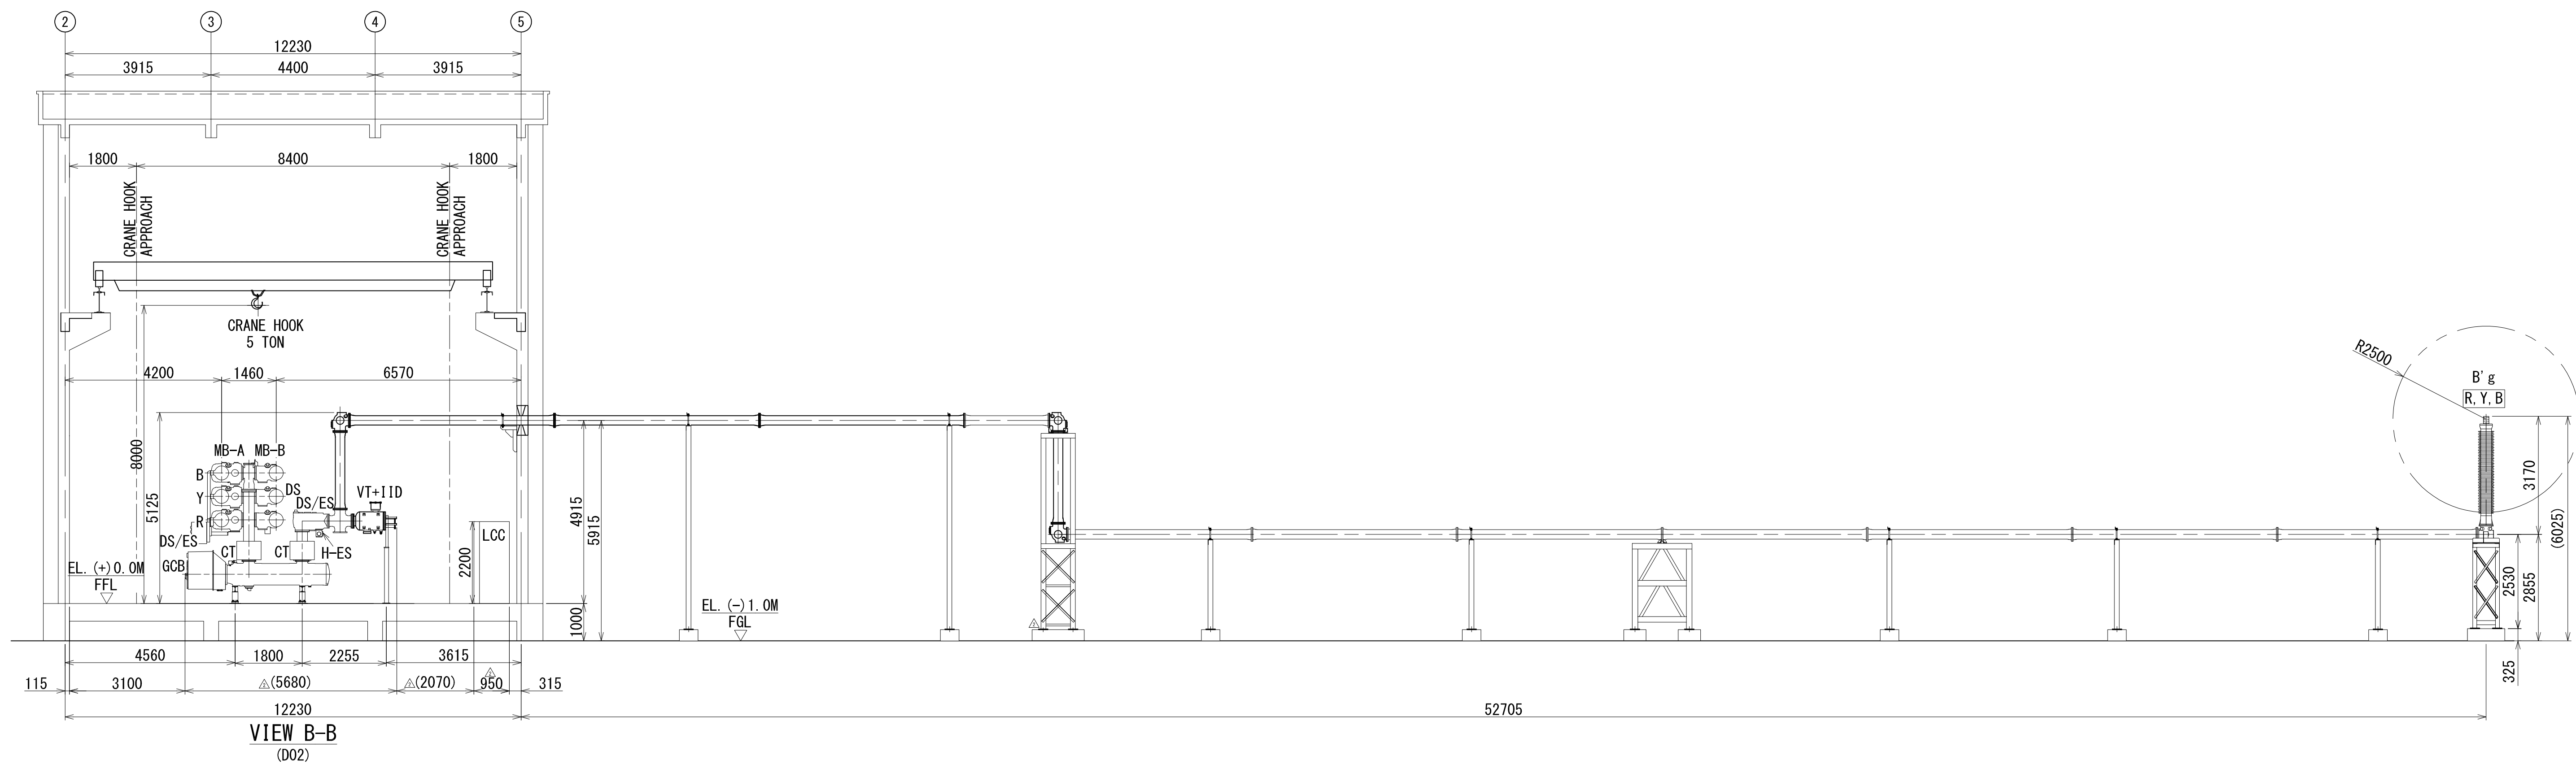




CHECKED
S. Nanda
A.G.M (Elect)
ENGG. & QUALITY
OPTCL, BHUBANESWAR

APPROVED



 G.M. (Elect)
ENGG. & QUALITY
OPTCL, BHUBANESWAR

02	Y - CO-ORDINATE UPDATED AS PER BHEL COMMENT		27.02.24	SIGN NAME	YS	SM	IK
01	UPDATED AS PER CUSTOMER COMMENTS (BAY SEQUENCE CHANGED)		20.01.24	SIGN NAME	Y. SANDEEP	M. SREEDHAR	K. IKEDA
				YS	SM	IK	
REV	DETAILS OF MODIFICATION	REV. MARK	DATE	MODIFIED	CHECKED	APPROVED	
TOSHIBA TOSHIBA TRANSMISSION & DISTRIBUTION SYSTEMS (INDIA) PRIVATE LIMITED					NAME	SIGN	DATE
				DESIGNED	CH.BHAGAVAN		06.01.2024
				DRAWN	Y.RAMBABHU		06.01.2024
				CHECKED	M.SREEDHAR		06.01.2024
				APPROVED	K.IKEDA		05.01.2024
SCALE: 1:90		SWITCHGEAR PRODUCTS DIVISION		PRODUCT 245kV GIS			
		TITLE: 220kV GIS-GENERAL ARRANGEMENT PLAN & SECTIONS-OPTEL ERSAMA		DRAWING NO: DEDUGB168011005			
				SHEET NO: 03 OF 06 REV: 02			

  
PROJECT		400/220kV GIS SUBSTATION AT ERSAMA, ODISHA & 400kV AIS FEEDER BAY EXTENSION AT DUBURI, ODISHA									
OWNER		 ODISHA POWER TRANSMISSION CORPORATION LIMITED									
QBTGM		BHARAT HEAVY ELECTRICALS LTD TRANSMISSION BUSINESS GROUP NOIDA				DEPT CODE		NAME	SIGN	DATE	
						DRN				06.01.2024	
						CHD				06.01.2024	
						APPD				06.01.2024	
TITLE		220kV GIS Indoor Layout, Plan & Section									
						DEPT.	SCALE 1:90	DRAWING NO.			
						SIGN		TB-420-316-071-03A			
						DATE		SHEET 03 OF 06		REV. 02	

220kV GIS Indoor Layout, Plan & Section


		DEPT.	SCALE 1:90	DRAWING NO.
--	--	-------	------------	-------------

SHEET 03 OF 06	REV. 02
----------------	---------


ALL INFORMATION CONTAINED IN THIS DOCUMENT IS CONFIDENTIAL AND THE PROPERTY OF TOSHIBA TRANSMISSION & DISTRIBUTION SYSTEMS (INDIA) PRIVATE LIMITED. REPRODUCTION OF THIS IN ANY FORM IS TO BE DONE WITH THE SPECIFIC PERMISSION OF THE ORGANIZATION.

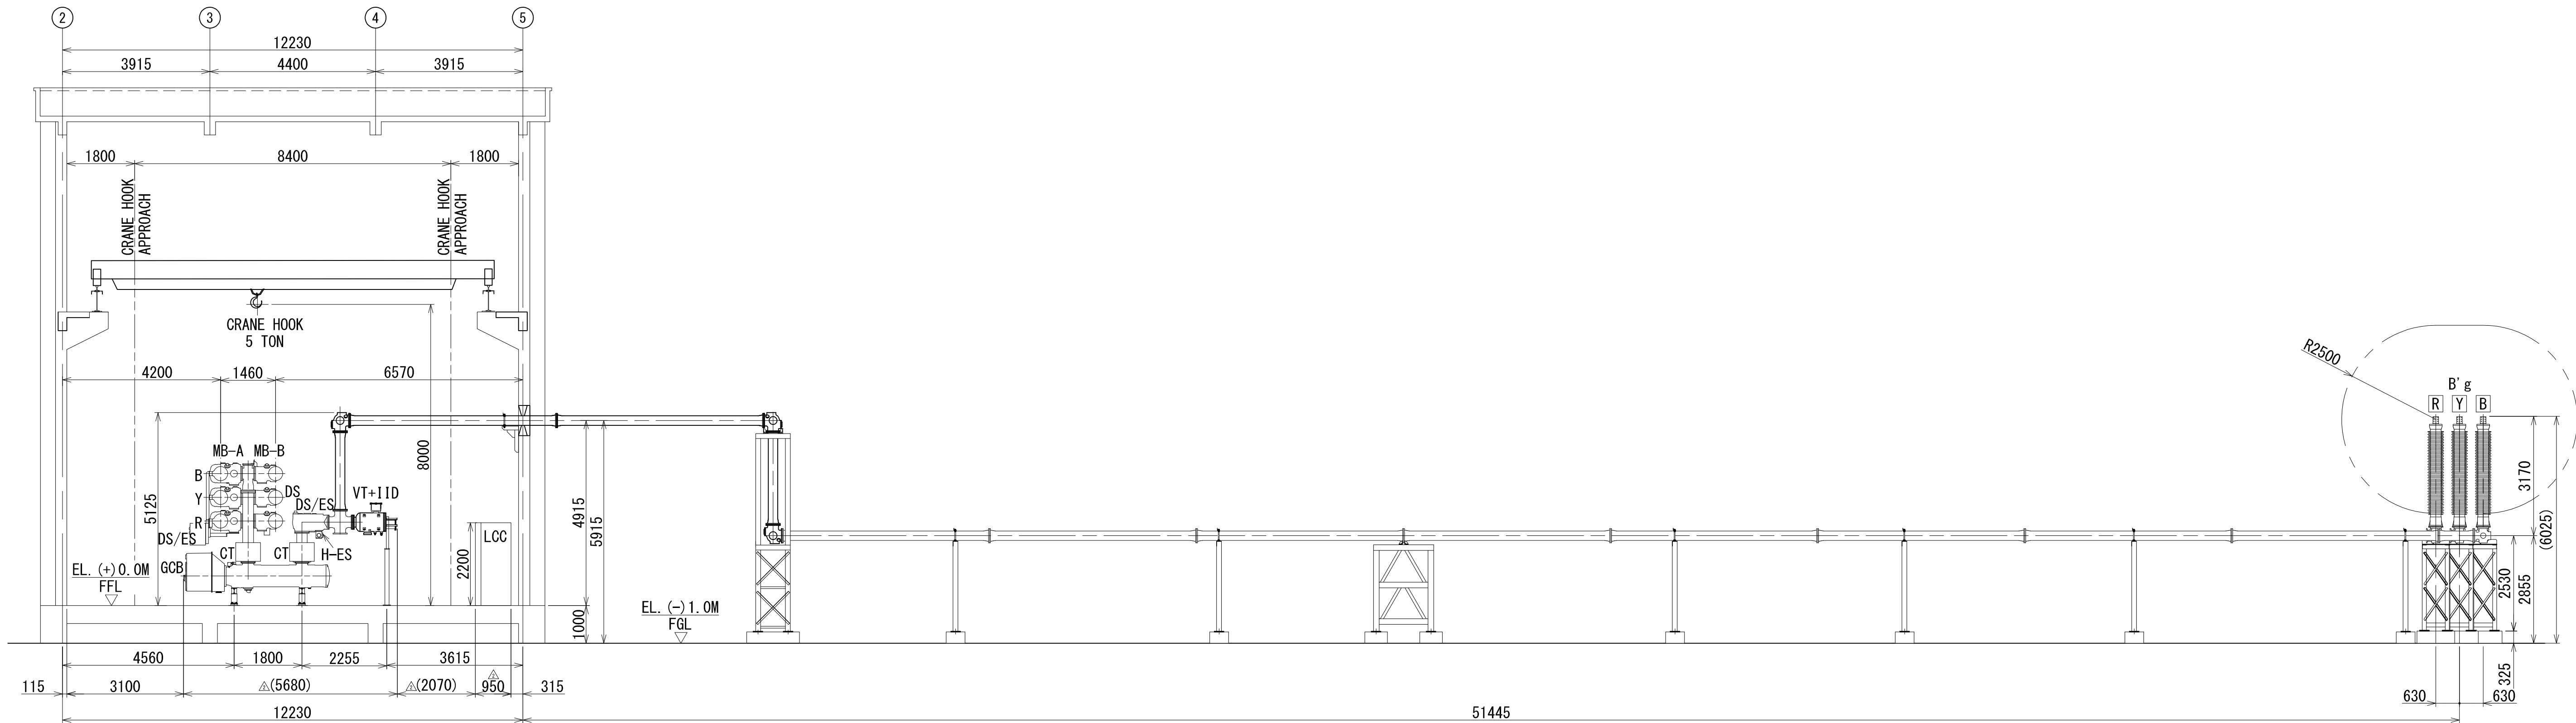

VIEW C-C
(D03)

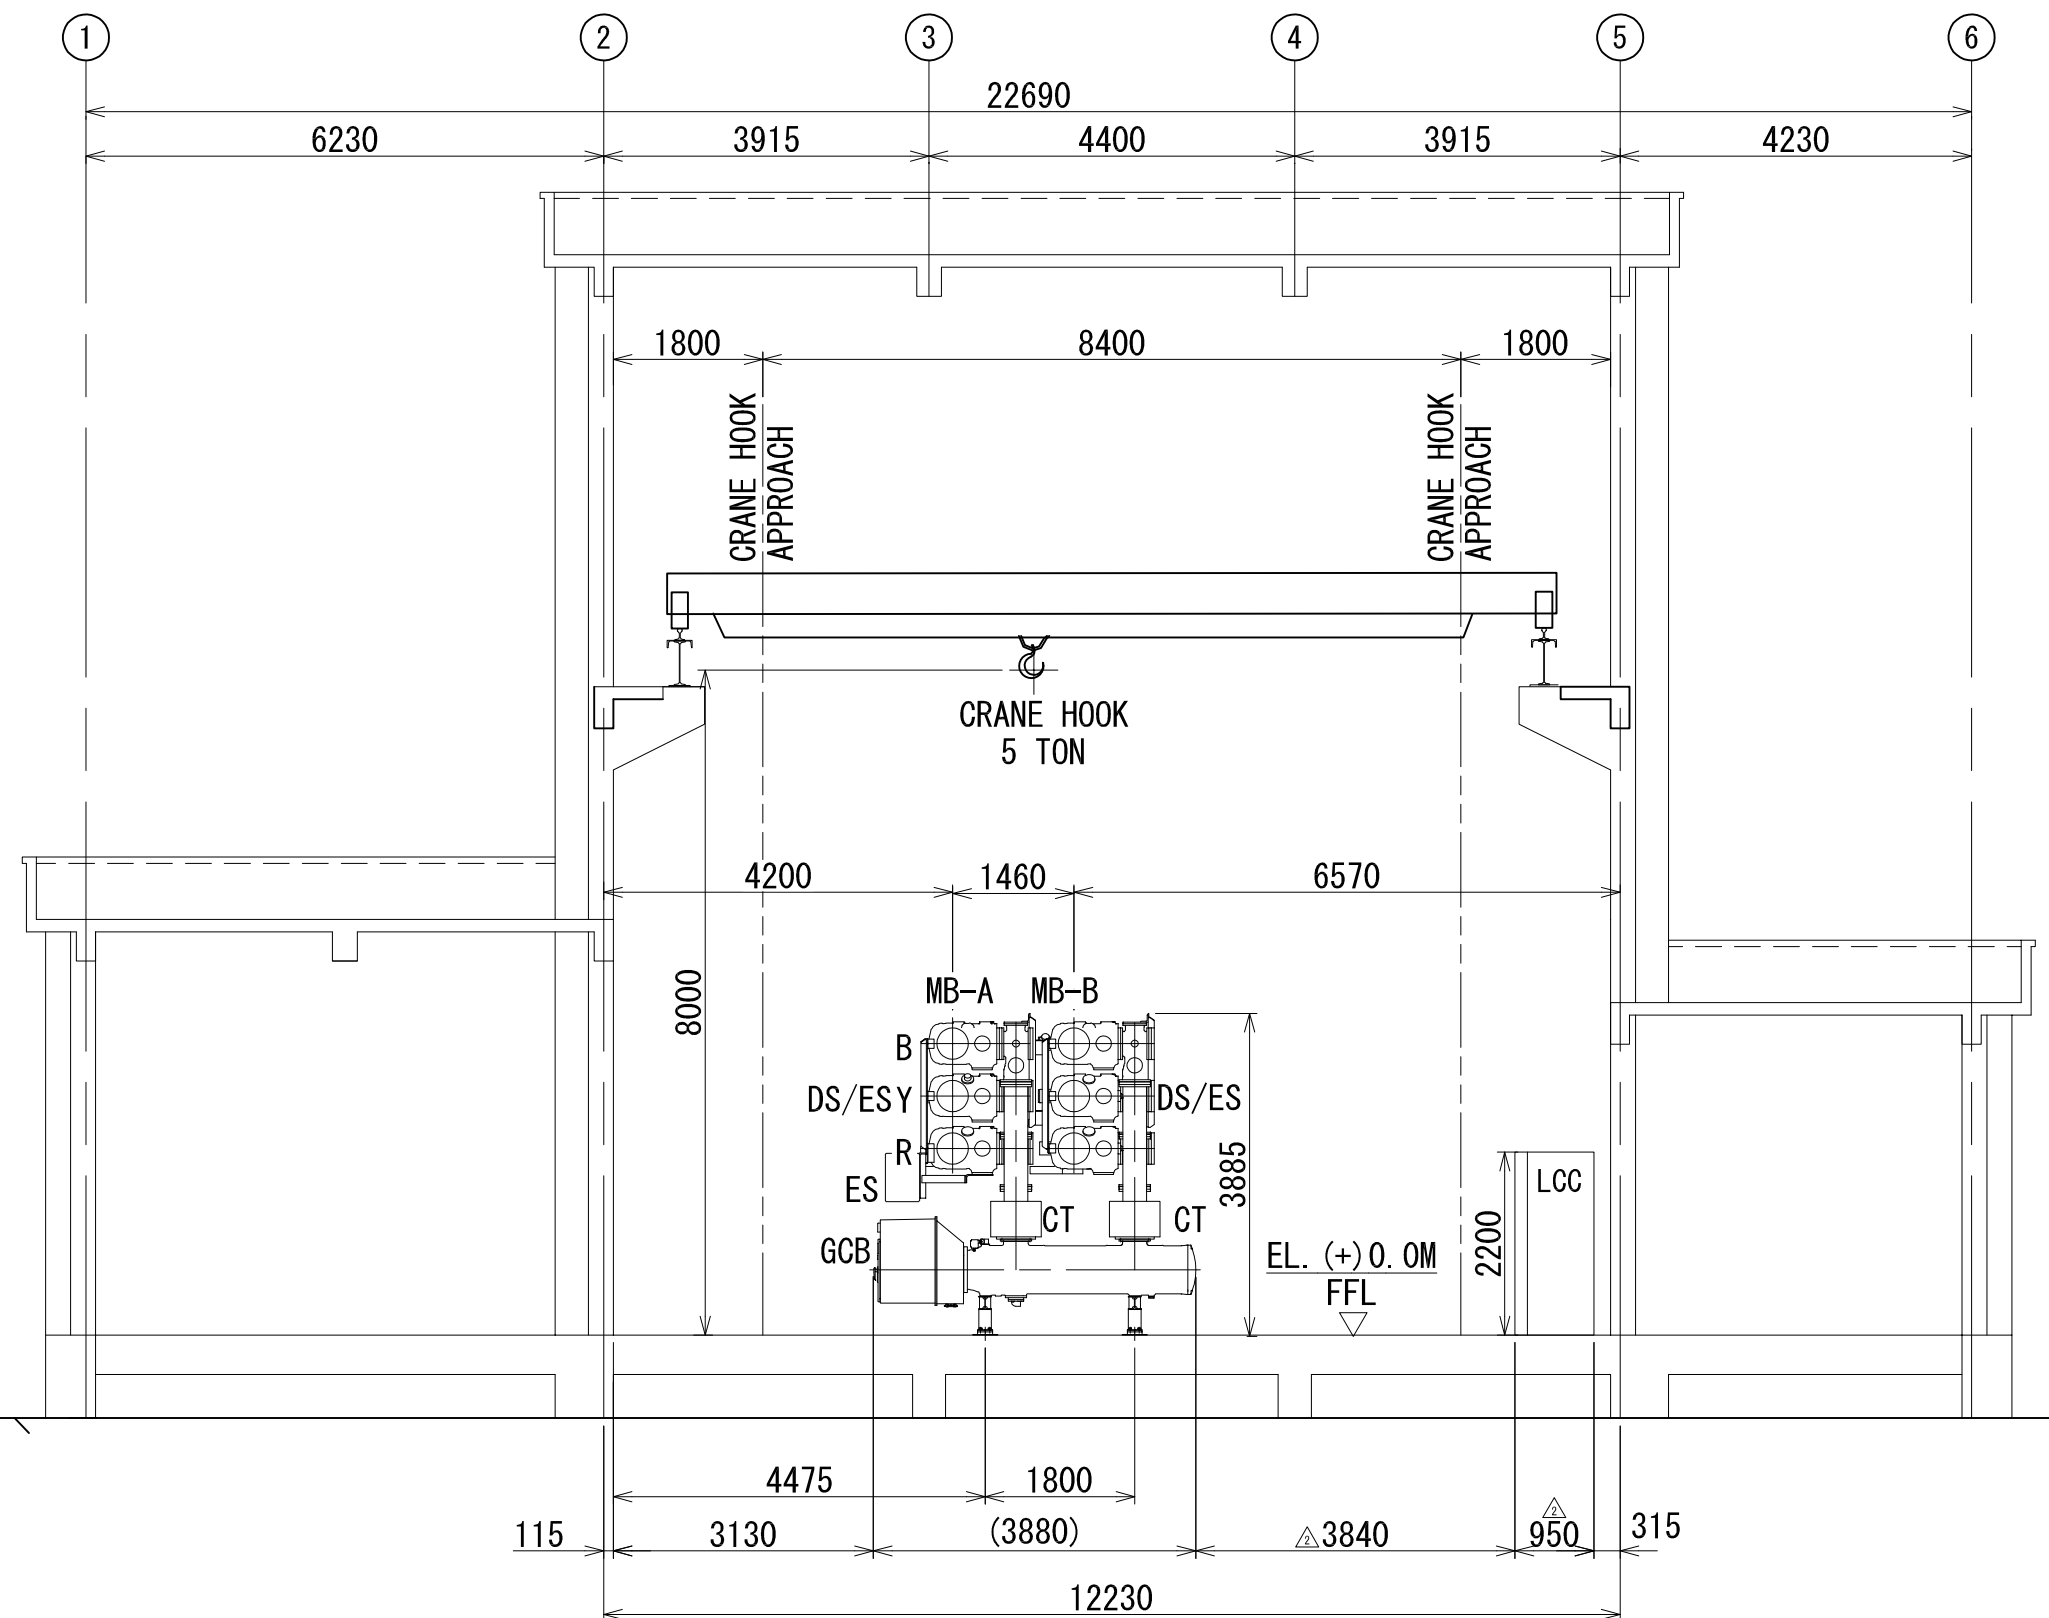


VIEW D-D
(D04)

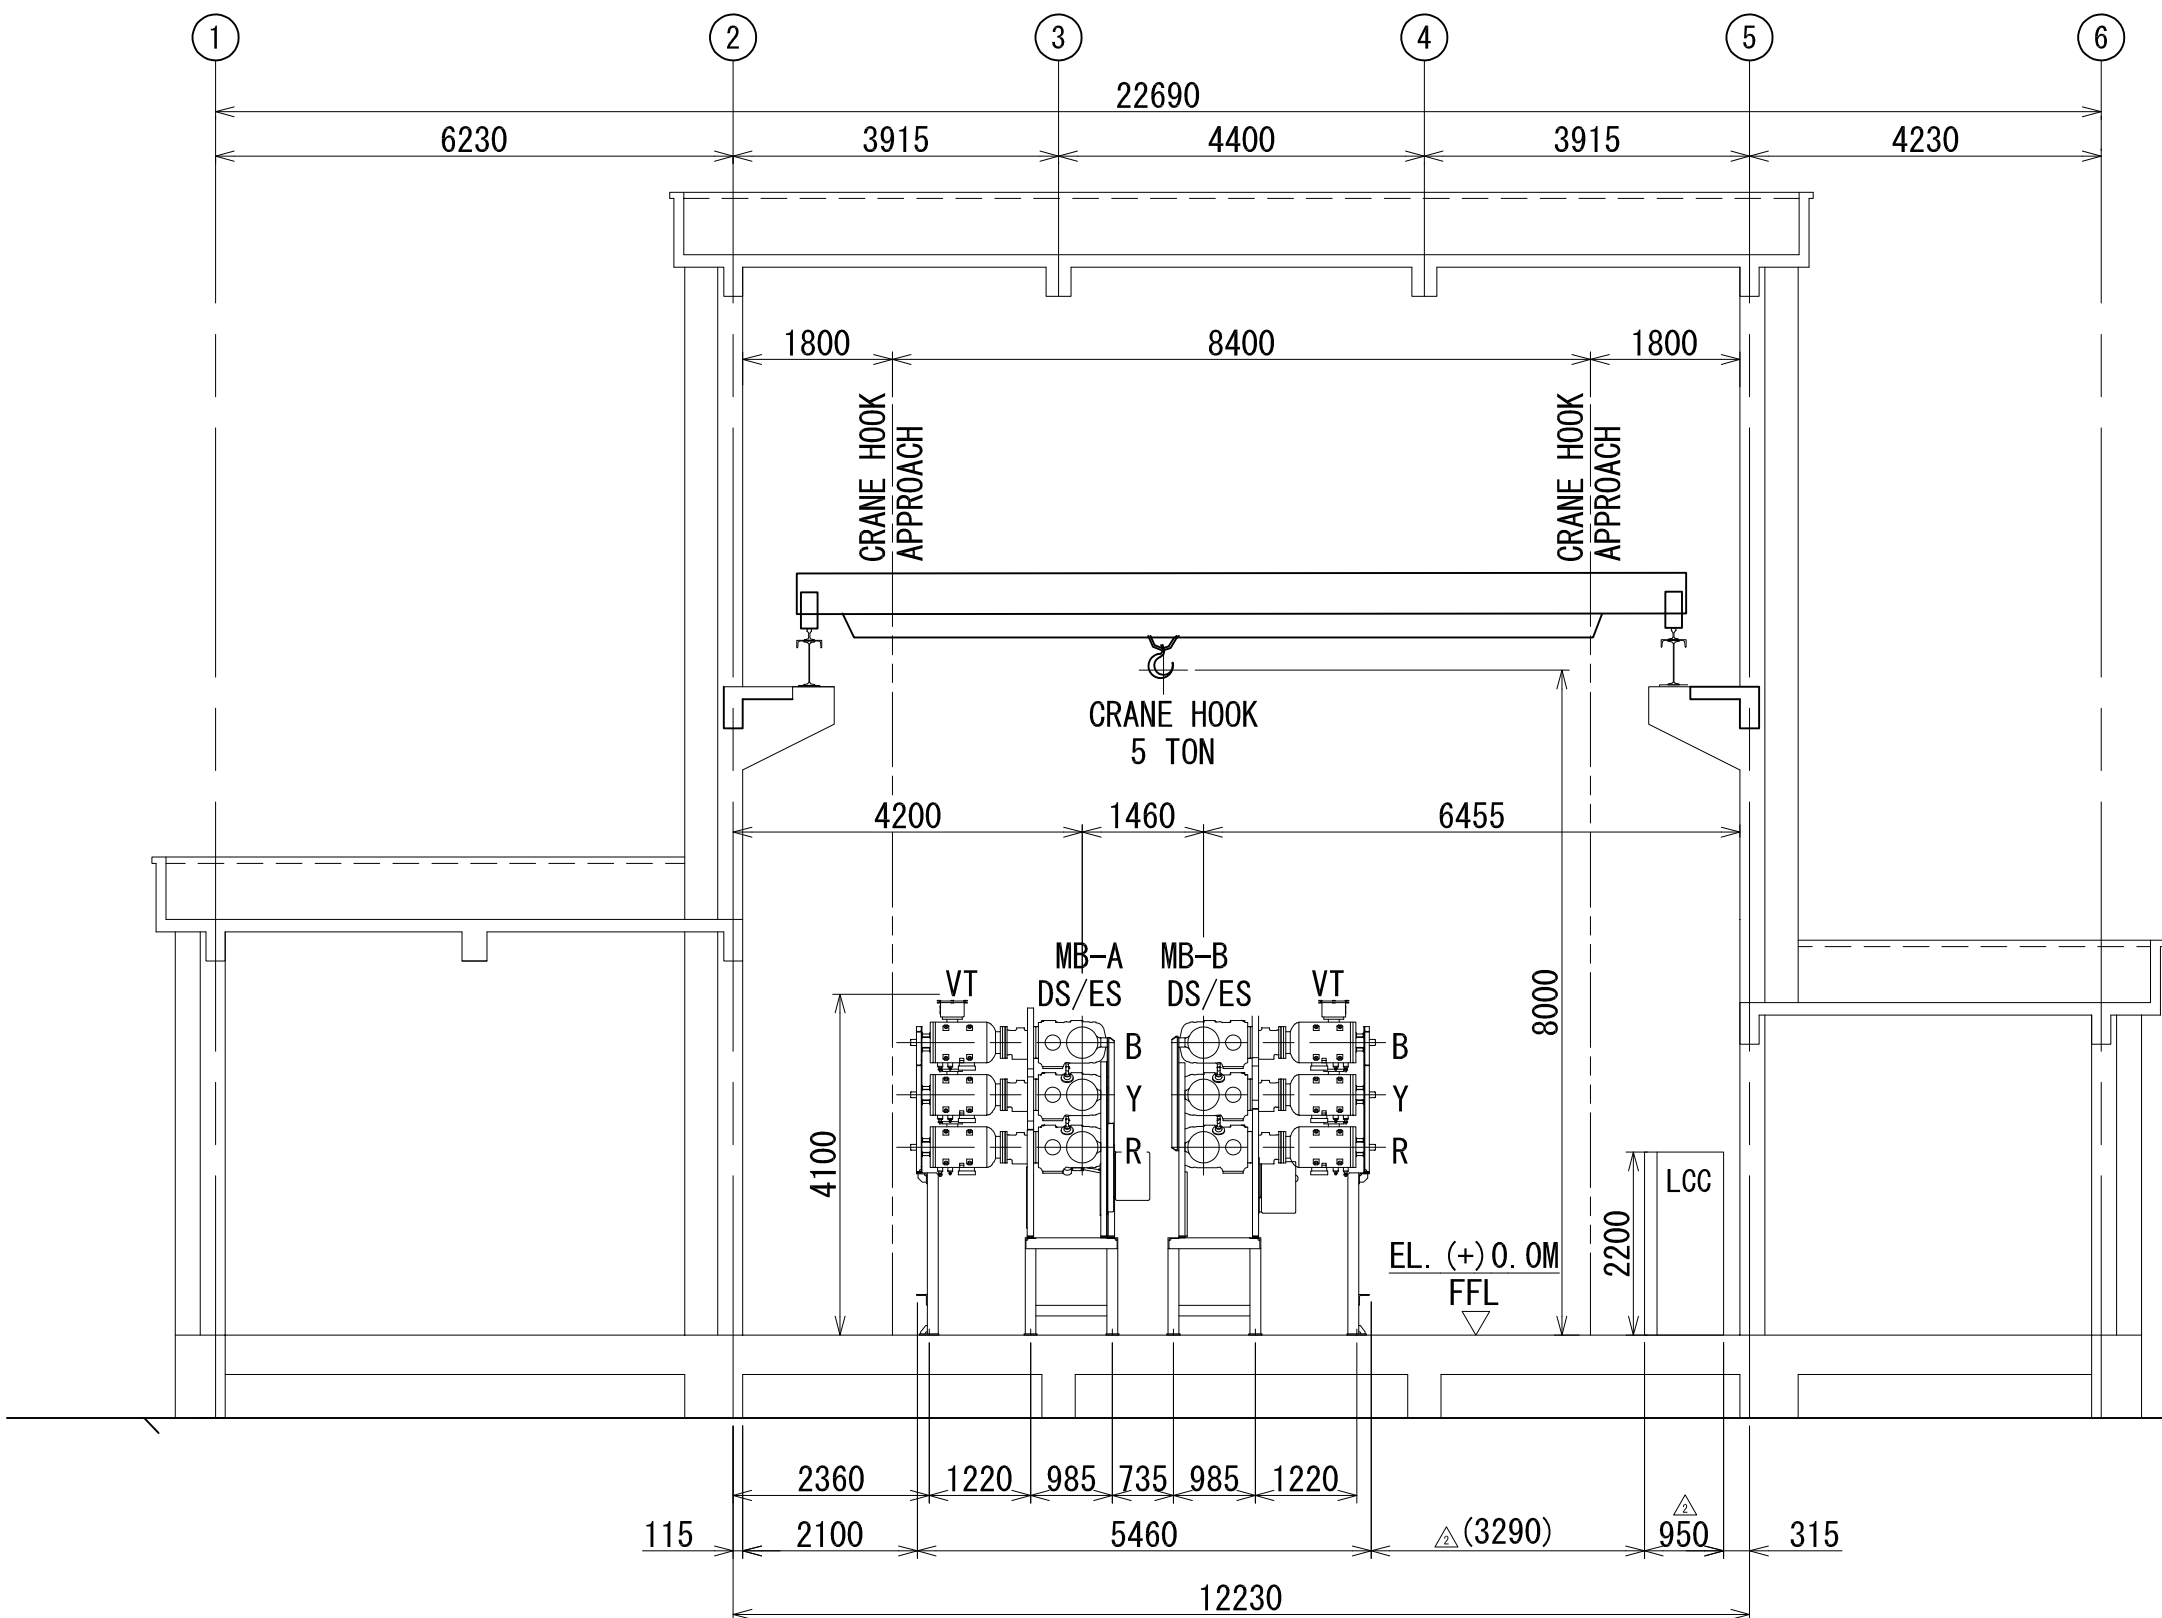




VIEW E-E
(D05)

CHECKED
[Signature]
A.G.M (Elect)
ENGG. & QUALITY
OPTCL, BHUBANESWAR

 
APPROVED
[Signature]
G.M. (Elect)
ENGG. & QUALITY
OPTCL, BHUBANESWAR

02	Y - CO-ORDINATE UPDATED AS PER BHEL COMMENT		27.02.24	SIGN	YS	SM	IK
01	UPDATED AS PER CUSTOMER COMMENTS (BAY SEQUENCE CHANGED)		20.01.24	NAME	Y. SANGEET	M. SREEDHAR	K. IKEDA
				SIGN	YS	SM	IK
REV	DETAILS OF MODIFICATION	REV. MARK	DATE	NAME	Y. SANGEET	M. SREEDHAR	K. IKEDA
				MODIFIED	CHECKED	APPROVED	
TOSHIBA TOSHIBA TRANSMISSION & DISTRIBUTION SYSTEMS (INDIA) PRIVATE LIMITED					NAME	SIGN	DATE
				DESIGNED	CH.BHAGAVAN		06.01.2024
				DRAWN	V.RAMBABU		06.01.2024
				CHECKED	M.SREEDHAR		06.01.2024
				APPROVED	K.IKEDA		06.01.2024
SCALE: 1:90	SWITCHGEAR PRODUCTS DIVISION			PRODUCT	245KV GIS		
	TITLE:	220KV GIS-GENERAL ARRANGEMENT PLAN & SECTIONS-OPTCL ERSAMA			DRAWING NO.:		
					DEDUGB168011005		
					SHEET NO. 04 OF 06 REV: 02		

 
PROJECT		400/220kV GIS SUBSTATION AT ERSAMA, ODISHA & 400kV AIS FEEDER BAY EXTENSION AT DUBURI, ODISHA											
OWNER		ODISHA POWER TRANSMISSION CORPORATION LIMITED											
OBTGM		BHARAT HEAVY ELECTRICALS LTD TRANSMISSION BUSINESS GROUP NOIDA				DEPT CODE	NAME	SIGN	DATE				
						M	DRN		06.01.2024				
							CHD		06.01.2024				
							APPD		06.01.2024				
TITLE													
220kV GIS Indoor Layout, Plan & Section													
						DEPT.	SCALE 1:100	DRAWING NO.					
						SIGN		TB-420-316-071-03A					
						DATE		SHEET	04	OF	06	REV. 02	

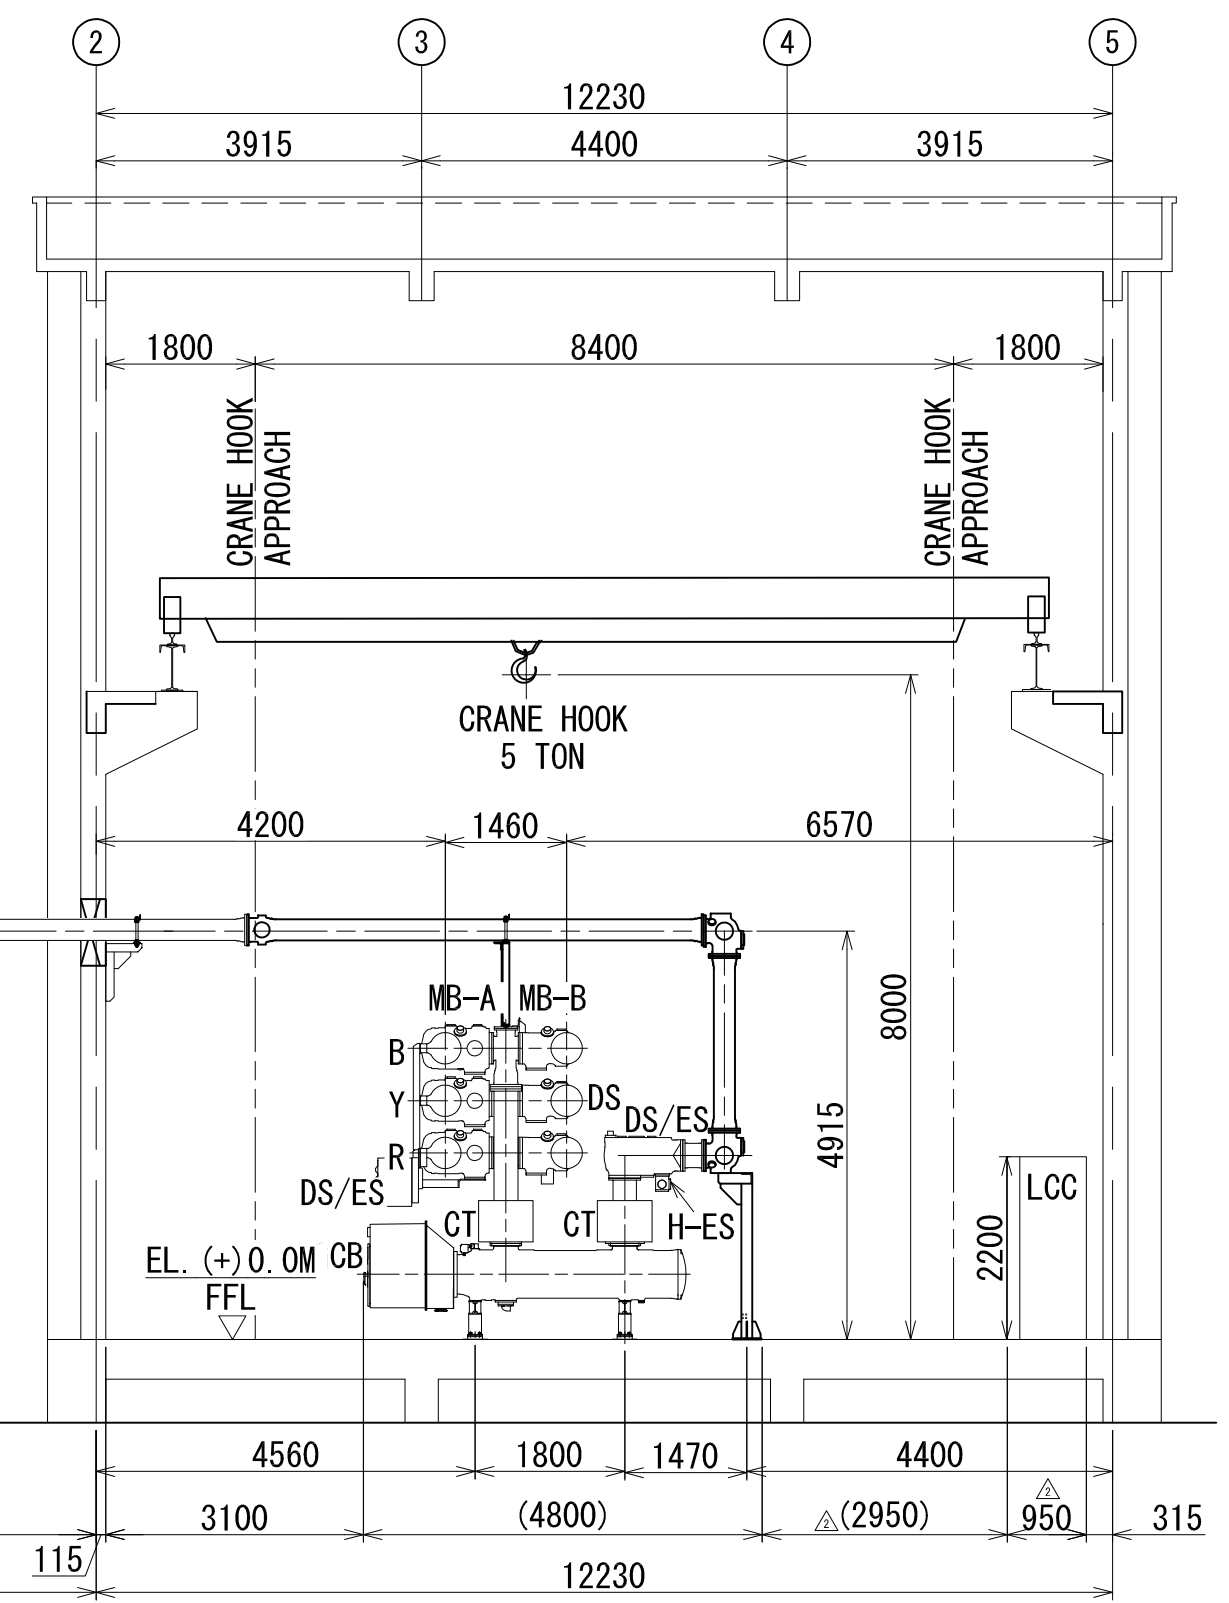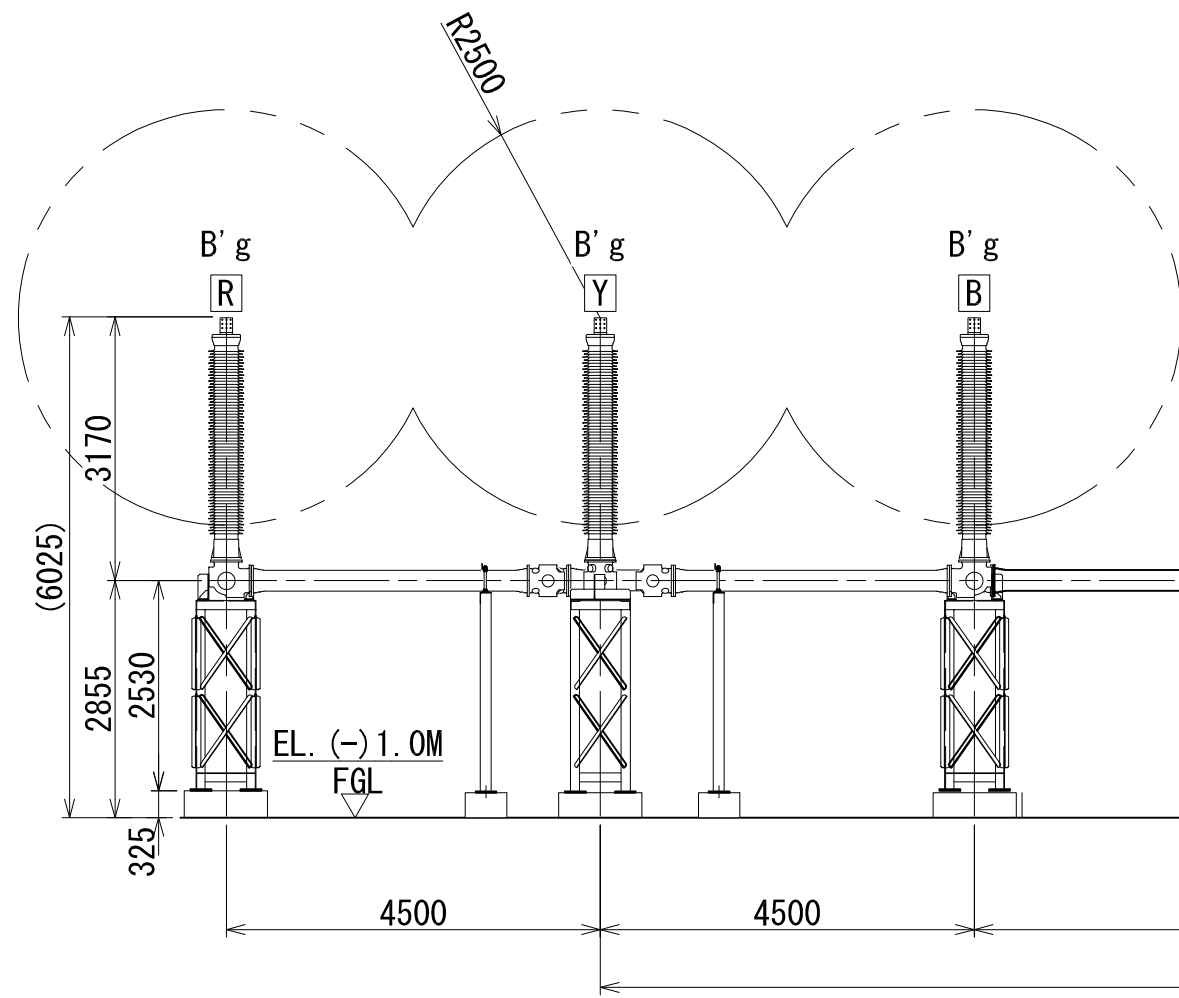

VIEW H-H
(D08)

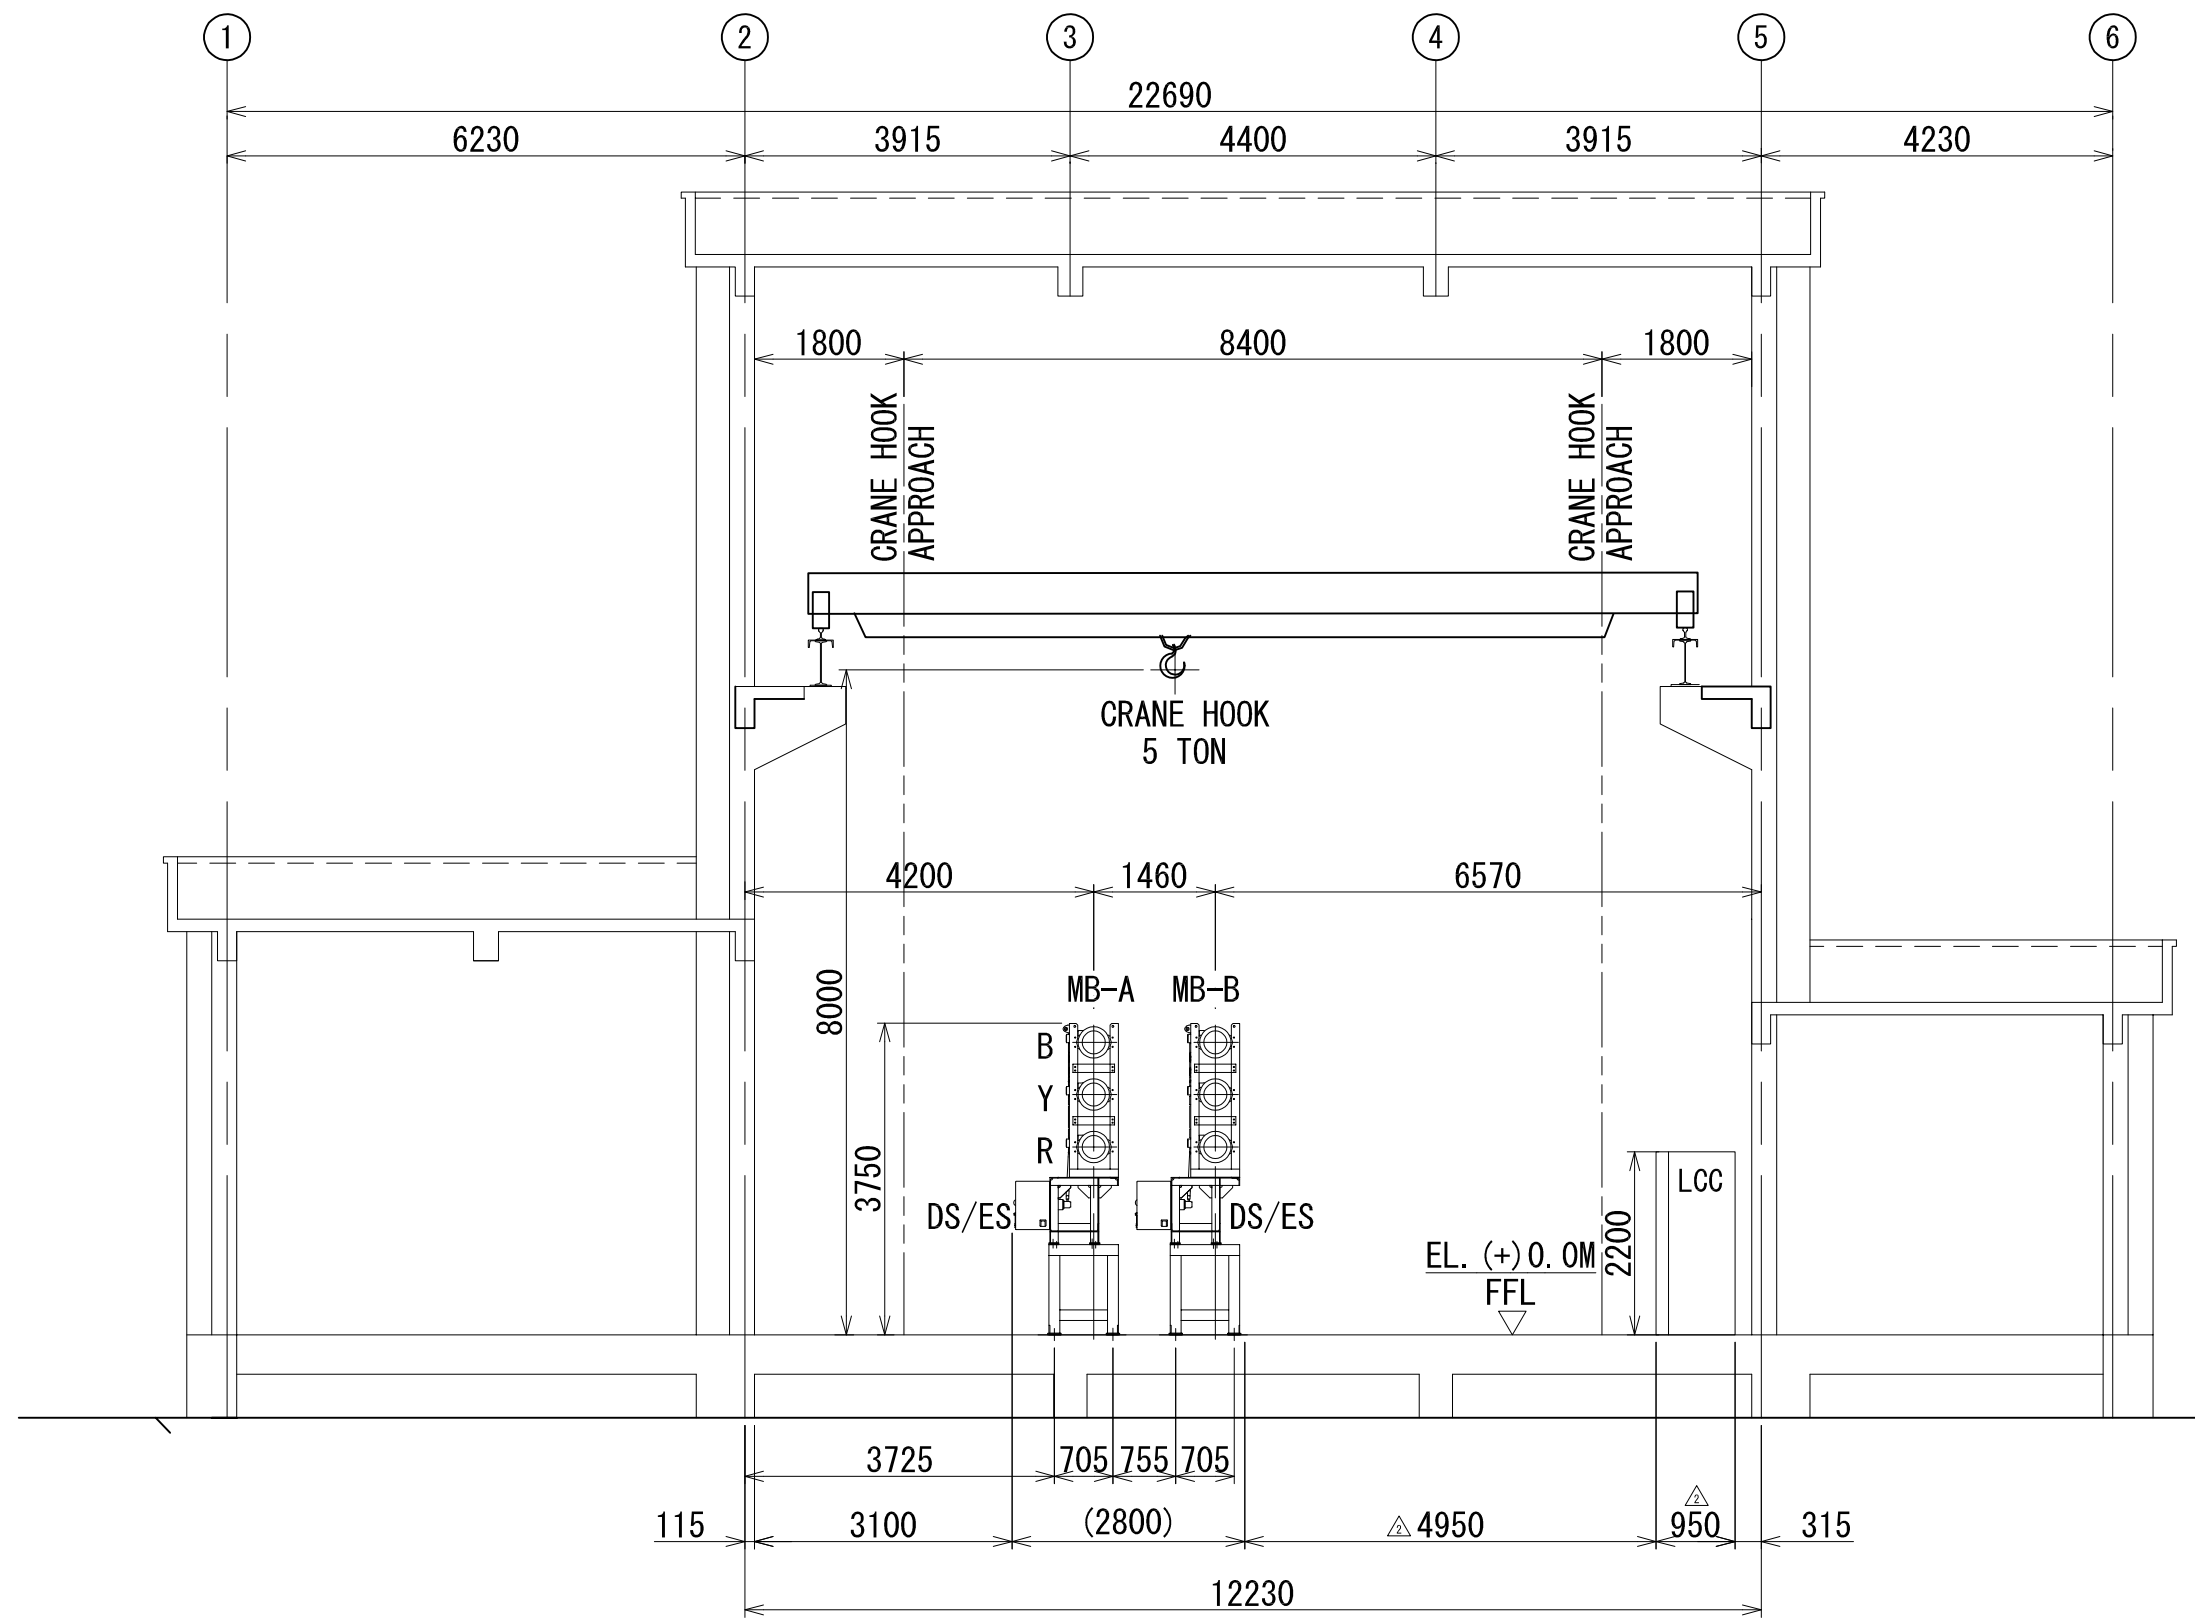



VIEW I-I
(D09)

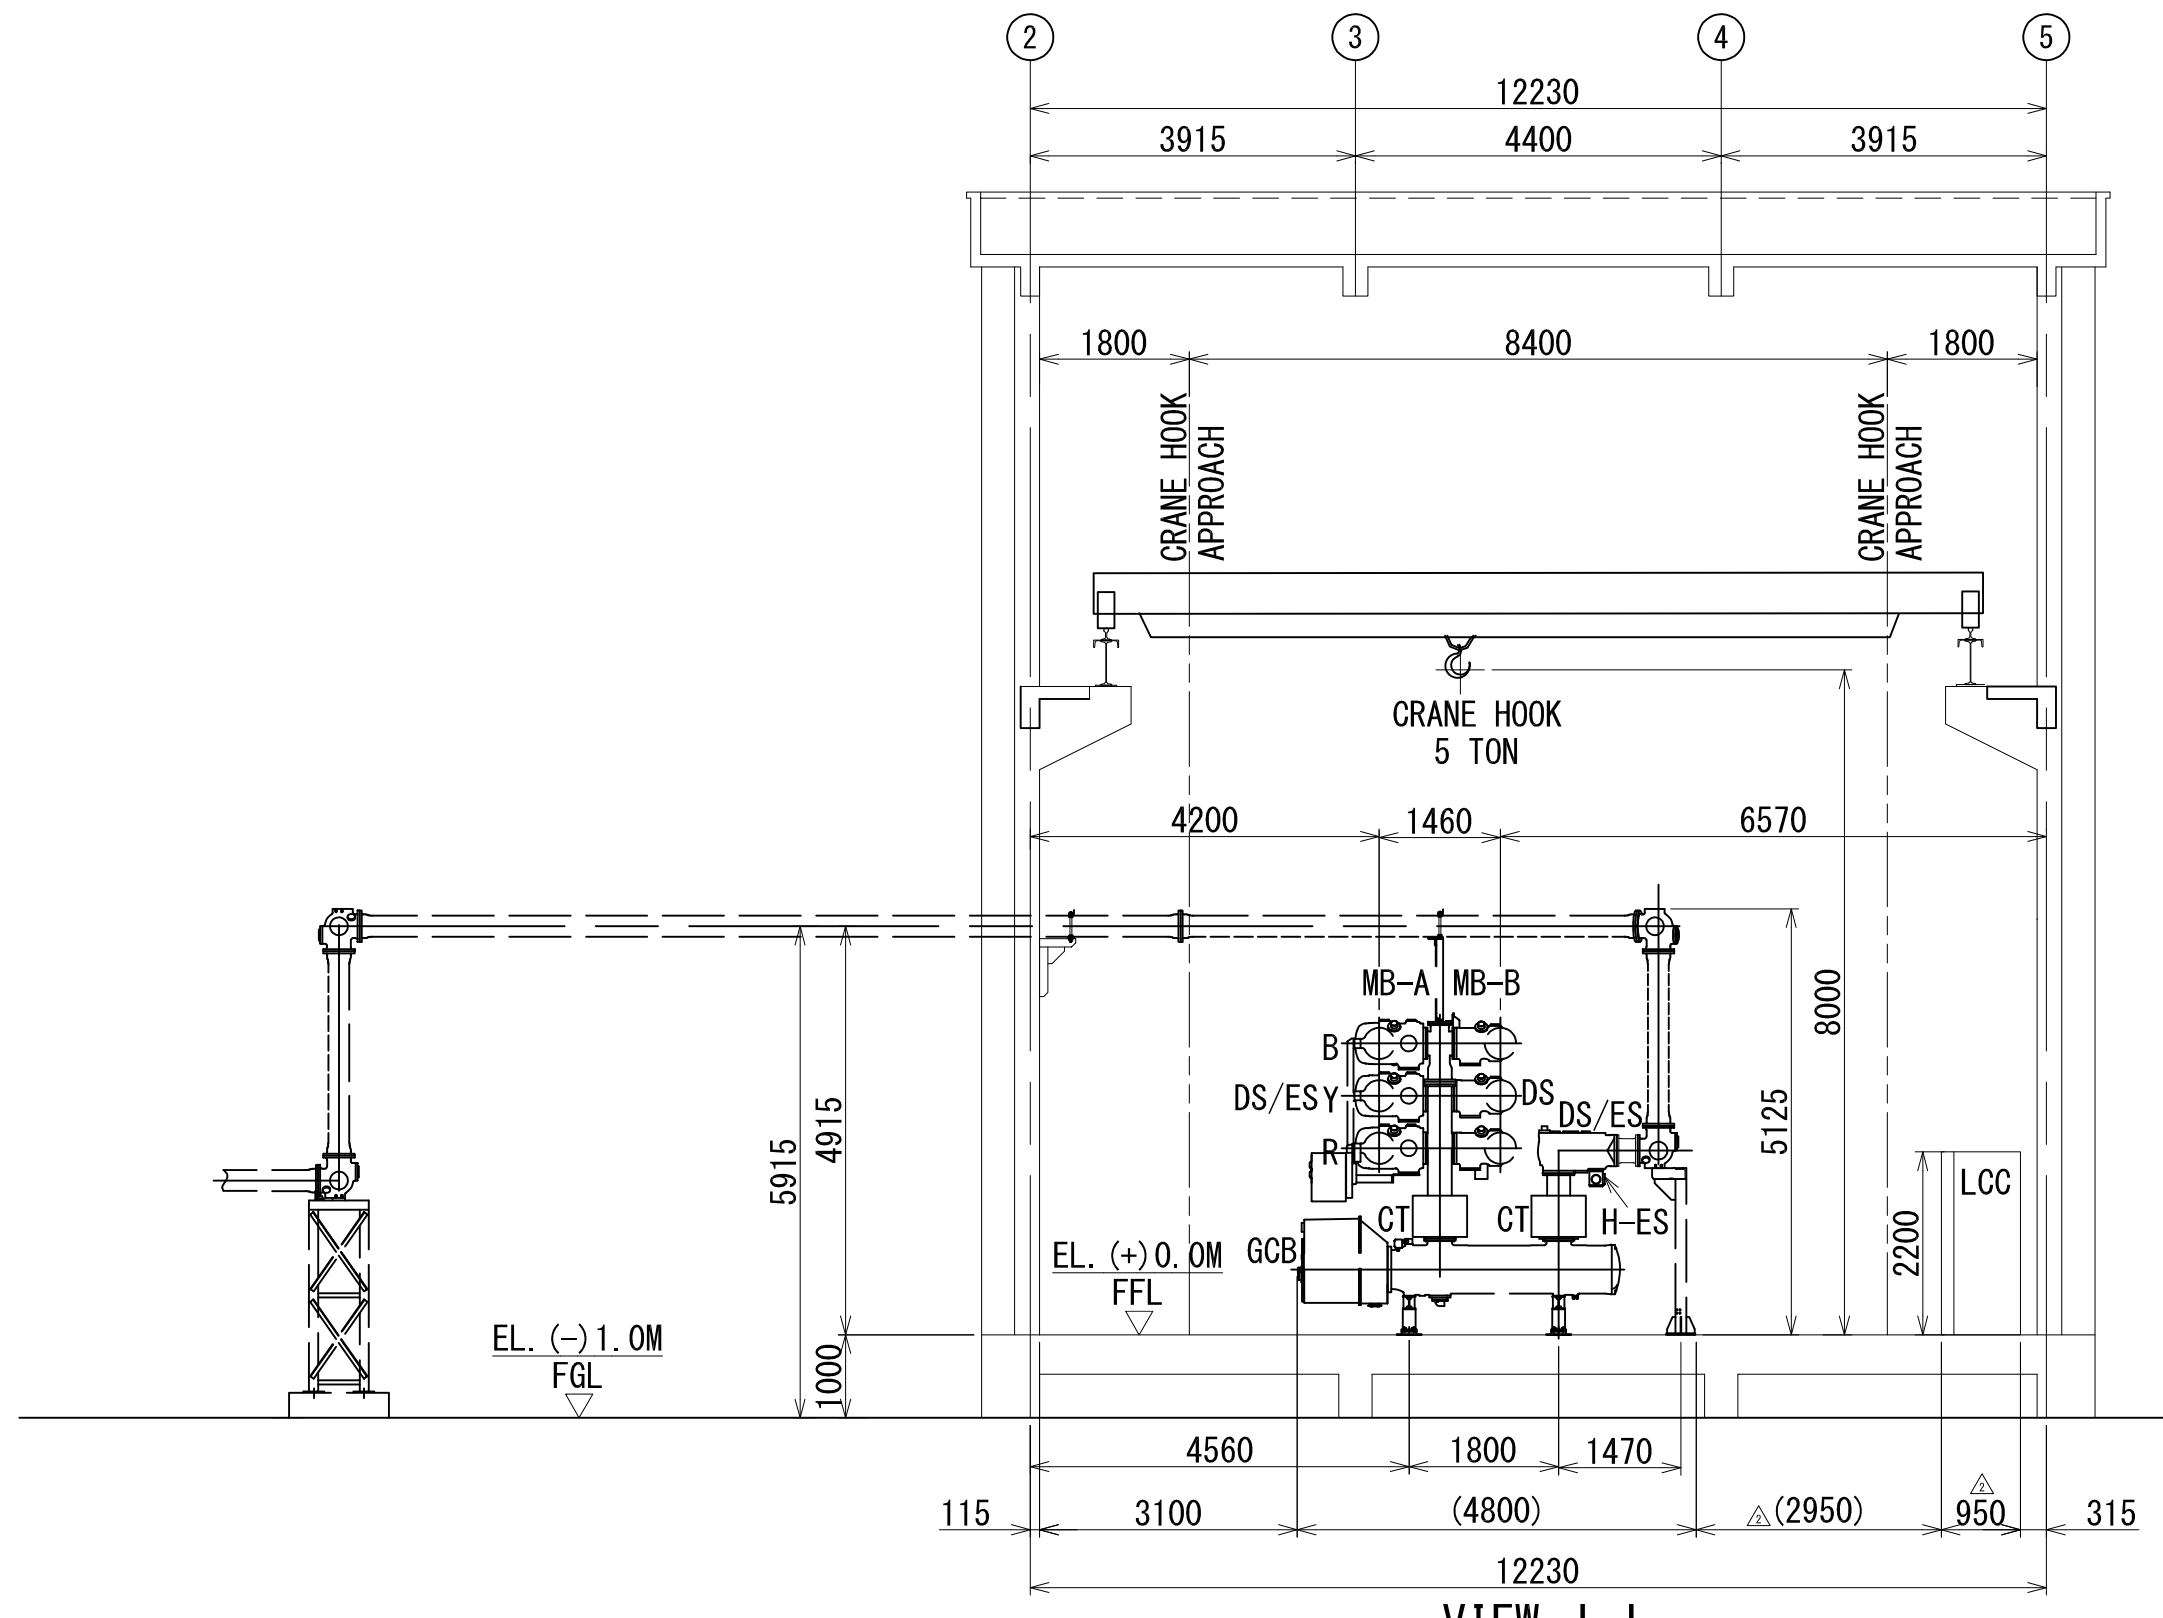


VIEW J-J
(FUTURE)

CHECKED
[Signature]
A.G.M (Elect)
ENGG. & QUALITY
OPTCL, BHUBANESWAR

  APPROVED
[Signature]
G.M. (Elect)
ENGG. & QUALITY
OPTCL, BHUBANESWAR

02		Y - CO-ORDINATE UPDATED AS PER BHEL COMMENT			27.02.24	SIGN		YS	SM	IK
						NAME		Y. SANDEEP	M. SREEDHAR	K. IKEDA
01		UPDATED AS PER CUSTOMER COMMENTS (BAY SEQUENCE CHANGED)			20.01.24	SIGN		YS	SM	IK
						NAME		Y. SANDEEP	M. SREEDHAR	K. IKEDA
REV	DETAILS OF MODIFICATION			REV. MARK	DATE	MODIFIED		CHECKED	APPROVED	
						NAME		SIGN	DATE	
						DESIGNED		CH.BHAGAVAN	06.01.2024	
						DRAWN		Y.RAMBABU	06.01.2024	
						CHECKED		M.SREEDHAR	06.01.2024	
						APPROVED		K.IKEDA	06.01.2024	
						PRODUCT		245W GIS		
						DRAWING NO.:		DEDUGB168011005		
						SHEET NO.:		06	OF	06
						REV.:		02		
SCALE: 1:90		SWITCHGEAR PRODUCTS DIVISION								
		TITLE:				220kV GIS-GENERAL ARRANGEMENT PLAN & SECTIONS-OPTCL ERSAMA				
						220kV GIS Indoor Layout, Plan & Section				
						DEPT.		SCALE: 1:100	DRAWING NO.	
						SIGN		TB-420-316-071-03A		
						DATE			SHEET 06 OF 06	
										REV. 02

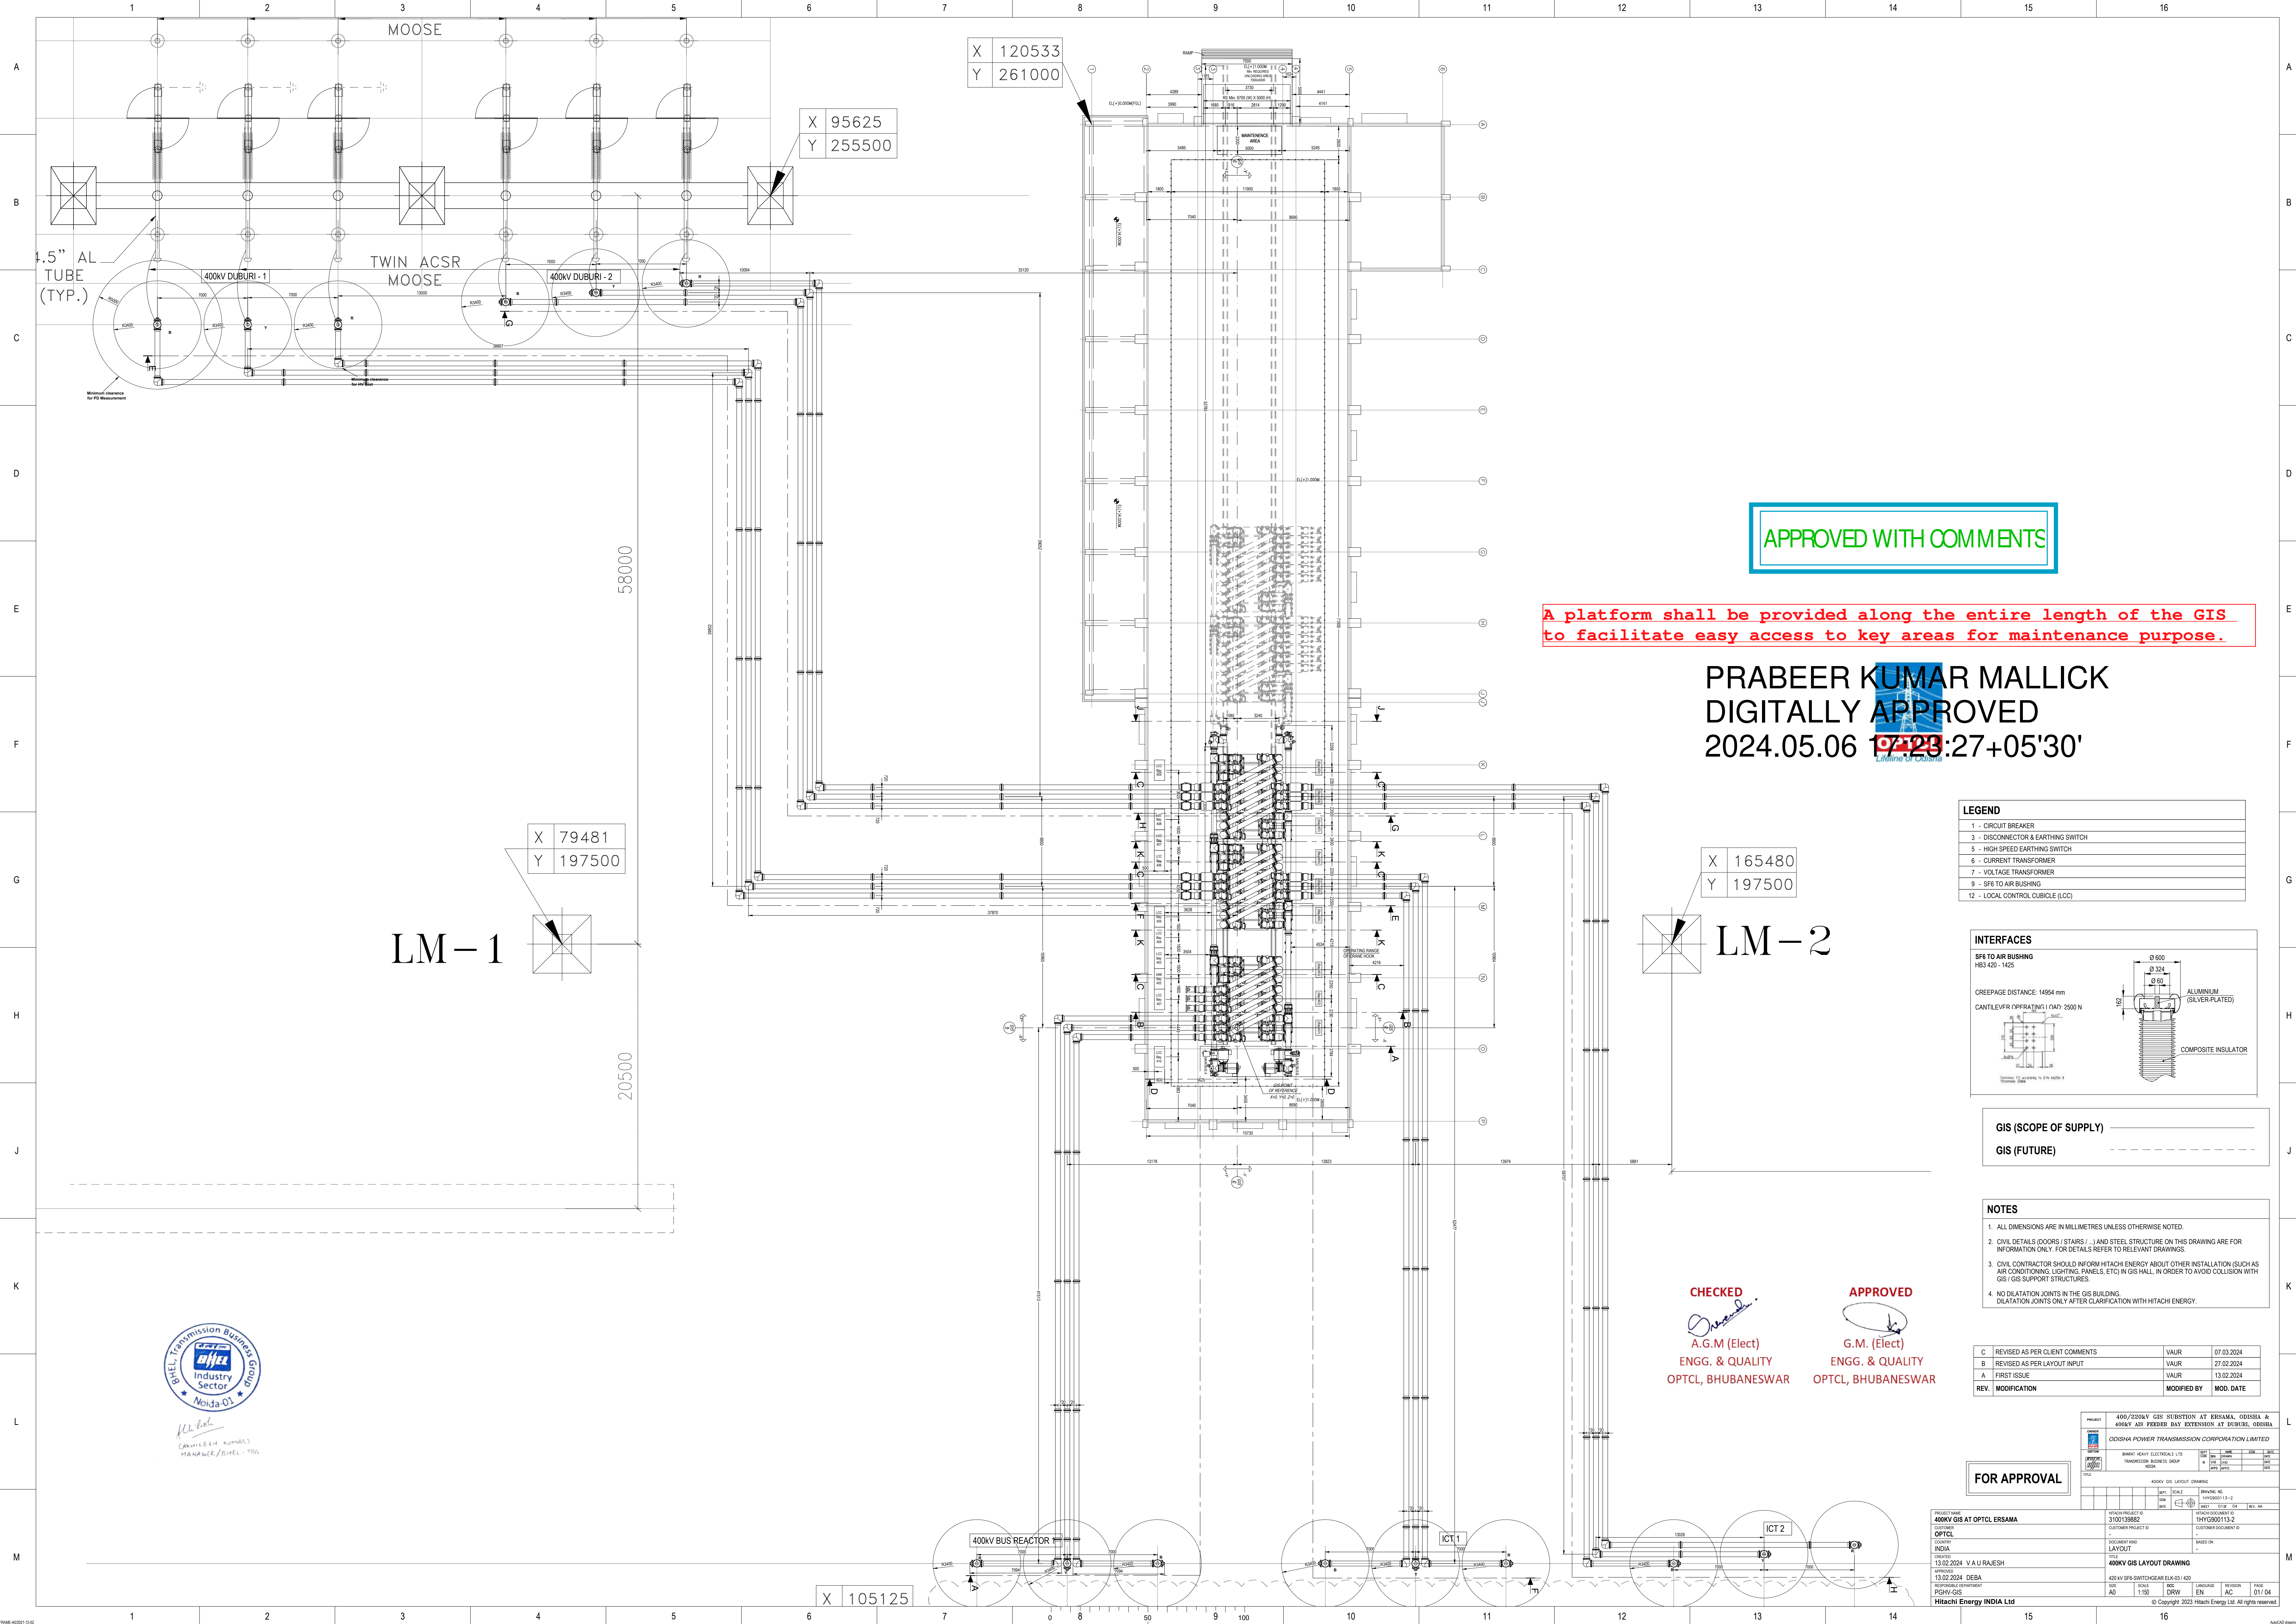

APPROVED WITH COMMENTS

A platform shall be provided along the entire length of the GIS to facilitate easy access to key areas for maintenance purpose.

PRABEER KUMAR MALLICK
DIGITALLY APPROVED
2024.05.06 17:23:27+05'30'

LEGEND	
1	CIRCUIT BREAKER
3	DISCONNECTOR & EARTHING SWITCH
5	HIGH SPEED EARTHING SWITCH
6	CURRENT TRANSFORMER
7	VOLTAGE TRANSFORMER
9	SF6 TO AIR BUSHING
12	LOCAL CONTROL CUBICLE (LCC)

INTERFACES

SF6 TO AIR BUSHING
HB3 420 - 1425

CREEPAGE DISTANCE: 14954 mm

CANTILEVER OPERATING (OAT: 2600 N)

ALUMINUM (SILVER-PLATED)

COMPOSITE INSULATOR

GIS (SCOPE OF SUPPLY)	_____
GIS (FUTURE)	_____

- NOTES
1. ALL DIMENSIONS ARE IN MILLIMETRES UNLESS OTHERWISE NOTED.

2. CIVIL DETAILS (DOORS / STAIRS /) AND STEEL STRUCTURE ON THIS DRAWING ARE FOR INFORMATION ONLY. FOR DETAILS REFER TO RELEVANT DRAWINGS.

3. CIVIL CONTRACTOR SHOULD INFORM HITACHI ENERGY ABOUT OTHER INSTALLATION (SUCH AS AIR CONDITIONING, LIGHTING, PANELS, ETC) IN GIS HALL, IN ORDER TO AVOID COLLISION WITH GIS / GIS SUPPORT STRUCTURES.

4. NO DILATATION JOINTS IN THE GIS BUILDING. DILATATION JOINTS ONLY AFTER CLARIFICATION WITH HITACHI ENERGY.

C	REVISED AS PER CLIENT COMMENTS	VAUR	07.03.2024
B	REVISED AS PER LAYOUT INPUT	VAUR	27.02.2024
A	FIRST ISSUE	VAUR	13.02.2024
REV.	MODIFICATION	MODIFIED BY	MOD. DATE

FOR APPROVAL

PROJECT NAME 400KV GIS AT OPTCL ERSAMA	HITACHI PROJECT ID 3100139882	DRAWING NO. 1HYG600113-2
CLIENT OPTCL	CLIENT PROJECT ID -	CLIENT DOCUMENT ID -
COUNTRY INDIA	DOCUMENT TYPE LAYOUT	BASED ON -
CREATED 13.02.2024 V A U RAJESH	400KV GIS LAYOUT DRAWING	
APPROVED 13.02.2024 DEBA		
SUPPLIER/DRYDRAFT PGHV-GIS		
HITACHI Energy INDIA Ltd		

PROJECT	400/220KV GIS SUBSTATION AT ERSAMA, ODISHA & 400KV AIR PRESSURE BAY EXTENSION AT PRIBING, ODISHA.
CLIENT	SHRI RAVI ELECTRICITY LTD
DESIGN	TRANSMISSION BUSINESS GROUP
DATE	13.02.2024
BY	VAUR
CHECKED	VAUR
APPROVED	VAUR




(PRABEER KUMAR)
MANAGER/BHEL-TBG

CHECKED
[Signature]
A.G.M (Elect)
ENGG. & QUALITY
OPTCL, BHUBANESWAR


APPROVED
[Signature]
G.M. (Elect)
ENGG. & QUALITY
OPTCL, BHUBANESWAR

X 105125

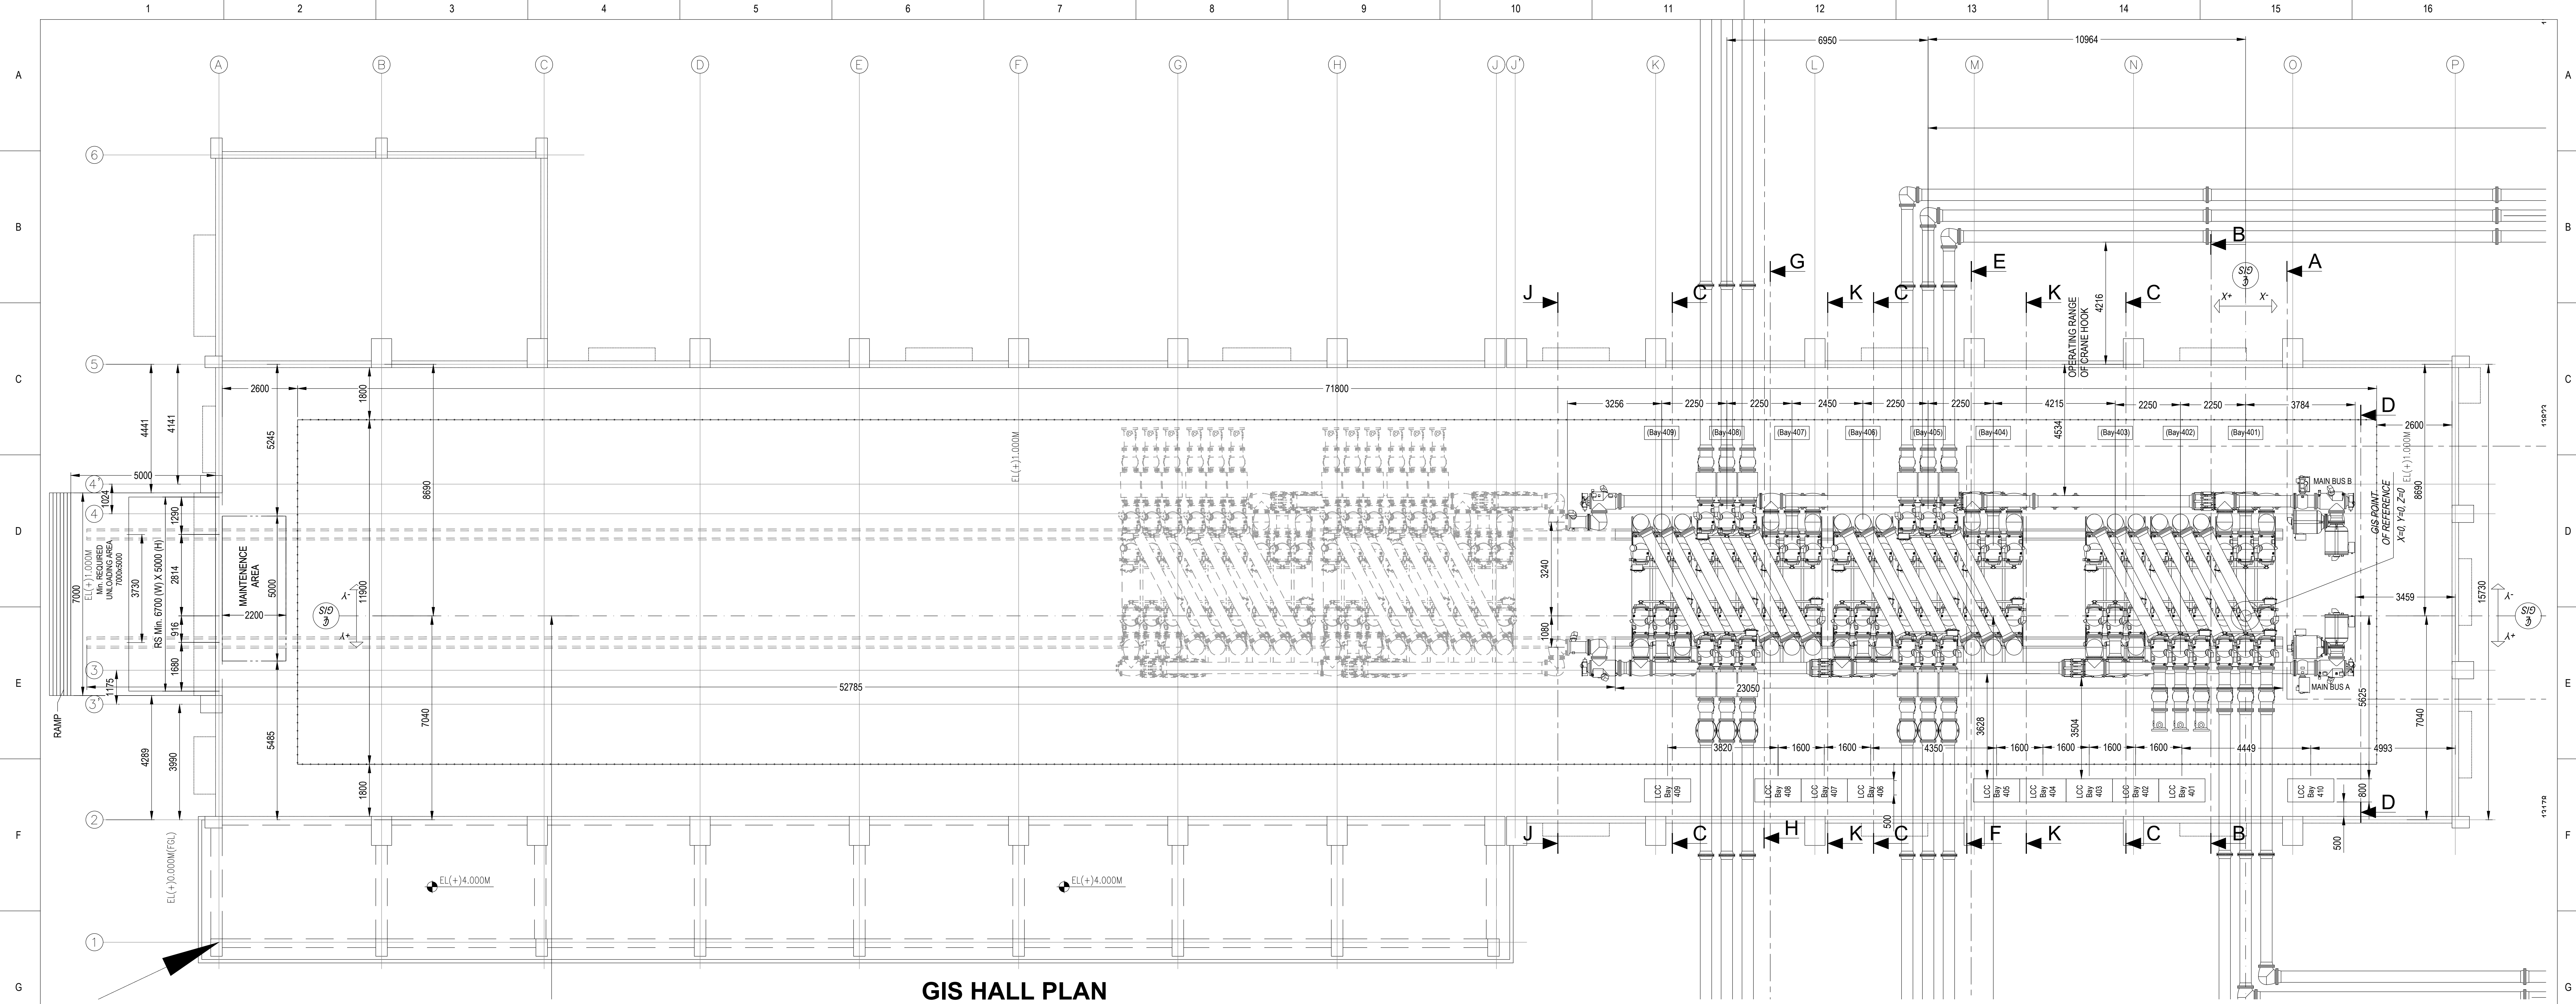

GIS HALL PLAN

SECTION G-G

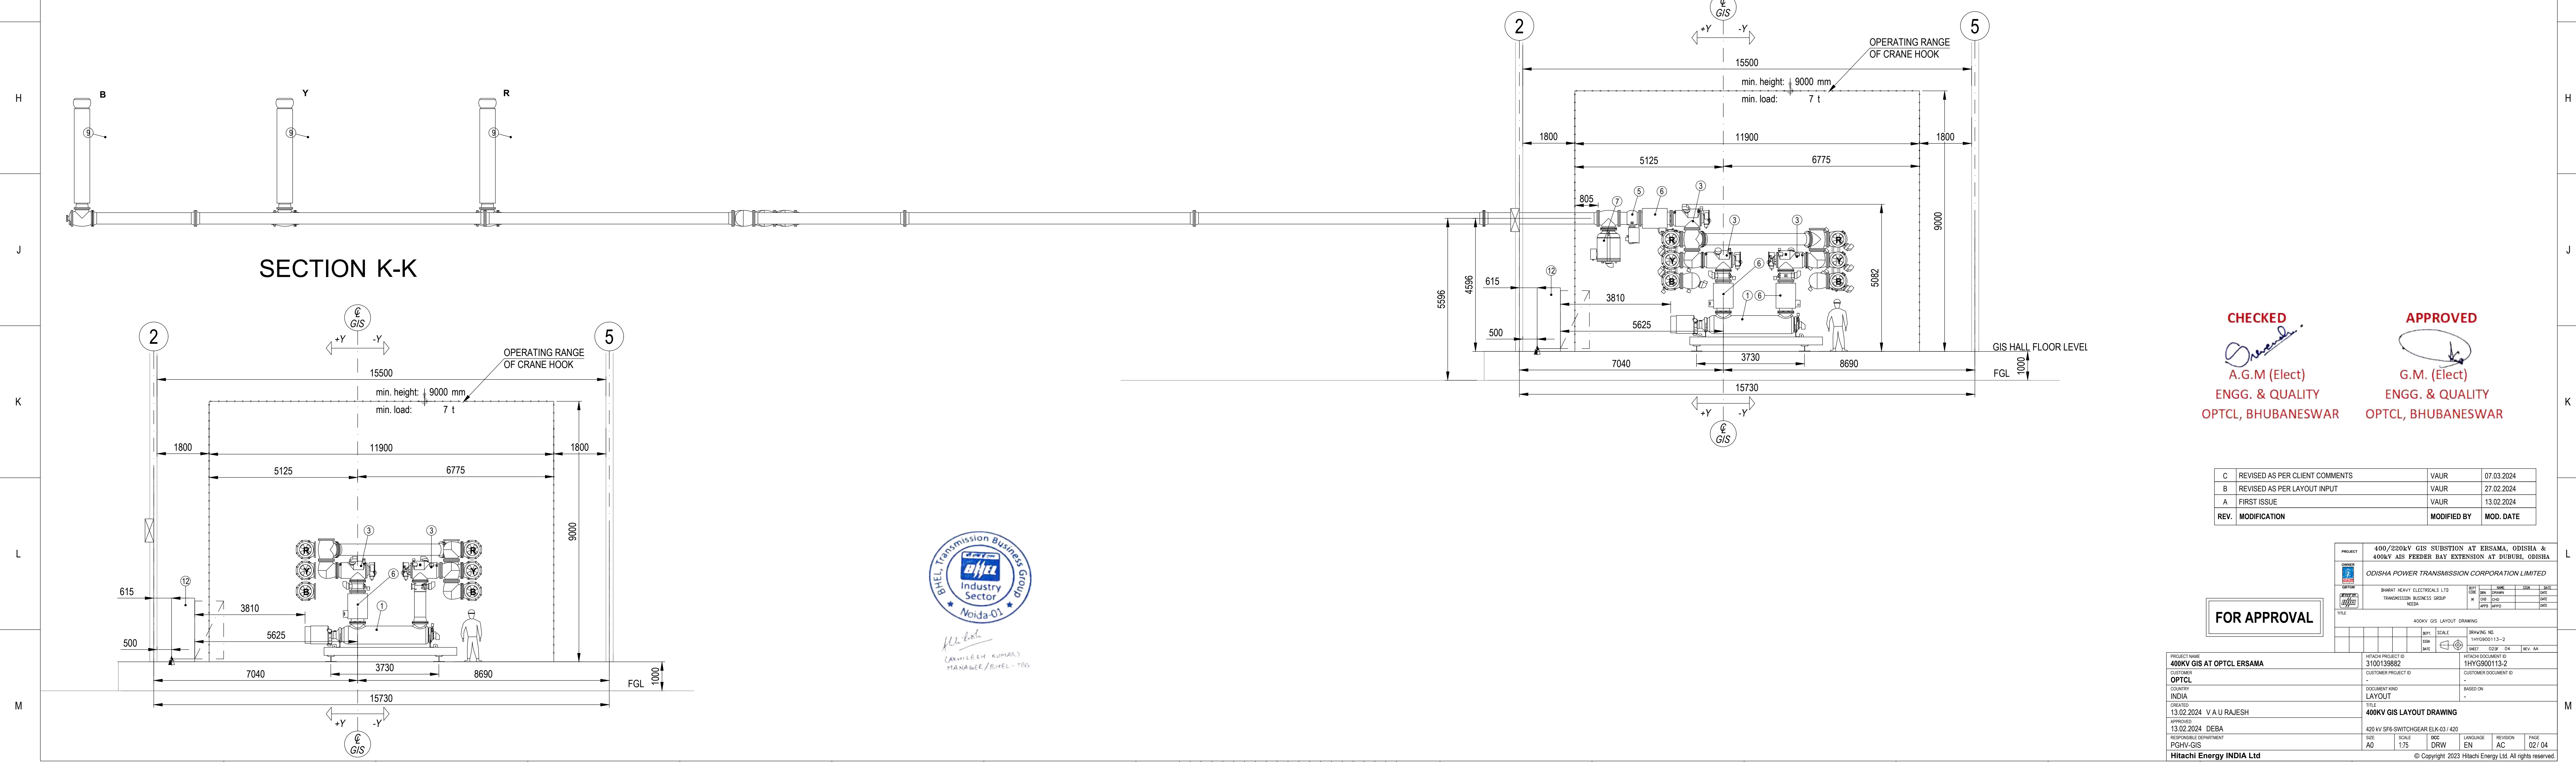

SECTION K-K

CHECKED
A.G.M (Elect)
ENGG. & QUALITY
OPTCL, BHUBANESWAR

APPROVED
G.M. (Elect)
ENGG. & QUALITY
OPTCL, BHUBANESWAR

C	REVISED AS PER CLIENT COMMENTS	VAUR	07.03.2024
B	REVISED AS PER LAYOUT INPUT	VAUR	27.02.2024
A	FIRST ISSUE	VAUR	13.02.2024
REV.	MODIFICATION	MODIFIED BY	MOD. DATE


FOR APPROVAL

PROJECT NAME	400KV GIS AT OPTCL ERSAMA	PROJECT ID	3100139882	PROJECT CODE	1HYG00113-2
CUSTOMER	OPTCL	CUSTOMER PROJECT ID		CUSTOMER DOCUMENT ID	
COUNTRY	INDIA	DOCUMENT TYPE	LAYOUT	BASED ON	
DATE	13.02.2024	DATE	13.02.2024	DATE	13.02.2024
APPROVED	13.02.2024	DATE	13.02.2024	DATE	13.02.2024
REVISION/REVISION	PGH-GIS	SCALE	1:75	SCALE	1:75
HITACHI ENERGY INDIA Ltd		SCALE	1:75	SCALE	1:75





MANAGER/BHEL-105

SECTION D-D

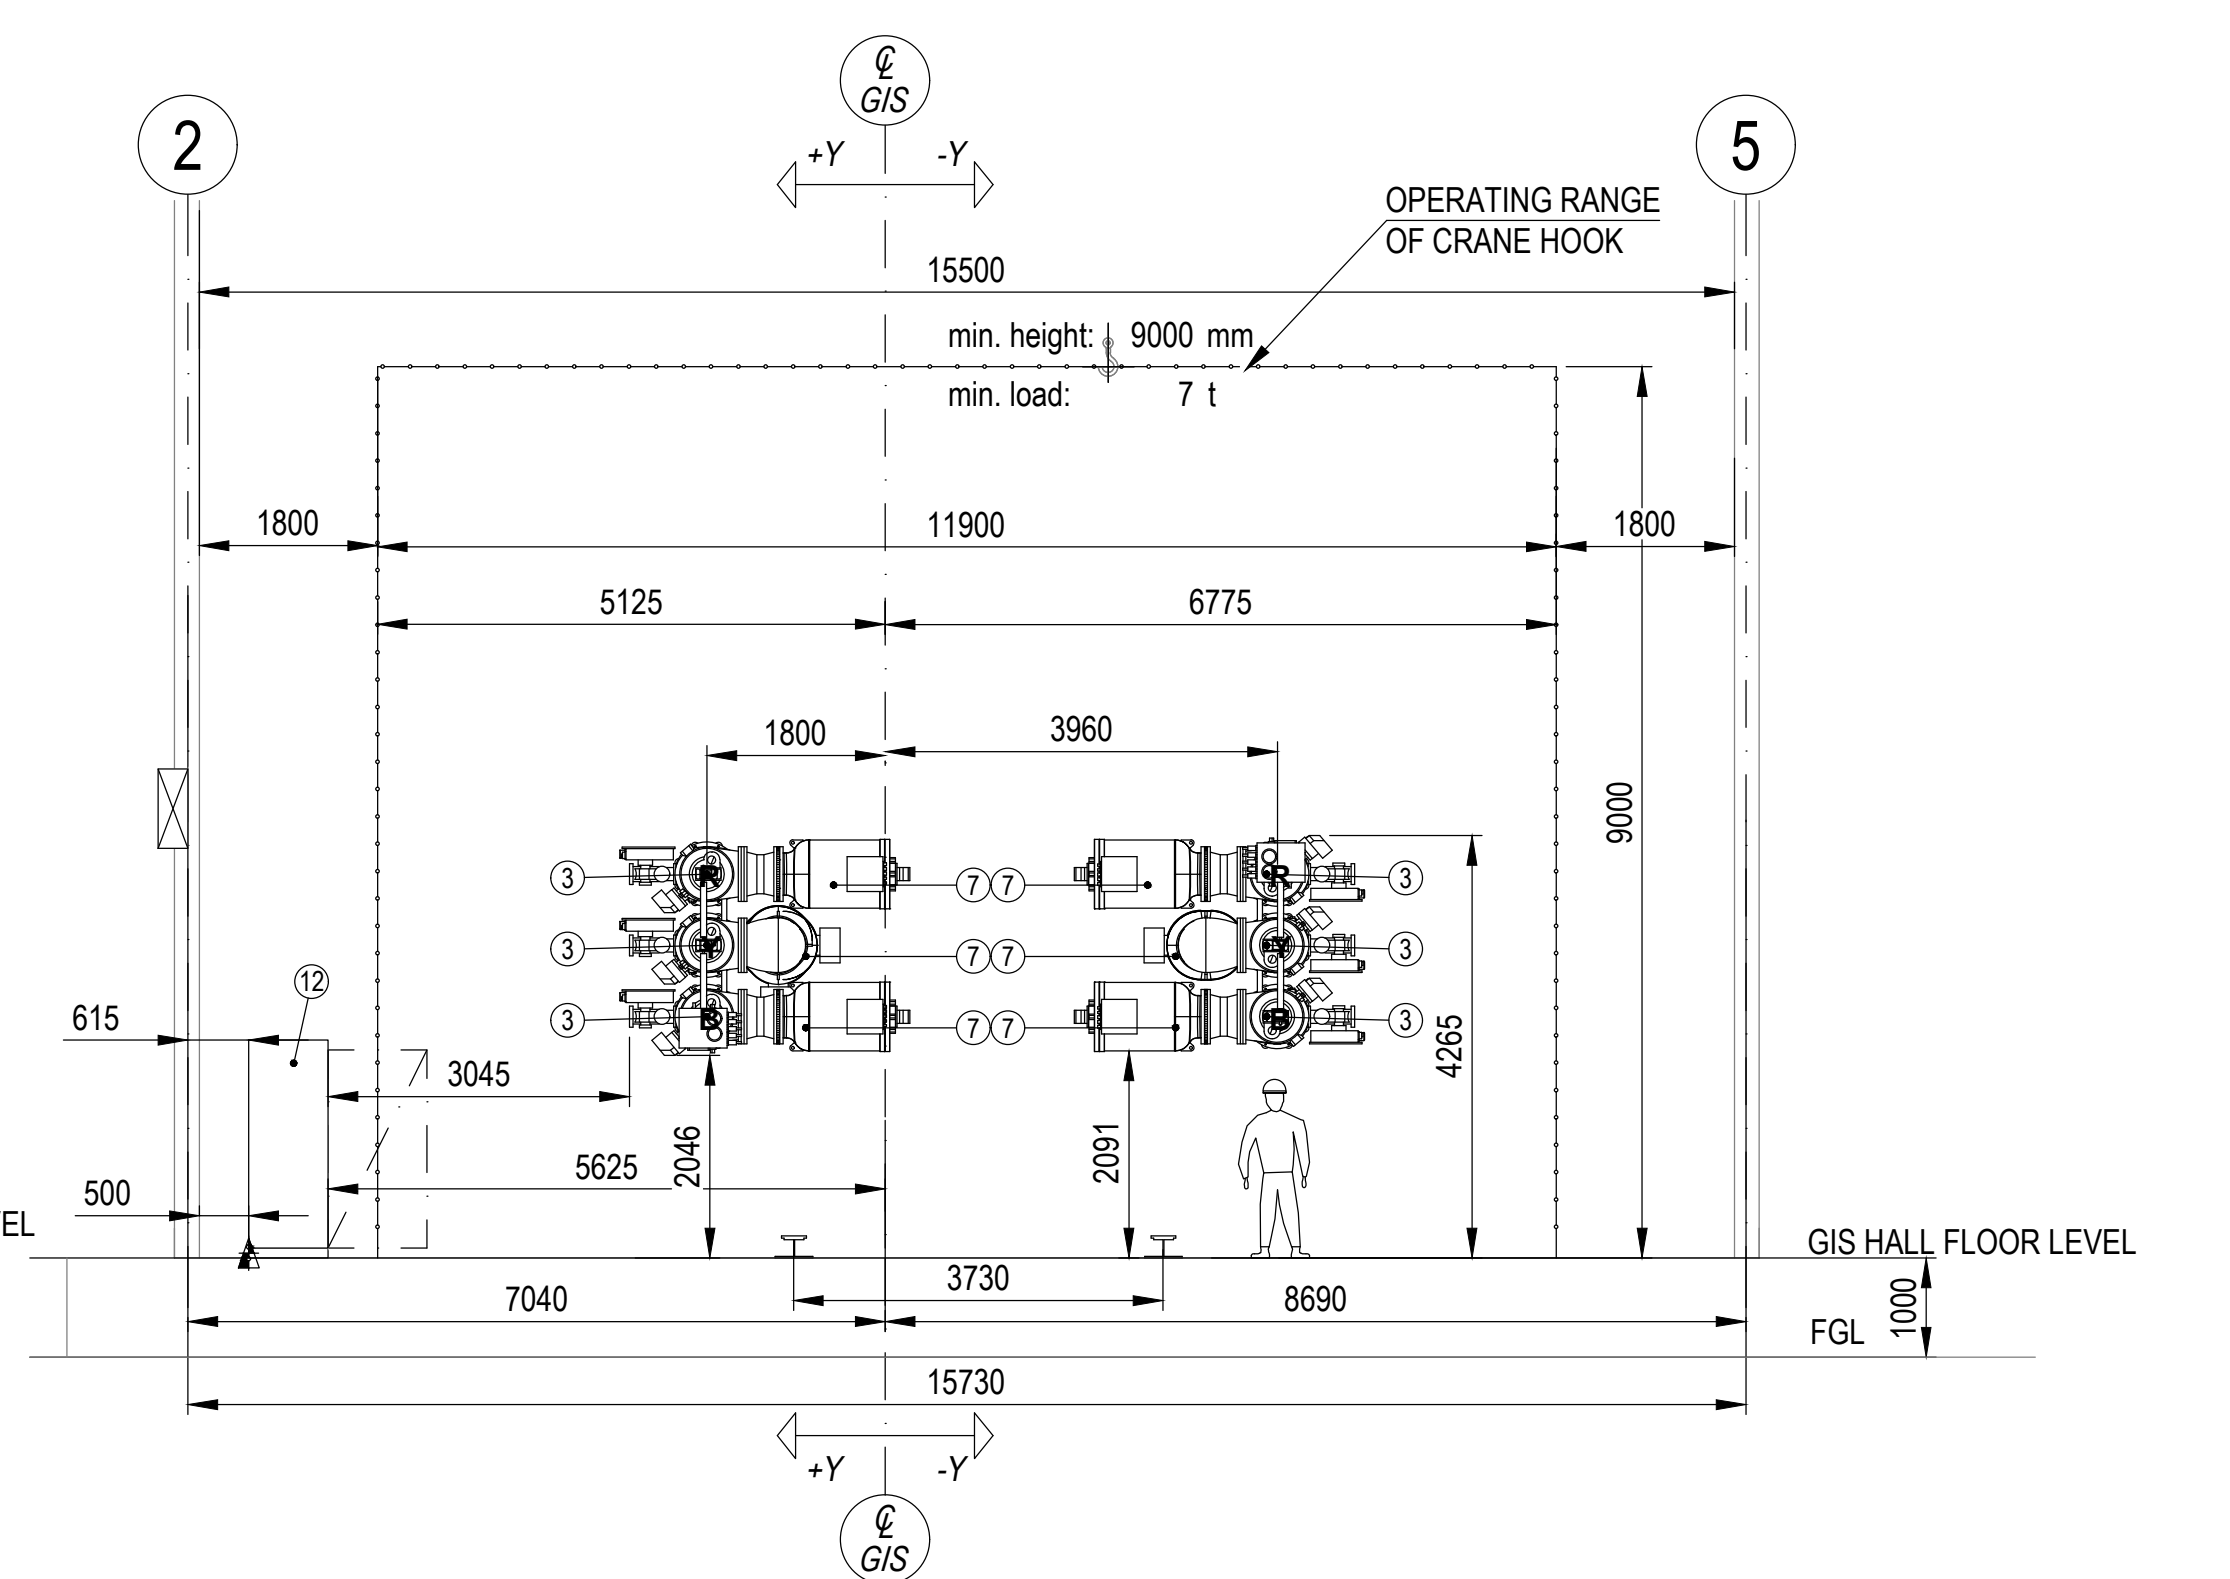

SECTION F-F

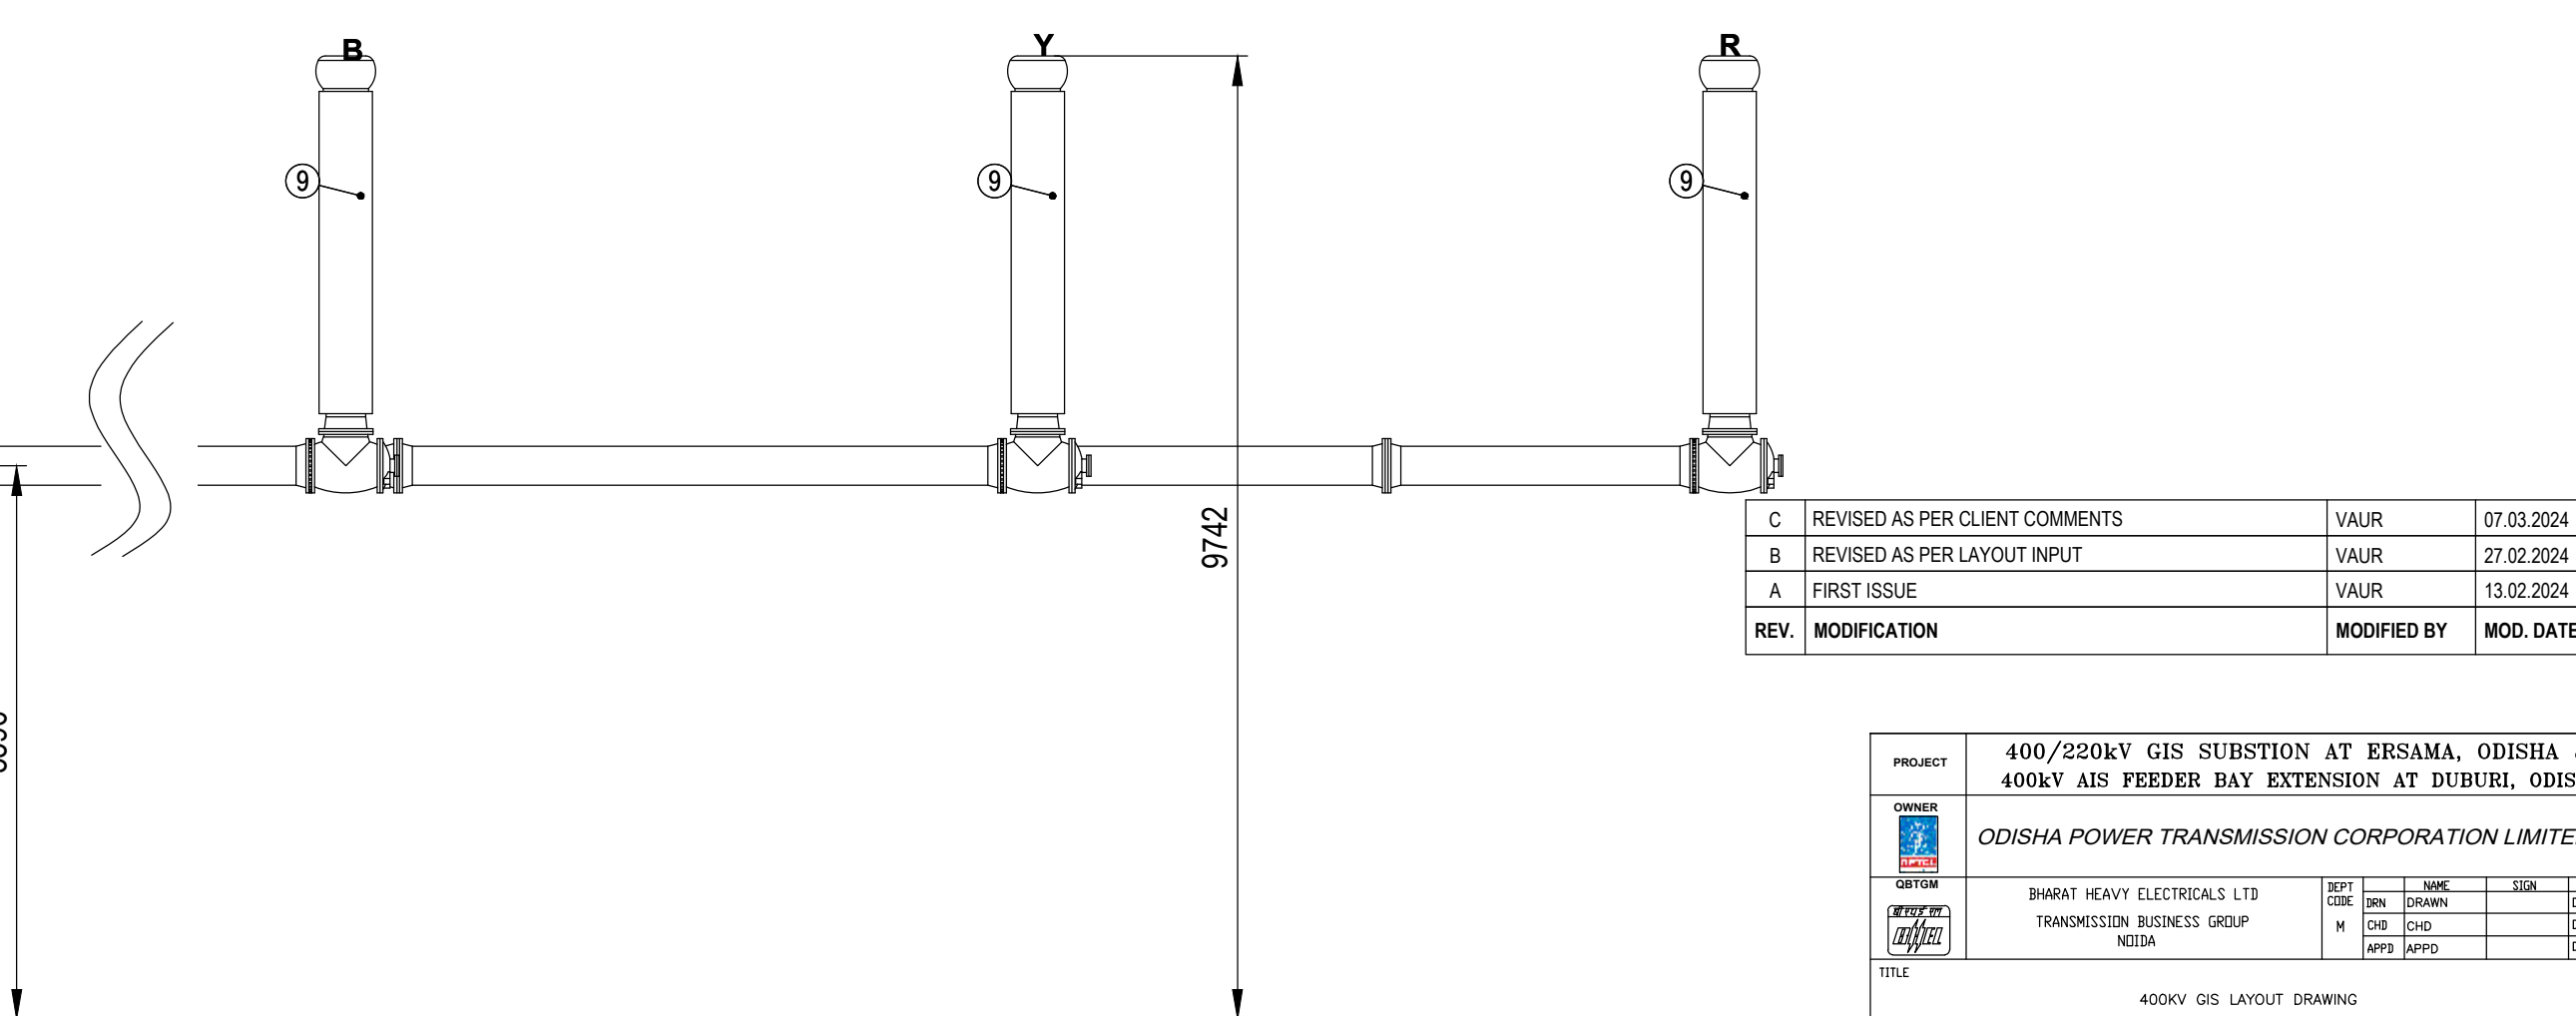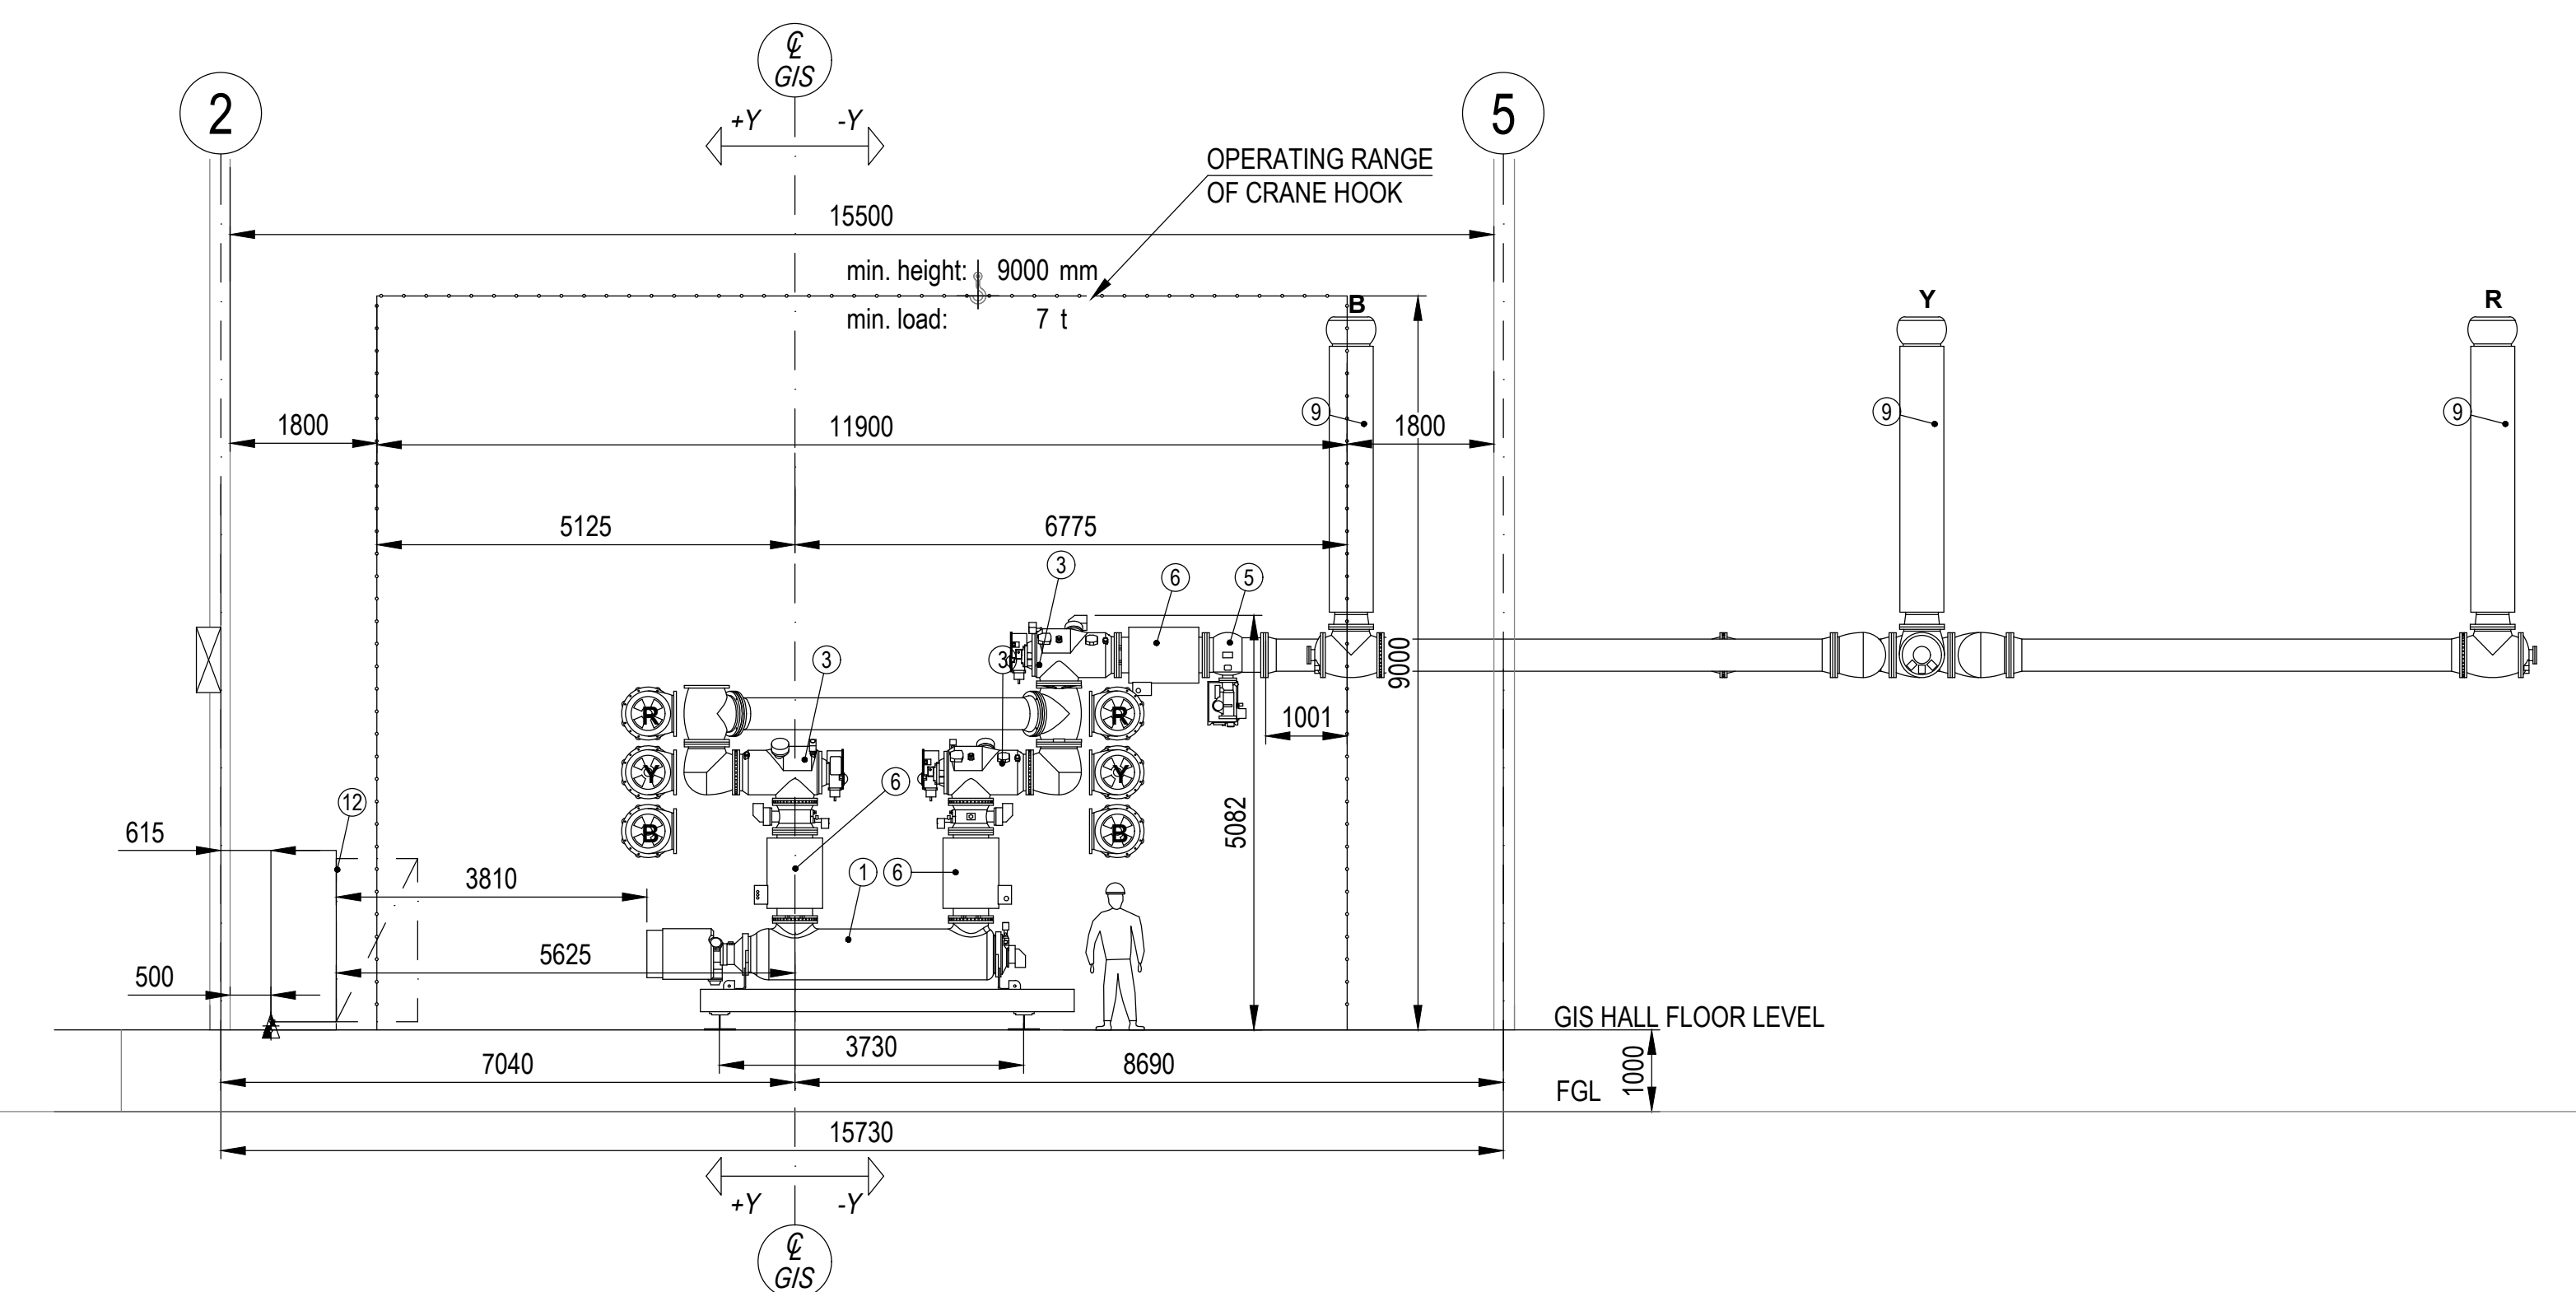

PROJECT		400/220KV GIS SUBSTATION AT ERSAMA, ODISHA & 400KV AIS FEEDER BAR EXTENSION AT DUBURI, ODISHA			
		ODISHA POWER TRANSMISSION CORPORATION LIMITED			
DESIGN		BHWAT HEAVY ELECTRICALS LTD		DEPT	DATE
		TRANSMISSION BUSINESS GROUP		M	DATE
		NEHA		OD	DATE
				APPS	DATE
TITLE		400KV GIS LAYOUT DRAWING			
		DEPT.	SCALE	DRAWING NO.	
		DESIGN		1HTG200113-2	
					

[illegible]

FOR APPROVAL

COMPLIANCE SHEET


Client: OPTCL
Project: 400/220KV GIS SUB-STATION, ERSAMA
Doc: Structure Loading Diagram For 400/220KV Gis Substation at Ersama (Rev-00)
Doc. No: TB-1-420-316-006

Sl.No.	Customer Comments	BHEL Clarification/ Compliance
OPTCL comments vide mail dated 21.04.23		
1	The following shall be adopted for the substation structures: 411 and 412 shall be low gantry type i.e. @15m 413 shall be @22m 211 & 212 shall be of low gantry type i.e. @10.5m or 11.7m - cx shall be Single ACSR Zeon - The DSLP may be re-checked as per the new structures. All other structures shall be as per your drawing no-TB-1-420-316-006 shall remain same.	Noted & incorporated in revised drawing. Revised DSLP will be submitted shortly.
OPTCL comments vide D3 portal dated 28.03.23		
2	The tension per phase for 400kv (cx), 220kv (cx) and Shield Wire (d) shall be considered and mentioned in the drawing.	Forces bx & cx are on the terminal take-off gantries of 400KV & 220kv respectively & there will be stringing only on the line side. Line stringing, being a slack span, the Short Circuit tension is not considered and the take-off gantries are designed only for the Normal tension. Normal tensions have been considered as per the contract specification clause no. 2.2, Chapter-L7. "Terminal line take off gantries shall be designed for a minimum conductor tension of four metric tons per phase for 400KV and two metric tons per phase for 220KV & 132 kV." Similarly for Shield wires (d) Short Circuit forces are not applicable. Thus we request OPTCL to accept the proposed loading.
3	Two nos. of 30m LMs have been considered in the drawing. The BOQ has Three nos. 40m LMs.	BILL proposes to provide lattice structure type 2 nos. 50m High LMs for Lightning protection of Sub-station. This item is covered in the contract BOQ item sl. no. 20.1 and will be billed by BILL in M1. 40m High Monopole Lighting cum Lightning Mast are not covering the entire area for Lightning protection. Further, the proposed 50m High LM will be used not only for Lightning protection, but also for Sub-station lighting as platforms will be provided for mounting lights at 12.5m & 25m levels. This is as per the contract specification clause no. 2.2, Chapter-L7. 40m High monopoles will be provided only in case of illumination requirement of Sub-station.
4	The revised drawing considering the above may be submitted with signature of M/s BHFI in the pdf file (not scanned)	Noted. Digitally signed revised drawing submitted for final approval.

**AKHILESH
KUMAR**

Digitally signed by AKHILESH
 KUMAR
 DN: cn=AKHILESH KUMAR, o=BHEL,
 ou=TBG, email=akhileshk@bhel.in,
 c=IN
 Date: 2023.04.24 16:22:12 +05'30'

PROPOSED NATIONAL HIGHWAY

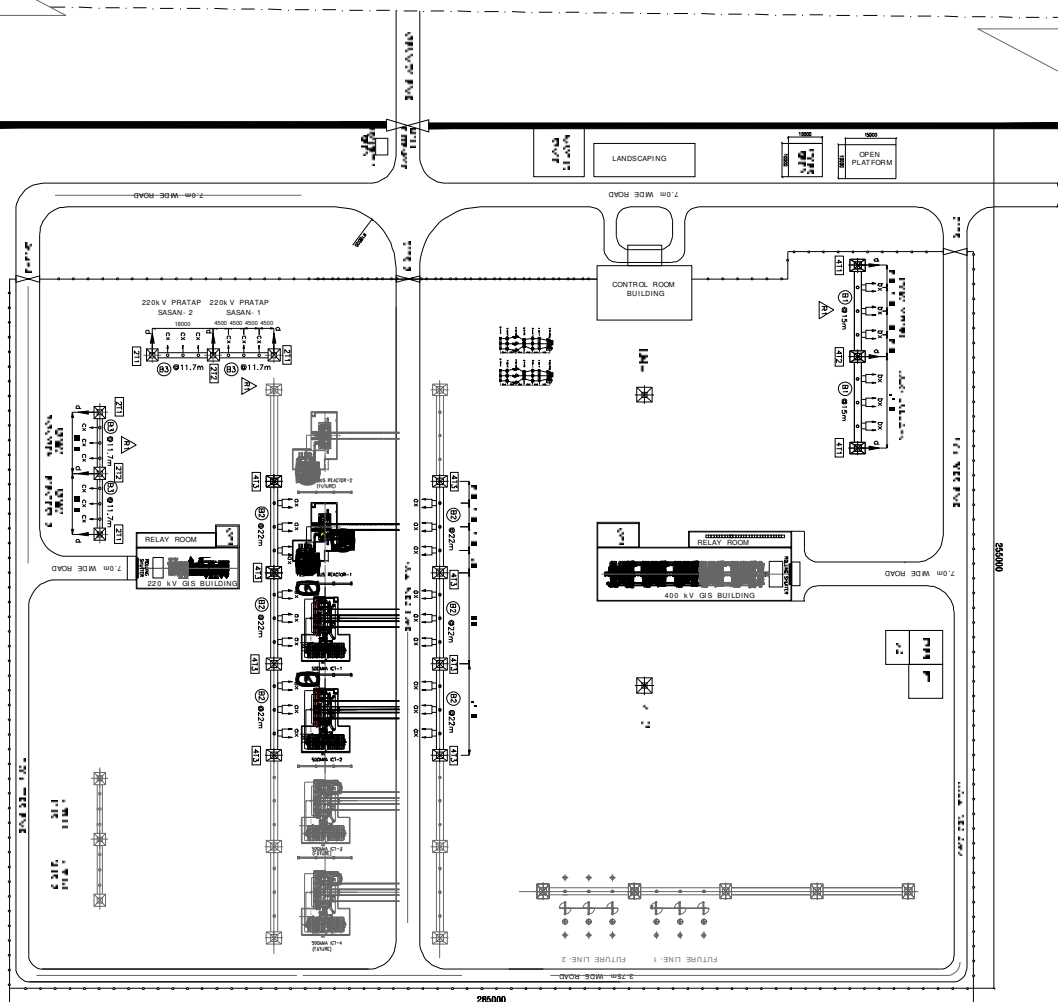

BEAM DETAIL (400KV) :-

BEAM TYPE	LENGTH (m)	INCOMING FROM	NO. OF SUB CONDUCTOR	MOORING HEIGHT (m)	QUANTITY (NO.)
①	27	2	2	13.5	02
②	27	2	2	22	06
NO. OF BEAMS					08

BEAM DETAIL (220KV) :-

BEAM TYPE	LENGTH (m)	INCOMING FROM	NO. OF SUB CONDUCTOR	MOORING HEIGHT (m)	QUANTITY (NO.)
③	18	2	2	11.7	04
NO. OF BEAMS					04

LOADING DETAILS (400KV) :-

NOTATION	NO. & TYPE OF CONDUIT / SHIELD WIRE PER PHASE	NORMAL TENSION PER PHASE	SPACE PER PHASE	S/C TENSION PER PHASE
④	3MM 455A MOOSE WITHOUT DEVIATION	4000 kg	3m	7200 kg
⑤	3MM 455A MOOSE WITH ± 30° DEVIATION (MAX) IN HORIZONTAL DIRECTION & ± 15° DEVIATION (MAX) IN VERTICAL DIRECTION	4000 kg	-	-

LOADING DETAILS (220KV) :-

NOTATION	NO. & TYPE OF CONDUIT / SHIELD WIRE PER PHASE	NORMAL TENSION PER PHASE	SPACE PER PHASE	S/C TENSION PER PHASE
⑥	3MM 455A MOOSE WITHOUT DEVIATION	2000 kg	-	-
⑦	3MM 455A MOOSE WITH ± 30° DEVIATION (MAX) IN HORIZONTAL DIRECTION & ± 15° DEVIATION (MAX) IN VERTICAL DIRECTION	2000 kg	-	-

LOADING DETAILS (SHIELD WIRE) :-

NOTATION	NO. & TYPE OF CONDUIT / SHIELD WIRE PER PHASE	NORMAL TENSION PER PHASE	SPACE PER PHASE	S/C TENSION PER PHASE
⑧	SHIELD WIRE WITH ± 30° DEVIATION (MAX)	800 kg	-	-

TOWER DETAIL (400KV) :-

TOWERS DESIGNATION	SIR. HEIGHT DETAIL FROM PLAIN (m)	QUANTITY (NO.)	BEAMS SUPPORTED
411	13+7.2M PEAK	02	B1 Ø15M ON 1 SIDE
412	15+7.2M PEAK	01	B1 Ø15M ON 2 SIDES AT 180 DEG
413	32+7.2M PEAK	06	B2 Ø22M ON 2 SIDES AT 180 DEG
TOTAL TOWERS		11	
14M	47+2.2M PEAK	02	

TOWER DETAIL (220KV) :-

TOWERS DESIGNATION	SIR. HEIGHT DETAIL FROM PLAIN (m)	QUANTITY (NO.)	BEAMS SUPPORTED
211	11+7.5-0M PEAK	04	B3 Ø11.7M ON 1 SIDE
212	11+7.5-0M PEAK	02	B3 Ø11.7M ON 2 SIDES AT 180 DEG
TOTAL TOWERS		06	

- NOTES :-
- ALL DIMENSIONS ARE IN mm.
 - THE STRUCTURE SHALL BE DESIGNED FOR A FACTOR OF SAFETY OF 2 FOR NORMAL CONDITION & 1.5 FOR SHORT CIRCUIT FORCES CONDITION.
 - THE TRANSMISSION, VERTICAL, LONGITUDINAL LOADS SHALL BE CONSIDERED AS PER IS 802.
 - WEIGHT OF THE WIRE WITH TOWERS AT ANY POINT OF TOWER SHALL BE CONSIDERED ON BEAM AS 150 kg.
 - ALL HEIGHTS ARE WITH REFERENCE TO PLAIN LEVEL. PLAIN LEVEL IS 20mm ABOVE FINISHED GROUND LEVEL.
 - CONDUCTORS INCLUDING FOR SAGGATION UNWEIGHTED IN BRACK.
 - FOR ALL DIMENSIONS OF TOWER, STRUCTURE SHALL BE TAKEN AS 20mm FOR DESIGN PURPOSE.
 - FRAMING ASSUMPTION WOULD BE DOUBLE TRUSS/ SUSPENSION UNWEIGHTED WITH DOUBLE ANCHORING POINTS FOR 400KV & SINGLE TRUSS/ SUSPENSION UNWEIGHTED WITH SINGLE ANCHORING POINT FOR 220KV.
 - ANCHORING POINT SPACING SHALL BE 400mm FOR 400KV & 200mm FOR 220KV (IF APPLICABLE).
 - DIMENSIONS SHALL BE READ ONLY FOR TOWER & BEAM HEIGHTS FOR LOCATION OF TOWERS, FENCE, FENCE ETC. UNLESS OTHERWISE SPECIFIED.

PROJECT: 400/220 KV GIS SUB STATION AT ERSAMA ODISHA & 400KV AIS FEEDER BAY EXTENSION DUBURI ODISHA

OWNER: ODISHA POWER TRANSMISSION CORPORATION LIMITED

BARAHAT HEAVY ELECTRICALS LTD. TRANSMISSION BUSINESS GROUP NODIA

DATE: 24.04.23

SCALE: 1:1

DWG TITLE: STRUCTURE LOADING DIAGRAM FOR 400/220KV GIS SUB STATION AT ERSAMA

DRIVING NO. TB-1-420-316-006

SHEET NO. 01

DATE: 18.03.23

NAME: AK

SIGN: -SIGNED-

DATE: 18.03.23

NAME: AK

SIGN: -SIGNED-

DATE: 18.03.23

(ALL DIMENSIONS ARE IN mm)

9

(ת

4

60

N2

—

SCHEDULE OF DOORS & WINDOWS				
TYPE	QTY	FRAME MATERIAL	UNIT	DESC.
601	5000x3000	5000x3000	-	STEEL ROLLING SHUTTER (AS PER TECH. SPECS)
602	3000x3000	3000x3000	-	STEEL ROLLING SHUTTER (AS PER TECH. SPECS)
603	2000x2500	1980x2450	-	STEEL ROLLING SHUTTER (AS PER TECH. SPECS)
604	1500x2000	1480x1900	-	STEEL ROLLING SHUTTER (AS PER TECH. SPECS)
605	750x2100	730x2000	-	STEEL ROLLING SHUTTER (AS PER TECH. SPECS)
606	3000x1800	2900x1780	-	STEEL ROLLING SHUTTER (AS PER TECH. SPECS)
607	1800x1800	1780x1800	-	STEEL ROLLING SHUTTER (AS PER TECH. SPECS)
608	1500x1800	1480x1800	-	STEEL ROLLING SHUTTER (AS PER TECH. SPECS)
609	1200x1800	1180x1800	-	STEEL ROLLING SHUTTER (AS PER TECH. SPECS)
610	900x1800	880x1800	-	STEEL ROLLING SHUTTER (AS PER TECH. SPECS)
611	600x1800	580x1800	-	STEEL ROLLING SHUTTER (AS PER TECH. SPECS)
612	300x1800	280x1800	-	STEEL ROLLING SHUTTER (AS PER TECH. SPECS)
613	1500x1200	1480x1200	-	STEEL ROLLING SHUTTER (AS PER TECH. SPECS)
614	1200x1200	1180x1200	-	STEEL ROLLING SHUTTER (AS PER TECH. SPECS)
615	900x1200	880x1200	-	STEEL ROLLING SHUTTER (AS PER TECH. SPECS)
616	600x1200	580x1200	-	STEEL ROLLING SHUTTER (AS PER TECH. SPECS)
617	300x1200	280x1200	-	STEEL ROLLING SHUTTER (AS PER TECH. SPECS)
618	1500x900	1480x900	-	STEEL ROLLING SHUTTER (AS PER TECH. SPECS)
619	1200x900	1180x900	-	STEEL ROLLING SHUTTER (AS PER TECH. SPECS)
620	900x900	880x900	-	STEEL ROLLING SHUTTER (AS PER TECH. SPECS)
621	600x900	580x900	-	STEEL ROLLING SHUTTER (AS PER TECH. SPECS)
622	300x900	280x900	-	STEEL ROLLING SHUTTER (AS PER TECH. SPECS)
623	1500x600	1480x600	-	STEEL ROLLING SHUTTER (AS PER TECH. SPECS)
624	1200x600	1180x600	-	STEEL ROLLING SHUTTER (AS PER TECH. SPECS)
625	900x600	880x600	-	STEEL ROLLING SHUTTER (AS PER TECH. SPECS)
626	600x600	580x600	-	STEEL ROLLING SHUTTER (AS PER TECH. SPECS)
627	300x600	280x600	-	STEEL ROLLING SHUTTER (AS PER TECH. SPECS)
628	1500x300	1480x300	-	STEEL ROLLING SHUTTER (AS PER TECH. SPECS)
629	1200x300	1180x300	-	STEEL ROLLING SHUTTER (AS PER TECH. SPECS)
630	900x300	880x300	-	STEEL ROLLING SHUTTER (AS PER TECH. SPECS)
631	600x300	580x300	-	STEEL ROLLING SHUTTER (AS PER TECH. SPECS)
632	300x300	280x300	-	STEEL ROLLING SHUTTER (AS PER TECH. SPECS)
633	1500x150	1480x150	-	STEEL ROLLING SHUTTER (AS PER TECH. SPECS)
634	1200x150	1180x150	-	STEEL ROLLING SHUTTER (AS PER TECH. SPECS)
635	900x150	880x150	-	STEEL ROLLING SHUTTER (AS PER TECH. SPECS)
636	600x150	580x150	-	STEEL ROLLING SHUTTER (AS PER TECH. SPECS)
637	300x150	280x150	-	STEEL ROLLING SHUTTER (AS PER TECH. SPECS)
638	1500x75	1480x75	-	STEEL ROLLING SHUTTER (AS PER TECH. SPECS)
639	1200x75	1180x75	-	STEEL ROLLING SHUTTER (AS PER TECH. SPECS)
640	900x75	880x75	-	STEEL ROLLING SHUTTER (AS PER TECH. SPECS)
641	600x75	580x75	-	STEEL ROLLING SHUTTER (AS PER TECH. SPECS)
642	300x75	280x75	-	STEEL ROLLING SHUTTER (AS PER TECH. SPECS)
643	1500x37.5	1480x37.5	-	STEEL ROLLING SHUTTER (AS PER TECH. SPECS)
644	1200x37.5	1180x37.5	-	STEEL ROLLING SHUTTER (AS PER TECH. SPECS)
645	900x37.5	880x37.5	-	STEEL ROLLING SHUTTER (AS PER TECH. SPECS)
646	600x37.5	580x37.5	-	STEEL ROLLING SHUTTER (AS PER TECH. SPECS)
647	300x37.5	280x37.5	-	STEEL ROLLING SHUTTER (AS PER TECH. SPECS)
648	1500x18.75	1480x18.75	-	STEEL ROLLING SHUTTER (AS PER TECH. SPECS)
649	1200x18.75	1180x18.75	-	STEEL ROLLING SHUTTER (AS PER TECH. SPECS)
650	900x18.75	880x18.75	-	STEEL ROLLING SHUTTER (AS PER TECH. SPECS)
651	600x18.75	580x18.75	-	STEEL ROLLING SHUTTER (AS PER TECH. SPECS)
652	300x18.75	280x18.75	-	STEEL ROLLING SHUTTER (AS PER TECH. SPECS)
653	1500x9.375	1480x9.375	-	STEEL ROLLING SHUTTER (AS PER TECH. SPECS)
654	1200x9.375	1180x9.375	-	STEEL ROLLING SHUTTER (AS PER TECH. SPECS)
655	900x9.375	880x9.375	-	STEEL ROLLING SHUTTER (AS PER TECH. SPECS)
656	600x9.375	580x9.375	-	STEEL ROLLING SHUTTER (AS PER TECH. SPECS)
657	300x9.37	280x9.37	-	STEEL ROLLING SHUTTER (AS PER TECH. SPECS)
658	1500x4.6875	1480x4.6875	-	STEEL ROLLING SHUTTER (AS PER TECH. SPECS)
659	1200x4.6875	1180x4.6875	-	STEEL ROLLING SHUTTER (AS PER TECH. SPECS)
660	900x4.6875	880x4.6875	-	STEEL ROLLING SHUTTER (AS PER TECH. SPECS)
661	600x4.6875	580x4.6875	-	STEEL ROLLING SHUTTER (AS PER TECH. SPECS)
662	300x4.6875	280x4.6875	-	STEEL ROLLING SHUTTER (AS PER TECH. SPECS)
663	1500x2.34375	1480x2.34375	-	STEEL ROLLING SHUTTER (AS PER TECH. SPECS)
664	1200x2.34375	1180x2.34375	-	STEEL ROLLING SHUTTER (AS PER TECH. SPECS)
665	900x2.34375	880x2.34375	-	STEEL ROLLING SHUTTER (AS PER TECH. SPECS)
666	600x2.34375	580x2.34375	-	STEEL ROLLING SHUTTER (AS PER TECH. SPECS)
667	300x2.34375	280x2.34375	-	STEEL ROLLING SHUTTER (AS PER TECH. SPECS)
668	1500x1.171875	1480x1.171875	-	STEEL ROLLING SHUTTER (AS PER TECH. SPECS)
669	1200x1.171875	1180x1.171875	-	STEEL ROLLING SHUTTER (AS PER TECH. SPECS)
670	900x1.171875	880x1.171875	-	STEEL ROLLING SHUTTER (AS PER TECH. SPECS)
671	600x1.171875	580x1.171875	-	STEEL ROLLING SHUTTER (AS PER TECH. SPECS)
672	300x1.171875	280x1.171875	-	STEEL ROLLING SHUTTER (AS PER TECH. SPECS)
673	1500x0.5859375	1480x0.5859375	-	STEEL ROLLING SHUTTER (AS PER TECH. SPECS)
674	1200x0.5859375	1180x0.5859375	-	STEEL ROLLING SHUTTER (AS PER TECH. SPECS)
675	900x0.5859375	880x0.5859375	-	STEEL ROLLING SHUTTER (AS PER TECH. SPECS)
676	600x0.5859375	580x0.5859375	-	STEEL ROLLING SHUTTER (AS PER TECH. SPECS)
677	300x0.5859375	280x0.5859375	-	STEEL ROLLING SHUTTER (AS PER TECH. SPECS)
678	1500x0.29296875	1480x0.29296875	-	STEEL ROLLING SHUTTER (AS PER TECH. SPECS)
679	1200x0.29296875	1180x0.29296875	-	STEEL ROLLING SHUTTER (AS PER TECH. SPECS)
680	900x0.29296875	880x0.29296875	-	STEEL ROLLING SHUTTER (AS PER TECH. SPECS)
681	600x0.29296875	580x0.29296875	-	STEEL ROLLING SHUTTER (AS PER TECH. SPECS)
682	300x0.29296875	280x0.29296875	-	STEEL ROLLING SHUTTER (AS PER TECH. SPECS)
683	1500x0.146484375	1480x0.146484375	-	STEEL ROLLING SHUTTER (AS PER TECH. SPECS)
684	1200x0.146484375	1180x0.146484375	-	STEEL ROLLING SHUTTER (AS PER TECH. SPECS)
685	900x0.146484375	880x0.146484375	-	STEEL ROLLING SHUTTER (AS PER TECH. SPECS)
686	600x0.146484375	580x0.146484375	-	STEEL ROLLING SHUTTER (AS PER TECH. SPECS)
687	300x0.146484375	280x0.146484375	-	STEEL ROLLING SHUTTER (AS PER TECH. SPECS)
688	1500x0.0732421875	1480x0.0732421875	-	STEEL ROLLING SHUTTER (AS PER TECH. SPECS)
689	1200x0.0732421875	1180x0.0732421875	-	STEEL ROLLING SHUTTER (AS PER TECH. SPECS)
690	900x0.0732421875	880x0.0732421875	-	STEEL ROLLING SHUTTER (AS PER TECH. SPECS)
691	600x0.0732421875	580x0.0732421875	-	STEEL ROLLING SHUTTER (AS PER TECH. SPECS)
692	300x0.0732421875	280x0.0732421875	-	STEEL ROLLING SHUTTER (AS PER TECH. SPECS)
693	1500x0.03662109375	1480x0.03662109375	-	STEEL ROLLING SHUTTER (AS PER TECH. SPECS)
694	1200x0.03662109375	1180x0.03662109375	-	STEEL ROLLING SHUTTER (AS PER TECH. SPECS)
695	900x0.03662109375	880x0.03662109375	-	STEEL ROLLING SHUTTER (AS PER TECH. SPECS)
696	600x0.03662109375	580x0.03662109375	-	STEEL ROLLING SHUTTER (AS PER TECH. SPECS)
697	300x0.03662109375	280x0.03662109375	-	STEEL ROLLING SHUTTER (AS PER TECH. SPECS)
698	1500x0.018310546875	1480x0.018310546875	-	STEEL ROLLING SHUTTER (AS PER TECH. SPECS)
699	1200x0.018310546875	1180x0.018310546875	-	STEEL ROLLING SHUTTER (AS PER TECH. SPECS)
700	900x0.018310546875	880x0.018310546875	-	STEEL ROLLING SHUTTER (AS PER TECH. SPECS)
701	600x0.018310546875	580x0.018310546875	-	STEEL ROLLING SHUTTER (AS PER TECH. SPECS)
702	300x0.018310546875	280x0.018310546875	-	STEEL ROLLING SHUTTER (AS PER TECH. SPECS)
703	1500x0.0091552734375	1480x0.0091552734375	-	STEEL ROLLING SHUTTER (AS PER TECH. SPECS)
704	1200x0.0091552734375	1180x0.0091552734375	-	STEEL ROLLING SHUTTER (AS PER TECH. SPECS)
705	900x0.0091552734375	880x0.0091552734375	-	STEEL ROLLING SHUTTER (AS PER TECH. SPECS)
706	600x0.0091552734375	580x0.0091552734375	-	STEEL ROLLING SHUTTER (AS PER TECH. SPECS)
707	300x0.0091552734375	280x0.0091552734375	-	STEEL ROLLING SHUTTER (AS PER TECH. SPECS)
708	1500x0.00457763671875	1480x0.00457763671875	-	STEEL ROLLING SHUTTER (AS PER TECH. SPECS)
709	1200x0.00457763671875	1180x0.00457763671875	-	STEEL ROLLING SHUTTER (AS PER TECH. SPECS)
710	900x0.00457763671875	880x0.00457763671875	-	STEEL ROLLING SHUTTER (AS PER TECH. SPECS)
711	600x0.00457763671875	580x0.00457763671875	-	STEEL ROLLING SHUTTER (AS PER TECH. SPECS)
712	300x0.00457763671875	280x0.00457763671875	-	STEEL ROLLING SHUTTER (AS PER TECH. SPECS)
713	1500x0.002288818359375	1480x0.002288818359375	-	STEEL ROLLING SHUTTER (AS PER TECH. SPECS)
714	1200x0.002288818359375	1180x0.002288818359375	-	STEEL ROLLING SHUTTER (AS PER TECH. SPECS)
715	900x0.002288818359375	880x0.002288818359375	-	STEEL ROLLING SHUTTER (AS PER TECH. SPECS)
716	600x0.002288818359375	580x0.002288818359375	-	STEEL ROLLING SHUTTER (AS PER TECH. SPECS)
717	300x0.002288818359375	280x0.002288818359375	-	STEEL ROLLING SHUTTER (AS PER TECH. SPECS)
718	1500x0.0011444091796875	1480x0.0011444091796875	-	STEEL ROLLING SHUTTER (AS PER TECH. SPECS)
719	1200x0.0011444091796875	1180x0.0011444091796875	-	STEEL ROLLING SHUTTER (AS PER TECH. SPECS)
720	900x0.0011444091796875	880x0.0011444091796875	-	STEEL ROLLING SHUTTER (AS PER TECH. SPECS)
721	600x0.0011444091796875	580x0.0011444091796875	-	STEEL ROLLING SHUTTER (AS PER TECH. SPECS)
722	300x0.0011444091796875	280x0.0011444091796875	-	STEEL ROLLING SHUTTER (AS PER TECH. SPECS)
723	1500x0.00057220458984375	1480x0.00057220458984375	-	STEEL ROLLING SHUTTER (AS PER TECH. SPECS)
724	1200x0.00057220458984375	1180x0.00057220458984375	-	STEEL ROLLING SHUTTER (AS PER TECH. SPECS)
725	900x0.00057220458984375	880x0.00057220458984375	-	STEEL ROLLING SHUTTER (AS PER TECH. SPECS)
726	600x0.00057220458984375	580x0.00057220458984375	-	STEEL ROLLING SHUTTER (AS PER TECH. SPECS)
727	300x0.00057220458984375	280x0.00057220458984375	-	STEEL ROLLING SHUTTER (AS PER TECH. SPECS)
728	1500x0.000286102294921875	1480x0.000286102294921875	-	STEEL ROLLING SHUTTER (AS PER TECH. SPECS)
729	1200x0.000286102294921875	1180x0.000286102294921875	-	STEEL ROLLING SHUTTER (AS PER TECH. SPECS)
730	900x0.000286102294921875	880x0.000286102294921875	-	STEEL ROLLING SHUTTER (AS PER TECH. SPECS)
731	600x0.000286102294921875	580x0.000286102294921875	-	STEEL ROLLING SHUTTER (AS PER TECH. SPECS)
732	300x0.000286102294921875	280x0.000286102294921875	-	STEEL ROLLING SHUTTER (AS PER TECH. SPECS)
733	1500x0.0001430511474609375	1480x0.0001430511474609375	-	STEEL ROLLING SHUTTER (AS PER TECH. SPECS)
734	1200x0.0001430511474609375	1180x0.0001430511474609375	-	STEEL ROLLING SHUTTER (AS PER TECH. SPECS)
735	900x0.0001430511474609375	880x0.0001430511474609375	-	STEEL ROLLING SHUTTER (AS PER TECH. SPECS)
736	600x0.0001430511474609375	580x0.0001430511474609375	-	STEEL ROLLING SHUTTER (AS PER TECH. SPECS)
737	300x0.0001430511474609375	280x0.0001430511474609375	-	STEEL ROLLING SHUTTER (AS PER TECH. SPECS)
738	1500x0.00007152557373046875	1480x0.00007152557373046875	-	STEEL ROLLING SHUTTER (AS PER TECH. SPECS)
739	1200x0.00007152557373046875	1180x0.00007152557373046875	-	STEEL ROLLING SHUTTER (AS PER TECH. SPECS)
740	900x0.00007152557373046875	880x0.00007152557373046875	-	STEEL ROLLING SHUTTER (AS PER TECH. SPECS)
741	600x0.00007152557373046875	580x0.00007152557373046875	-	STEEL ROLLING SHUTTER (AS PER TECH. SPECS)
742	300x0.00007152557373046875	280x0.00007152557373046875	-	STEEL ROLLING SHUTTER (AS PER TECH. SPECS)
743	1500x0.000035762786865234375	1480x0.000035762786865234375	-	STEEL ROLLING SHUTTER (AS PER TECH. SPECS)
744	1200x0.000035762786865234375	1180x0.000035762786865234375	-	STEEL ROLLING SHUTTER (AS PER TECH. SPECS)
745	900x0.000035762786865234375	880x0.000035762786865234375	-	STEEL ROLLING SHUTTER (AS PER TECH. SPECS)
746	600x0.000035762786865234375	580x0.000035762786865234375	-	STEEL ROLLING SHUTTER (AS PER TECH. SPECS)
747	300x0.000035762786865234375	280x0.000035762786865234375	-	STEEL ROLLING SHUTTER (AS PER TECH. SPECS)
748	1500x0.0000178813934326171875	1480x0.0000178813934326171875	-	STEEL ROLLING SHUTTER (AS PER TECH. SPECS)
749	1200x0.0000178813934326171875	1180x0.0000178813934326171875	-	STEEL ROLLING SHUTTER (AS PER TECH. SPECS)
750	900x0.0000178813934326171875	880x0.0000178813934326171875	-	STEEL ROLLING SHUTTER (AS PER TECH. SPECS)
751	600x0.0000178813934326171875	580x0.0000178813934326171875	-	STEEL ROLLING SHUTTER (AS PER TECH. SPECS)
752	300x0.0000178813934326171875	280x0.0000178813934326171875	-	STEEL ROLLING SHUTTER (AS PER TECH. SPECS)
753	1500x0.0000089406967162890625	1480x0.0000089406967162890625	-	STEEL ROLLING SHUTTER (AS PER TECH. SPECS)
754	1200x0.0000089406967162890625	1180x0.0000089406967162890625	-	STEEL ROLLING SHUTTER (AS PER TECH. SPECS)
755	900x0.0000089406967162890625	880x0.0000089406967162890625	-	STEEL ROLLING SHUTTER (AS PER TECH. SPECS)
756	600x0.0000089406967162890625	580x0.0000089406967162890625	-	STEEL ROLLING SHUTTER (AS PER TECH. SPECS)
757	300x0.0000089406967162890625	280x0.0000089406967162890625	-	STEEL ROLLING SHUTTER (AS PER TECH. SPECS)
758	1500x0.00000447034835814453125	1480		

- (A) A SURVEY CARD OF MEAN CEMENT FLOW: 2.75 kg/250 ml OF CEMENT ADDED WITH 100 ml OF WATER.
- (B) A SURVEY CARD OF MEAN CEMENT FLOW: 2.75 kg/250 ml OF CEMENT ADDED WITH 100 ml OF WATER.
- (C) A SURVEY CARD OF MEAN CEMENT FLOW: 2.75 kg/250 ml OF CEMENT ADDED WITH 100 ml OF WATER.
- (D) A SURVEY CARD OF MEAN CEMENT FLOW: 2.75 kg/250 ml OF CEMENT ADDED WITH 100 ml OF WATER.
- (E) A SURVEY CARD OF MEAN CEMENT FLOW: 2.75 kg/250 ml OF CEMENT ADDED WITH 100 ml OF WATER.



NOTES:-

1 ALL DIMENSIONS ARE IN MILLIMETERS AND LEVELS ARE IN METERS
UNLESS OTHERWISE SPECIFIED.

2 ALL DOOR-WINDOW, ETC. HEIGHT SHALL BE CONSIDERED FROM FINISH FLOOR LEVEL

PROJECT:										400V/220kV/GIS SUBSTATION AT ERSAMA, ODISHA &									
OWNER:										400kV AIS FEEDER BAY EXTENSION AT DUBURI, ODISHA									
ODISHA POWER TRANSMISSION CORPORATION LIMITED																			
																			
																			
BHARAT HEAVY ELECTRICALS LTD. TRANSMISSION BUSINESS GROUP NOIDA																			
DEPT. TSG CODE	UNTO. SBR q/m/y			SCALE N.T.S	WEIGHT (KG)	REF. TO ASSY.	DWG.	ITEM NO.	NO OF ITEMS										
				N.A.	N.A.	N.A.		N.A.	N.A.										
TITLE										CARD									
400kV GIS BUILDING-ARCH. GROUND FLOOR PLAN										NO. OF SHT. No. 01 NO. OF SHT. 01									
										REV. 01									
										TPB-1-420-607-640									
										A									

THE INFORMATION ON THIS DOCUMENT IS THE PROPERTY OF BHARAT HEAVY ELECTRICALS LIMITED. IT MUST NOT BE USED DIRECTLY OR INDIRECTLY IN ANY WAY DETRIMENTAL TO THE INTEREST OF THE COMPANY

FIRST ANGLE PROJECTION

(ALL DIMENSIONS ARE IN mm)

DRG. NO. TB-1-420-607-720

6

5

4


3

2

1

N

PLANT NORTH

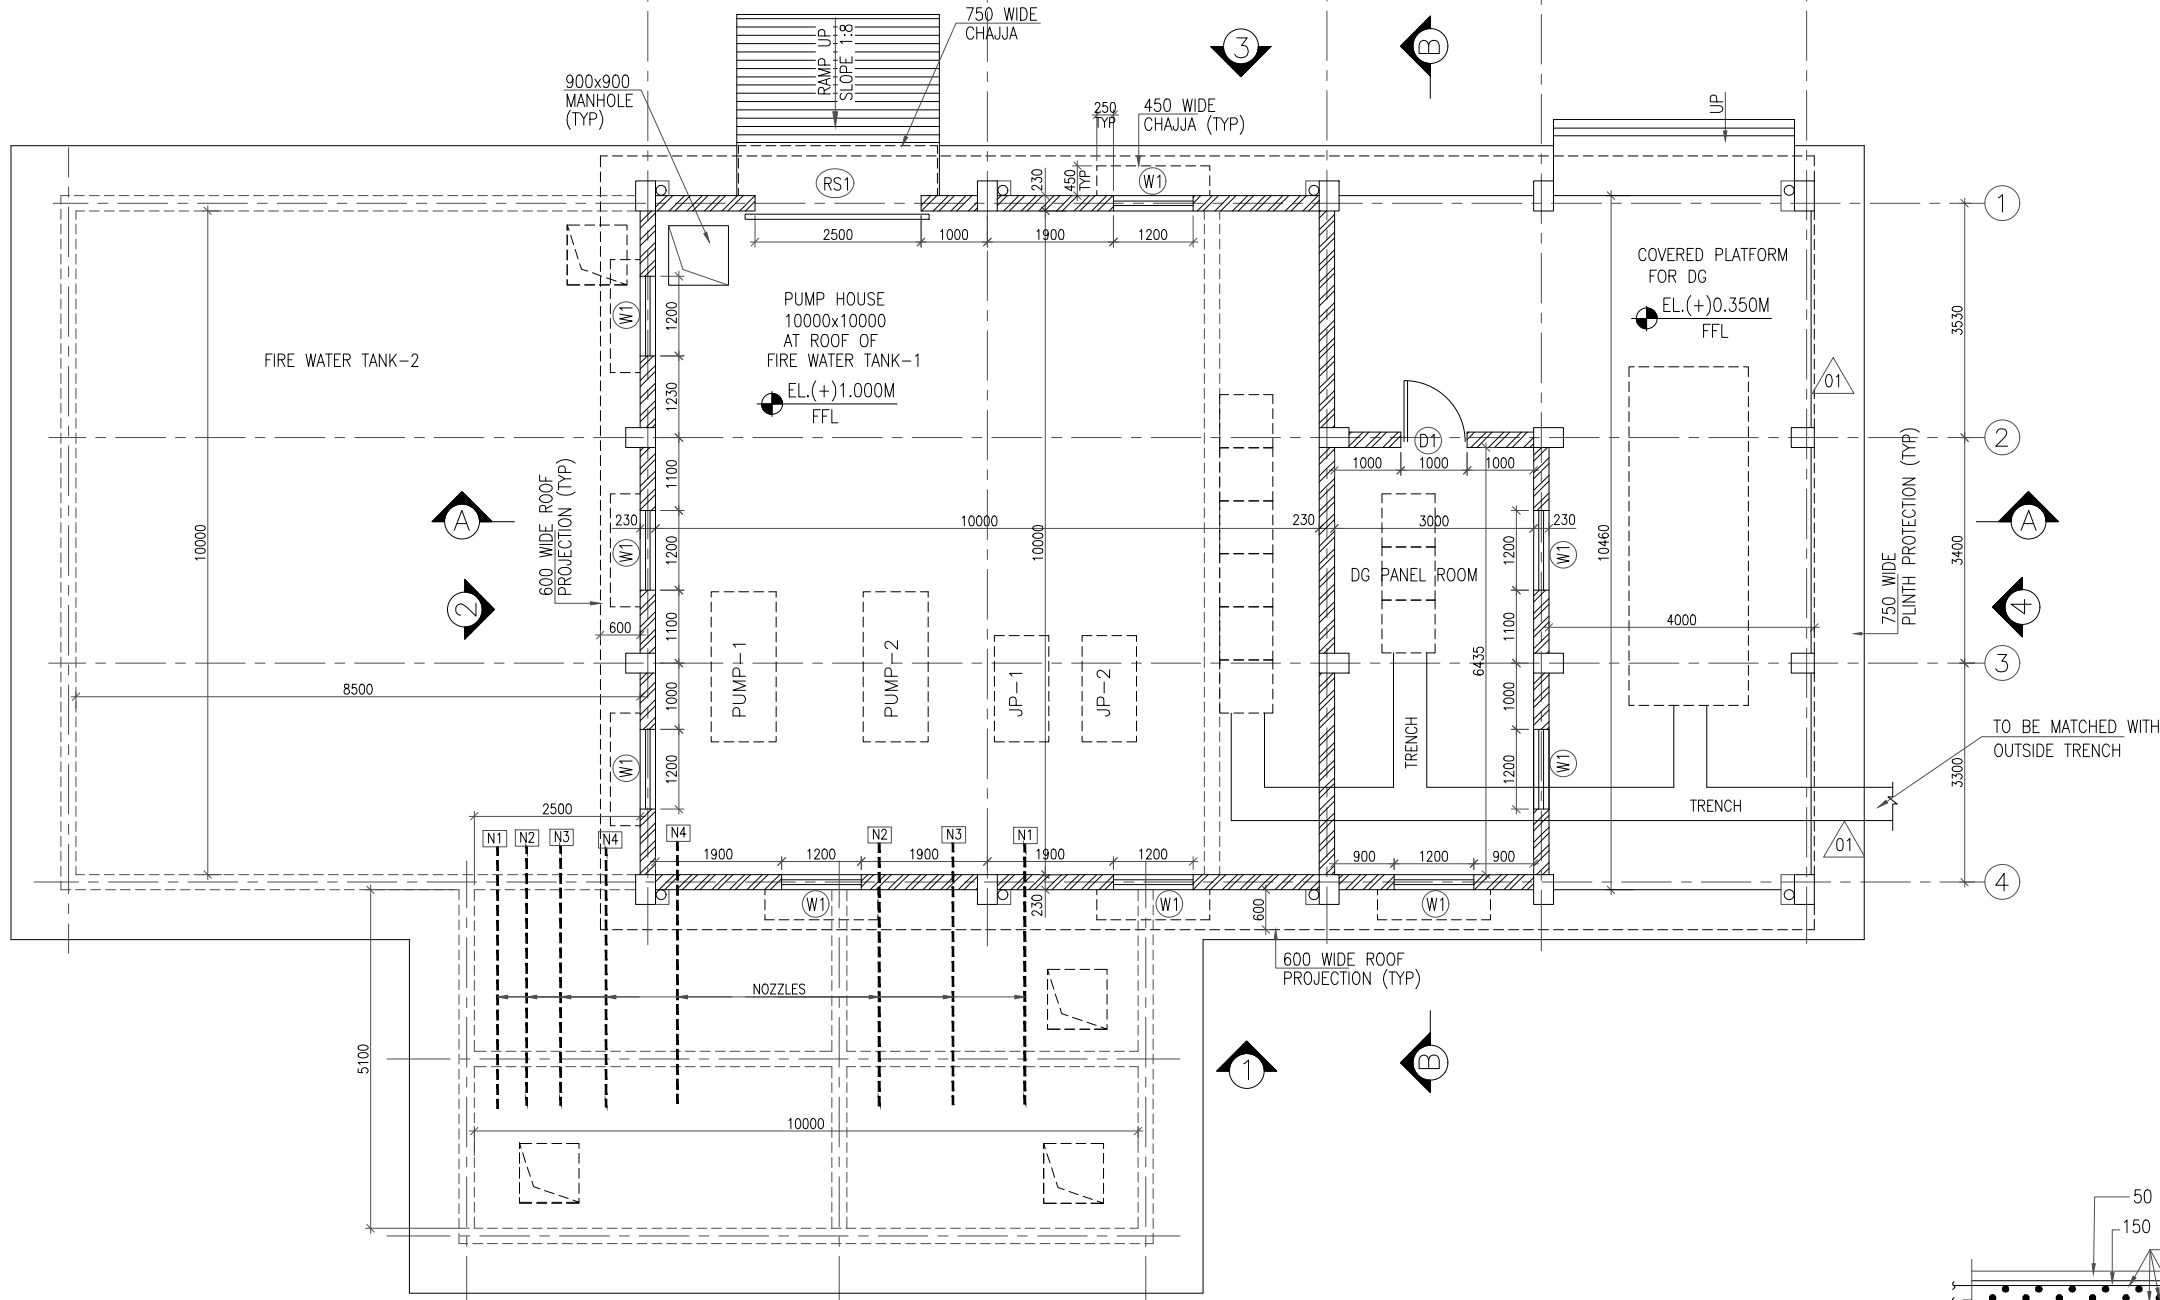

GROUND FLOOR PLAN

NOTES:-

- EXACT LOCATION AND SIZE OF NOZZLES (N1,N2,N3,N4) WHICH WILL BE EMBEDDED WHILE CASTING OF UNDERGROUND TANK WALLS, WILL BE SHOWN IN FFPH LAYOUT DRAWING.
- LOCATIONS AND PUMP FOUNDATION DETAILS SHALL BE PROVIDED IN SEPARATE DRAWING.

SCHEDULE OF FINISHES
(AS PER TECHNICAL SPECIFICATION)

1.0 BRICK WORK:

- 230mm THK. BRICK MASONRY IN C.M. (1:5) USING FLY ASH BRICK AS PER OPTCL TS.

2.0 PLASTER:

- INTERNAL:
12mm THK. PLASTER (1:6 CEMENT : SAND) MORTOR ON SMOOTH SIDE OF WALL.
15mm THK. PLASTER (1:6 CEMENT : SAND) MORTOR ON ROUGH SIDE OF SINGLE OR HALF BRICK WALL.
- EXTERNAL:
18mm THK. PLASTER IN TWO LAYER,
UNDER LAYER 12mm THK. (1:5 CEMENT : SAND) MORTOR AND
TOP LAYER 6mm THK. (1:3 CEMENT : SAND) MORTOR
- CEILING EXCEPT FOR WHERE FALSE CEILING WILL BE PROVIDED.
6mm THK. PLASTER (1:3 CEMENT : SAND)

3.0 FLOORING:


- PANEL ROOM, PUMP HOSE:-
CEMENT CONCRETE WITH METALLIC HARDENER TOPPING.
- SKIRTING:-
150 HIGH SKIRTING MATCHING WITH THE FLOOR SHALL BE PROVIDED.

5.0 PAINTING:

- INSIDE FACES OF BRICK WALL WILL HAVE DISTEMPER.
- OUTSIDE FACES OF WALL BE ACRYLIC SMOOTH EXTERIOR PAINT OVER PLASTER SURFACE.
- CEILING TO HAVE PLASTIC EMULSION PANT.

WATER PROOFING ON ROOF:

- CEMENT BASED WATER PROOFING TREATMENT OF ROOFS BALCONIES, TERRACES ETC SHALL BE PROVIDED WITH AVERAGE THICKNESS OF 120MM AND MINIMUM THICKNESS AT KHURRA AS 65 MM AND LAID CONSISTING OF FOLLOWING OPERATIONS:
- A SLURRY COAT OF NEAT CEMENT USING 2.75 KG/SQM OF CEMENT ADMIXED WITH PROPRIETARY WATER PROOFING COMPOUNDS CONFORMING TO IS: 2645 SHALL BE APPLIED AND GROUTED OVER THE RCC SLAB INCLUDING CLEANING THE SURFACE BEFORE TREATMENT.
 - PLAIN CEMENT CONCRETE 1:5:10 (1: CEMENT: 5 FINE SAND: 10 BURNT BRICK AGGREGATE OF 40 MM NOMINAL SIZE) ADMIXED WITH PROPRIETARY WATER PROOFING COMPOUND CONFORMING TO IS 2645 OVER 20 MM THICK LAYER OF CEMENT MORTAR OF MIN :5 (CEMENT 5 COARSE SAND) ADMIXED WITH PROPRIETARY WATER PROOFING COMPOUND CONFORMING TO IS: 2645 TO REQUIRED SLOPE AN TREATING SIMILARLY THE ADJOINING WALLS UPTO 300 MM HEIGHT INCLUDING ROUNDING OF JUNCTIONS OF WALLS AND SLABS.
 - AFTER TWO DAY OF PROPER CURING A SECOND COAT OF CEMENT SLURRY ADMIXED WITH PROPRIETARY WATER PROOFING COMPOUND CONFORMING TO IS 2645 SHALL BE APPLIED.
 - THE SURFACE SHALL BE FINISHED WITH 20 MM THICK JOINT LESS CEMENT MORTAR OF MIX 1:4 (1 CEMENT :4 COURSE SAND) ADMIXED WITH PROPRIETARY WATER PROOFING COMPOUND CONFORMING TO IS : 2645 AND FINALLY THE SURFACE SHALL BE FINISHED WITH TROWEL WITH NEAT CEMENT SLURRY AND MAKING OF 300 X 300 MM SQUARE
 - THE WHOLE TERRACE SO FINISHED SHALL BE FLOODED WITH WATER FOR A MINIMUM PERIOD OF TWO WEEKS FOR CURING AND FOR FINAL TEST. ALL ABOVE OPERATIONS SHALL BE DONE IN ORDER AN AS DIRECTED AND SPECIFIED BY THE ENGINEER-IN CHARGE.

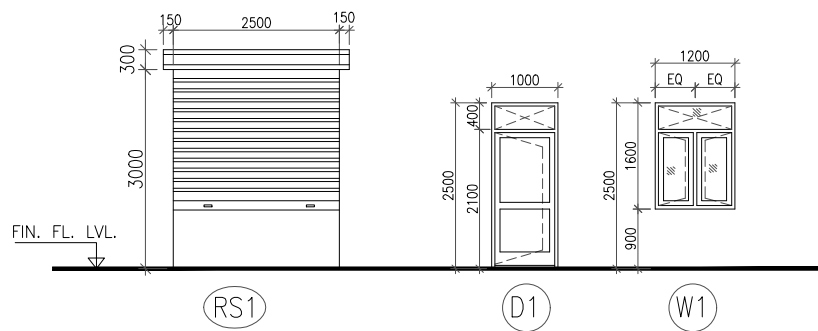


DETAIL OF GRADE SLAB
(FOR AREA EXCLUDING ROOF OF WATER TANK)


SCHEDULE OF DOORS & WINDOWS						
TYPE	OPENING SIZE	FRAME SIZE	CILL LEVEL	LINTEL LEVEL	NOS.	DESCRIPTION
RS1	2500x3000	2500x3000	-	3000	1	SEPARATE DWG SHALL BE REFERRED FOR DOOR/WINDOW DETAILS.
D1	1000x2500	980x2490	-	2500	1	
W1	1200x1600	1180x1580	900	2500	9	

LEGEND:-


- ☐ SIDE HUNG OPENABLE PANEL
- ☒ FIXED GLASS PANEL
- F.F.L. = FINISH FLOOR LEVEL
F.G.L. = FINISH GRADE LEVEL
H.P. = HIGH POINT
L.P. = LOWER POINT
E.F. = EXHAUST FAN
E.L. = ELEVATION LEVEL
T.O.C = TOP OF CONCRETE
N.T.S = NOT TO SCALE
TYP. = TYPICAL

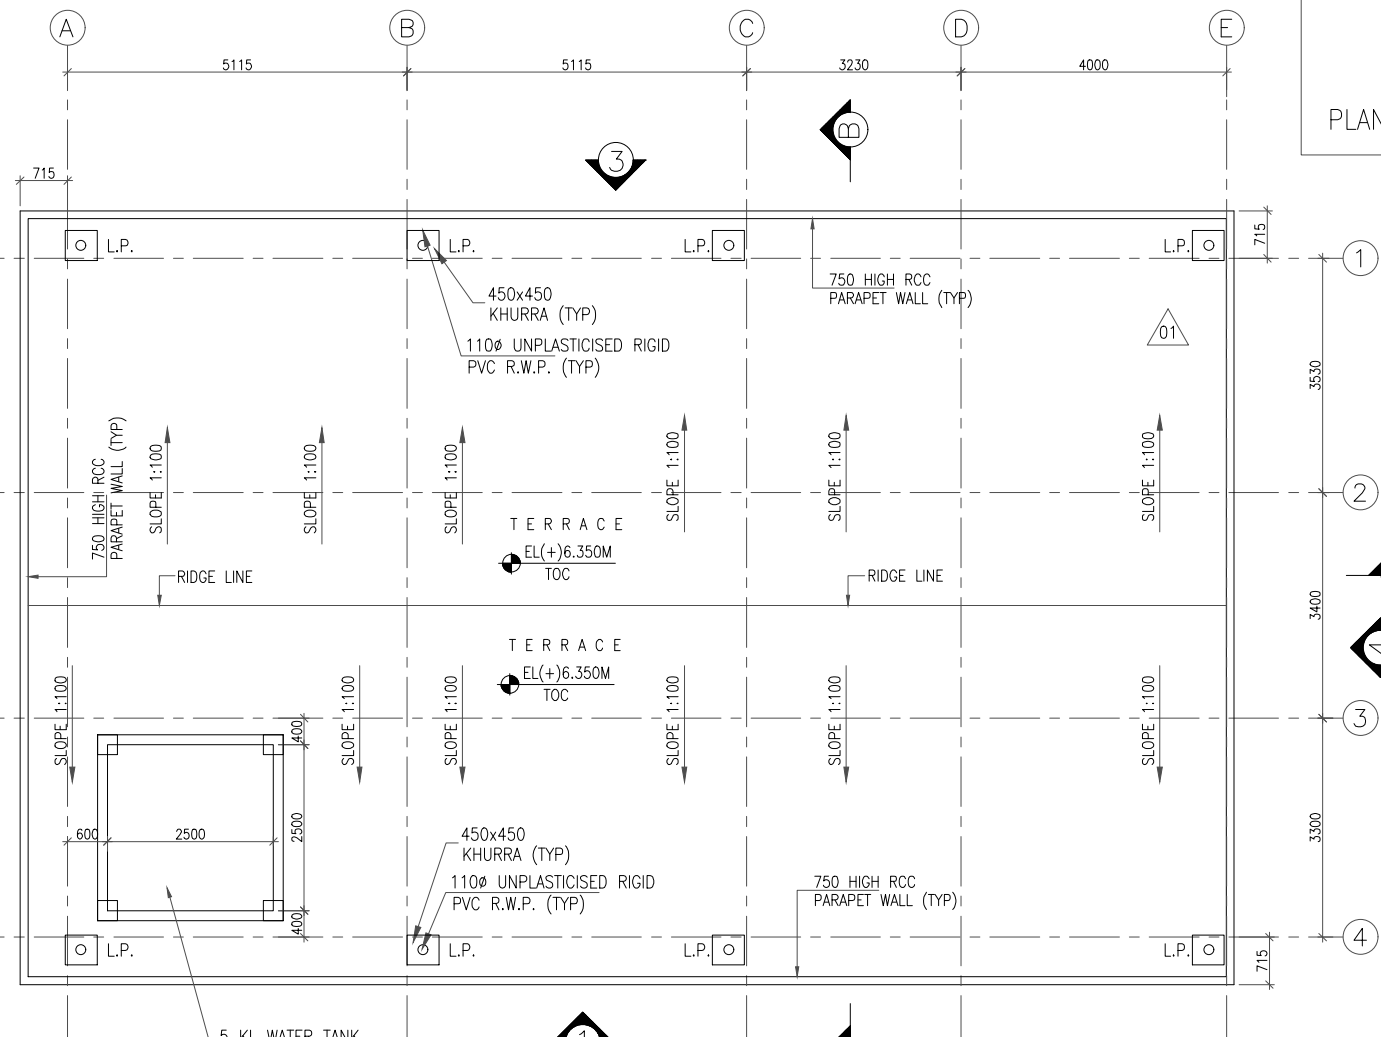

TERRACE PLAN

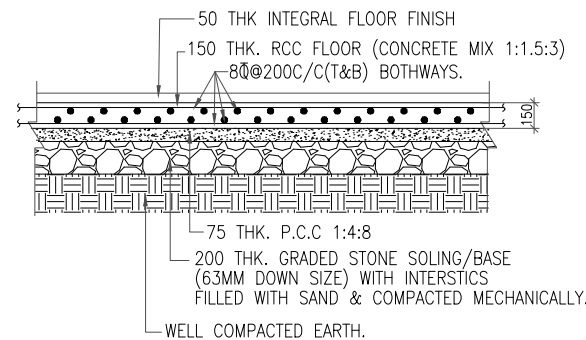

DETAIL OF GRADE SLAB
(FOR AREA EXCLUDING ROOF OF WATER TANK)

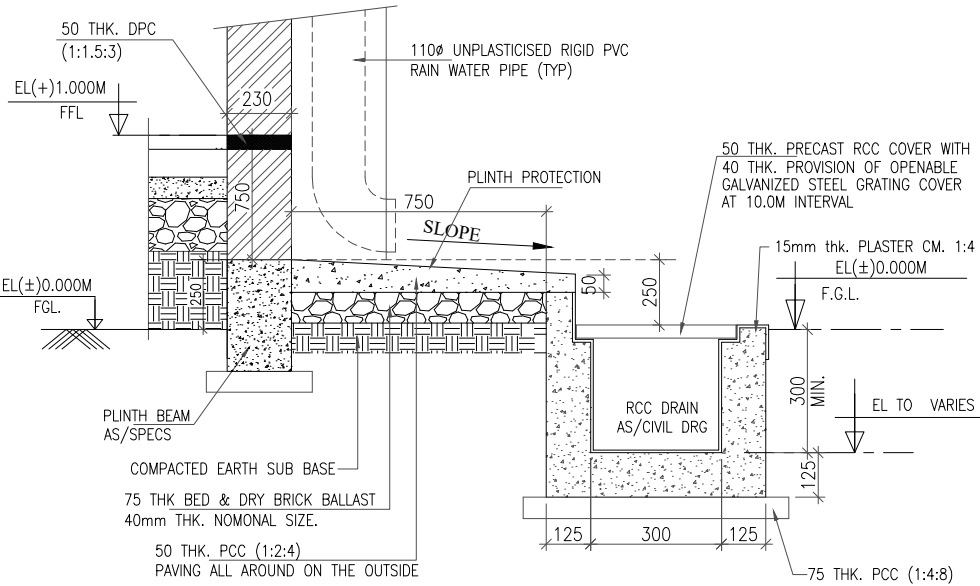

PLINTH PROTECTION ALONG BUILDING
WITH DRAIN-TYPICAL

NOTES:-

- ALL DIMENSIONS ARE IN MILLIMETERS AND LEVELS ARE IN METERS UNLESS OTHERWISE SPECIFIED.
- ALL DOOR-WINDOW, ETC. HEIGHT SHALL BE CONSIDERED FROM FINISH FLOOR LEVEL.

PROJECT: 400/220kVGIS SUBSTION AT ERSAMA, ODISHA & 400kV AIS FEEDER BAY EXTENSION AT DUBURI, ODISHA

OWNER: ODISHA POWER TRANSMISSION CORPORATION LIMITED

NAME	SIGN.	DATE	NO.OF VAR.
DRN. RDA CIVIL	--sd--	01.08.2023	
CHD. SV/AR	--sd--	01.08.2023	N.A.
APPD. PLK	--sd--	02.08.2023	

DEPT. TBG CODE	UNTOL. DIMS. GR. 9/M/Y	SCALE N.T.S	WEIGHT (KG) N.A.	REF. TO ASSY. DRG. N.A.	ITEM NO. N.A.	NO.OF ITEMS N.A.
----------------	------------------------	-------------	------------------	-------------------------	---------------	------------------

TITLE FIRE FIGHTING PUMP HOUSE & DG ROOM- GROUND FLOOR PLAN & TERRACE PLAN	CARD CODE NA	DRG.NO. TB-1-420-607-720	REV. 01
SHT. No 01	NO. OF SHT. 01		

THE INFORMATION ON THIS DOCUMENT IS THE PROPERTY OF BHARAT HEAVY ELECTRICALS LIMITED. IT MUST NOT BE USED DIRECTLY OR INDIRECTLY IN ANY WAY DETRIMENTAL TO THE INTEREST OF THE COMPANY

FIRST ANGLE PROJECTION

(ALL DIMENSIONS ARE IN mm)

DRG. NO. TB-1-420-607-721

6


5

4


3

2


1

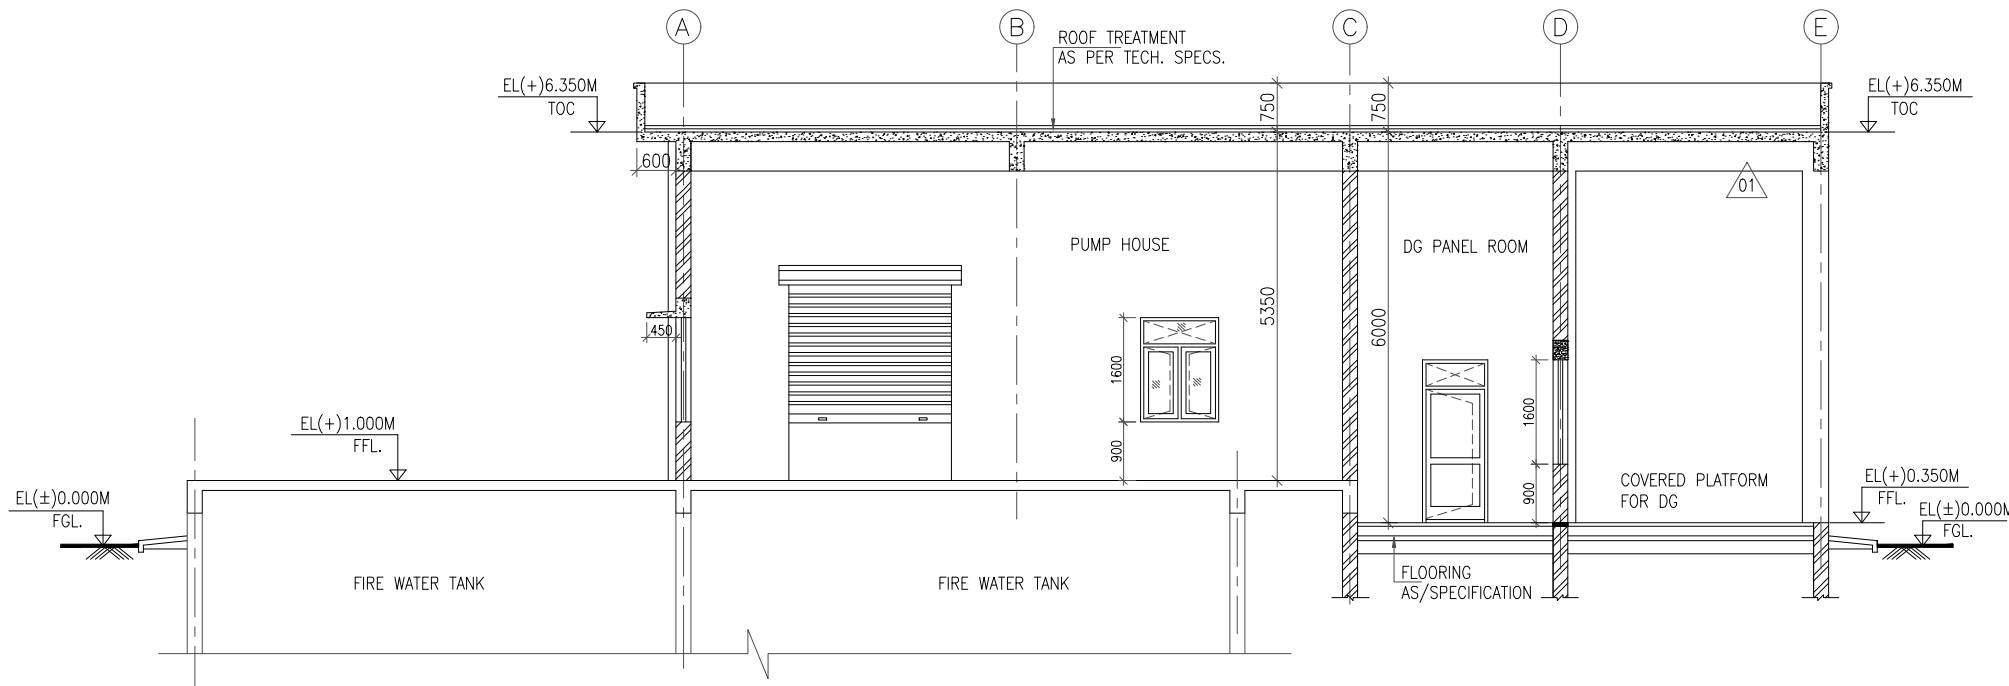


SECTION A-A

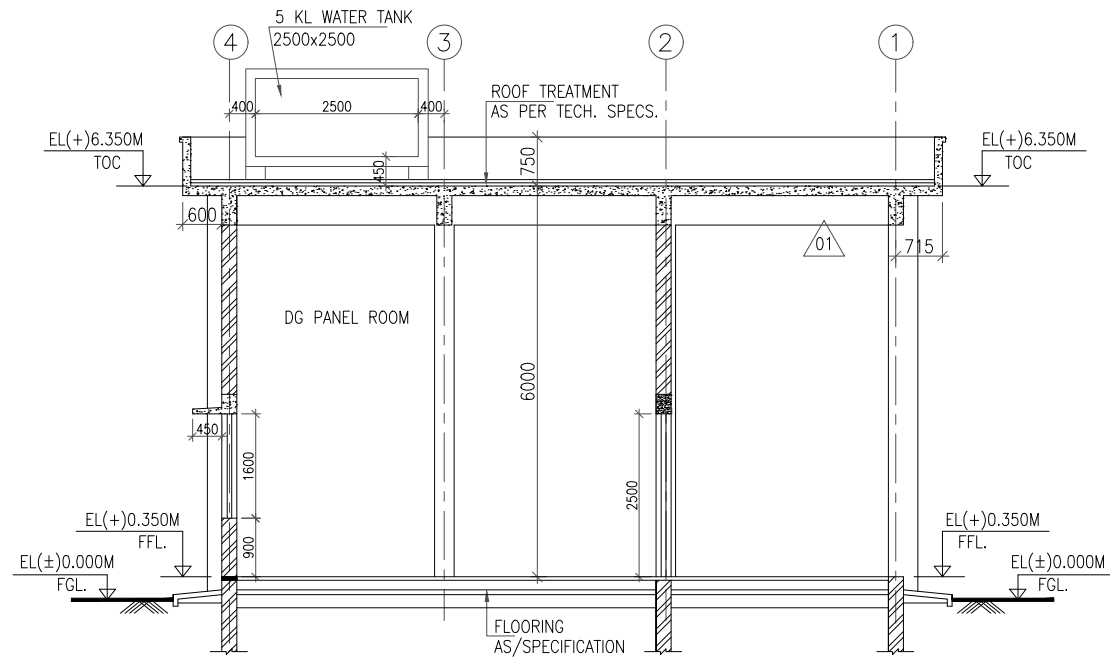


SECTION B-B

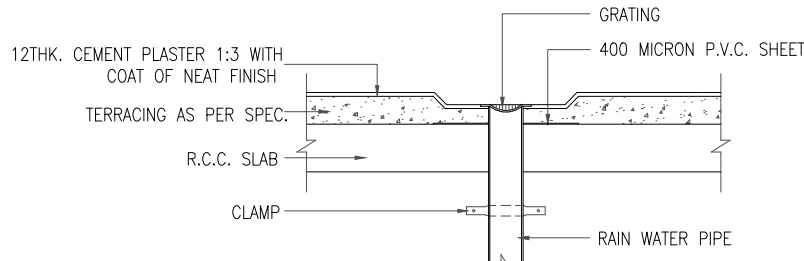


TYPICAL DETAIL OF KHURRA WITH RAIN WATER PIPE

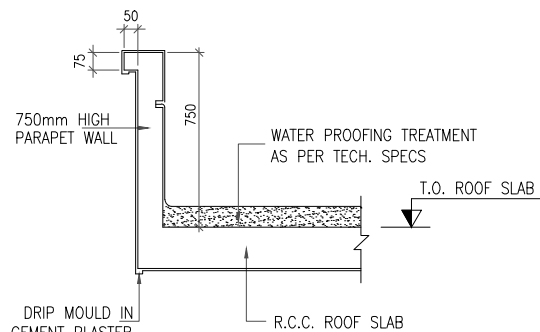


TYP. DETAIL OF PARAPET

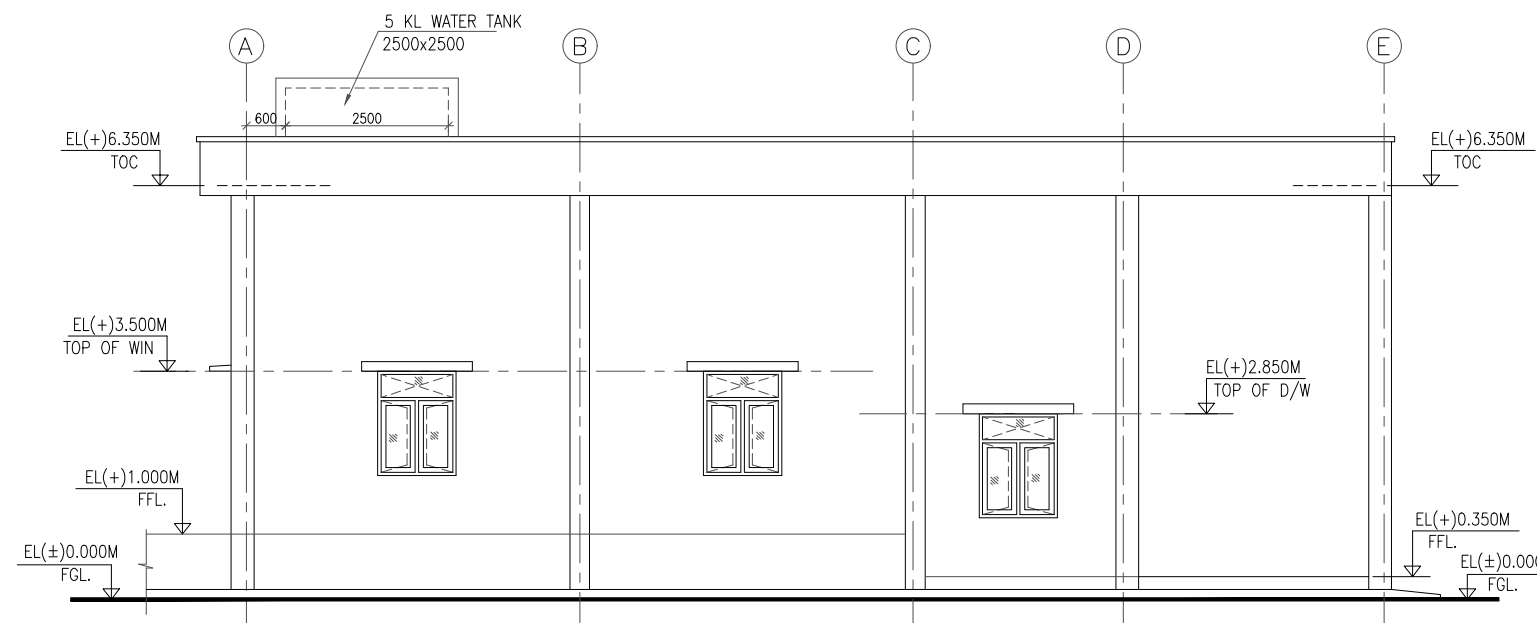


ELEVATION-1

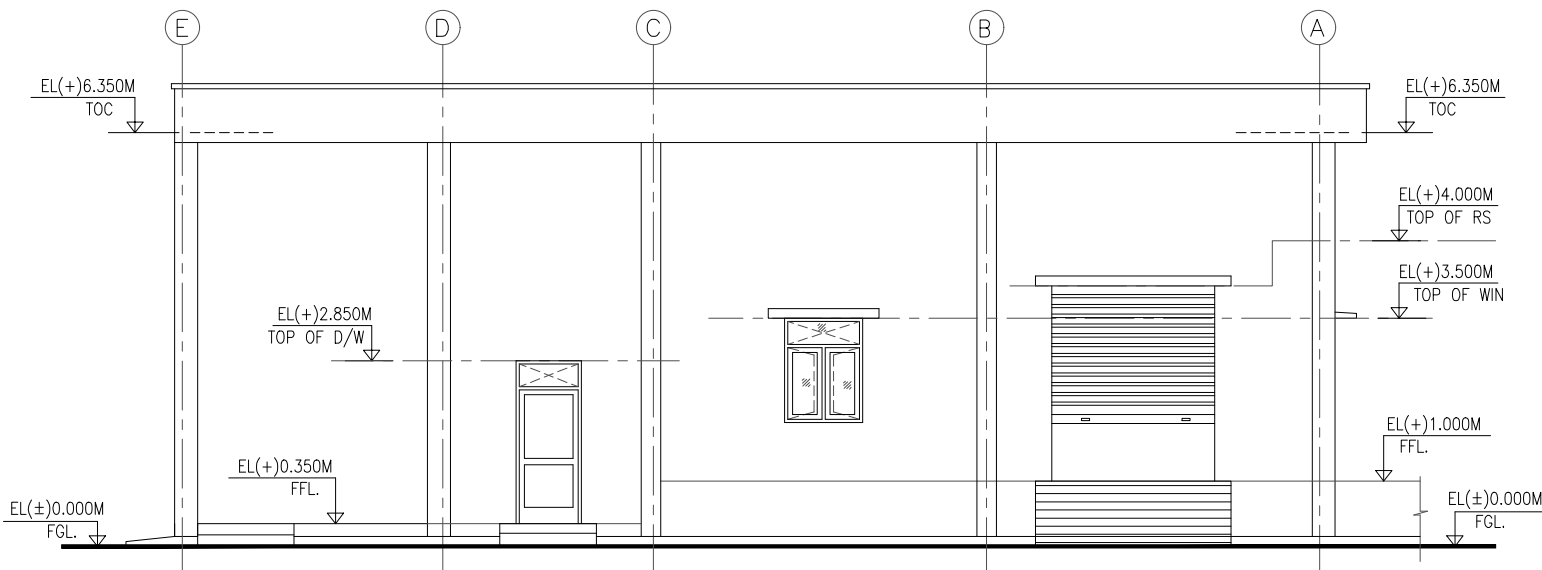


ELEVATION-3

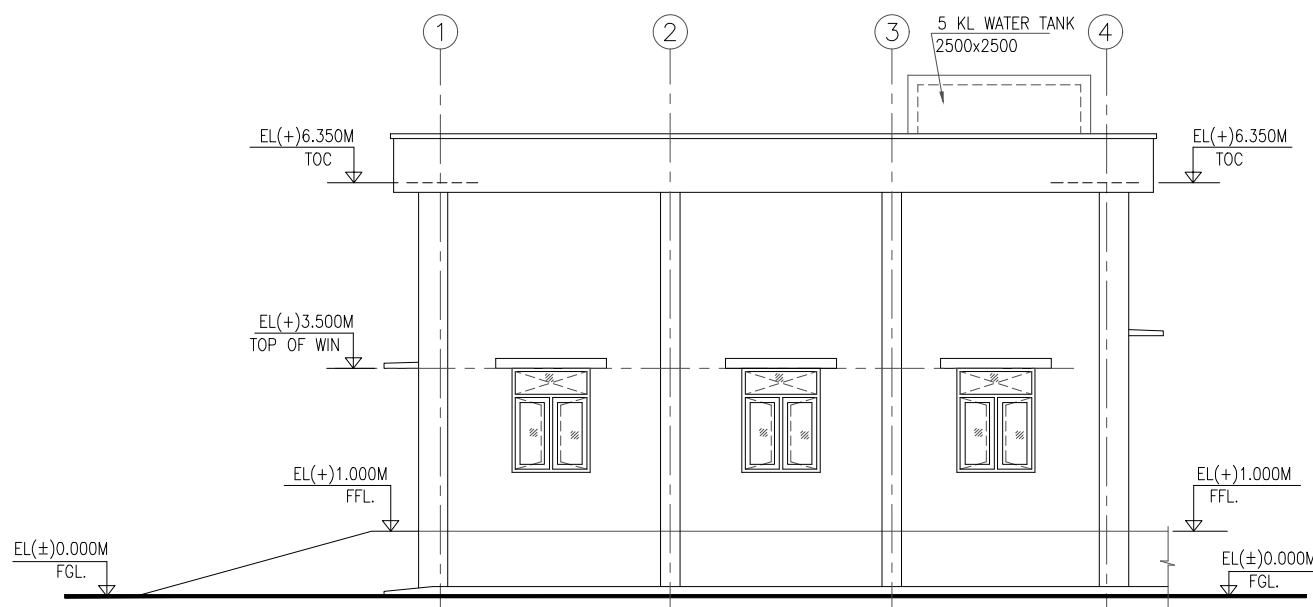

ELEVATION-2

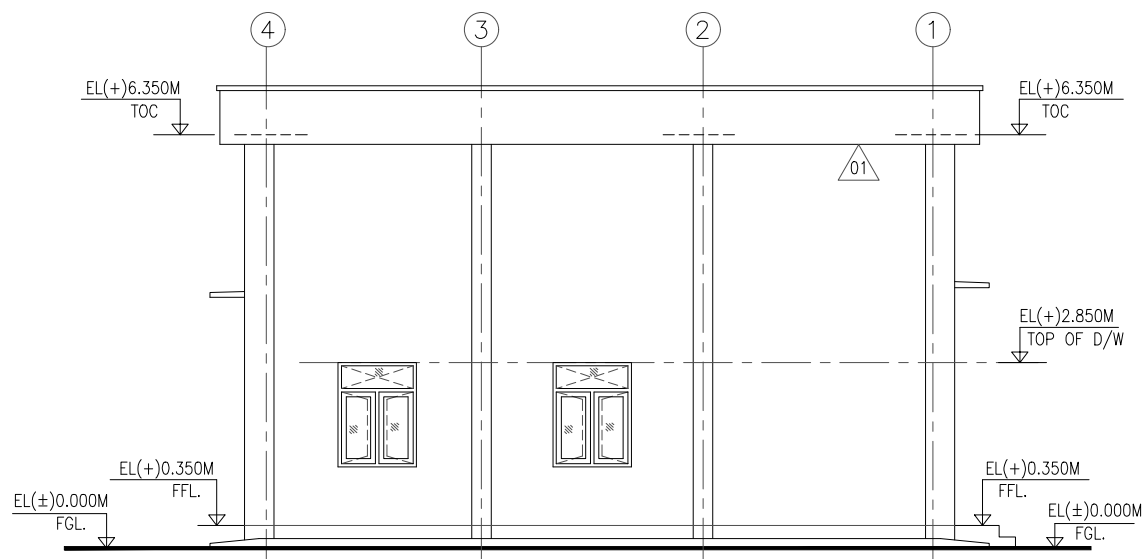

ELEVATION-4

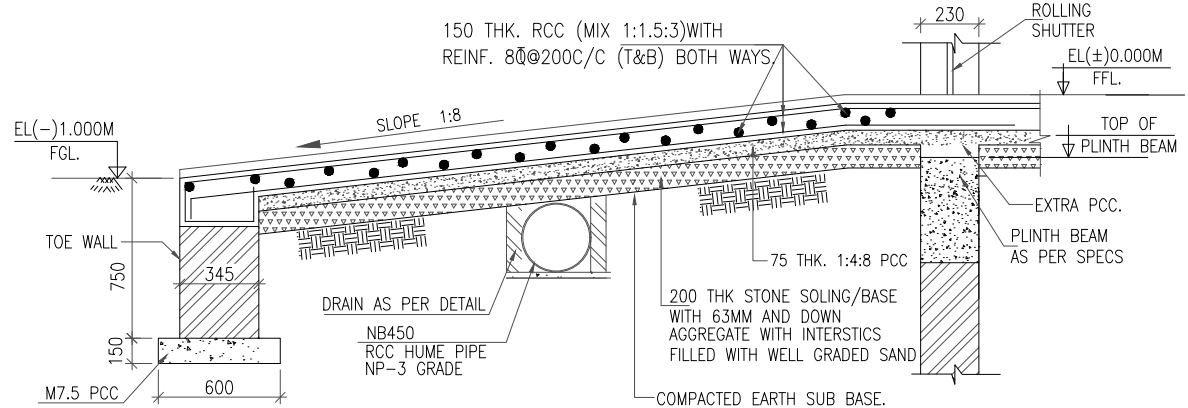

DETAIL OF RAMP

NOTES:-

- 1 ALL DIMENSIONS ARE IN MILLIMETERS AND LEVELS ARE IN METERS UNLESS OTHERWISE SPECIFIED.
- 2 ALL DOOR-WINDOW, ETC. HEIGHT SHALL BE CONSIDERED FROM FINISH FLOOR LEVEL.

PROJECT:	400/220kVGIS SUBSTION AT ERSAMA, ODISHA & 400kv AIS FEEDER BAY EXTENSION AT DUBURI, ODISHA			
OWNER:	ODISHA POWER TRANSMISSION CORPORATION LIMITED			
	NAME	SIGN.	DATE	NO.OF VAR.
	DRN. RDA CIVIL	--sd--	01.08.2023	N.A.
	CHD. SV/AR	--sd--	01.08.2023	N.A.
DEPT. TBG CODE	UNTOL. DIMS. GR q/m/f	SCALE N.T.S	WEIGHT (KG) N.A.	REF. TO ASSY. DRG. N.A.
TITLE	FIRE FIGHTING PUMP HOUSE & DG ROOM- SECTIONS & ELEVATIONS			ITEM NO. N.A.
CARD CODE NA	TB-1-420-607-721			REV. 01
SHT. No 01		NO. OF SHT. 01		

REV.	DATE	ALTERED	REV.	DATE	ALTERED
		CHD/APPD			CHD/APPD
ZONE			ZONE		

REV.	DATE	ALTERED	REV.	DATE	ALTERED
		CHD/APPD			CHD/APPD
ZONE			ZONE		

REV.	DATE	ALTERED	REV.	DATE	ALTERED
		CHD/APPD			CHD/APPD
ZONE			ZONE		

8

7

6

5

4

3

2

1

SIZE-A1

THE INFORMATION ON THIS DOCUMENT IS THE PROPERTY OF BHARAT HEAVY ELECTRICALS LIMITED. IT MUST NOT BE USED DIRECTLY OR INDIRECTLY IN ANY WAY DETRIMENTAL TO THE INTEREST OF THE COMPANY

FIRST ANGLE PROJECTION

(ALL DIMENSIONS ARE IN mm)

DRG. NO. TB-1-420-607-701

6


5

4


3

2


1

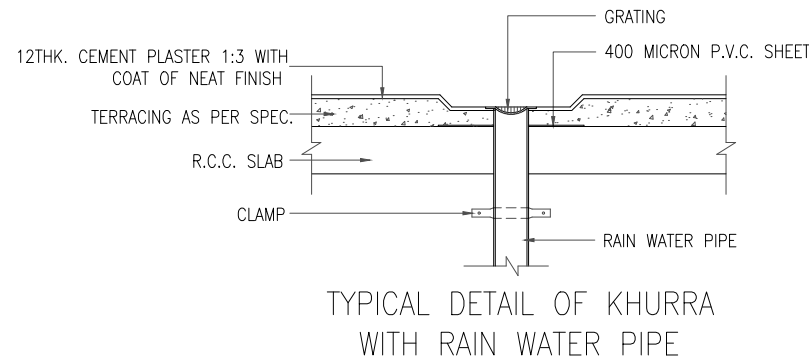


TYPICAL DETAIL OF KHURRA WITH RAIN WATER PIPE

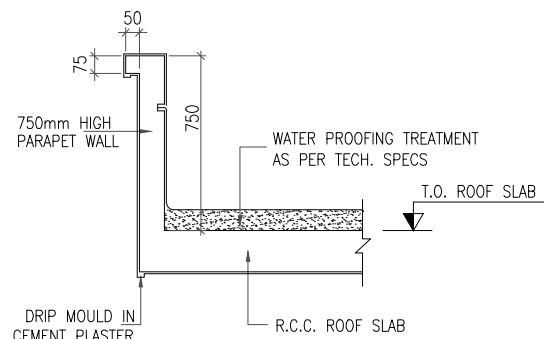

TYP. DETAIL OF PARAPET

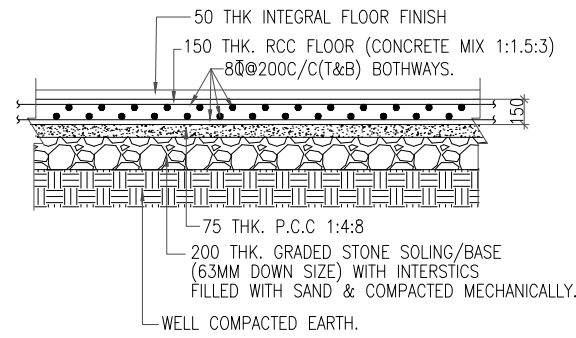

DETAIL OF GRADE SLAB

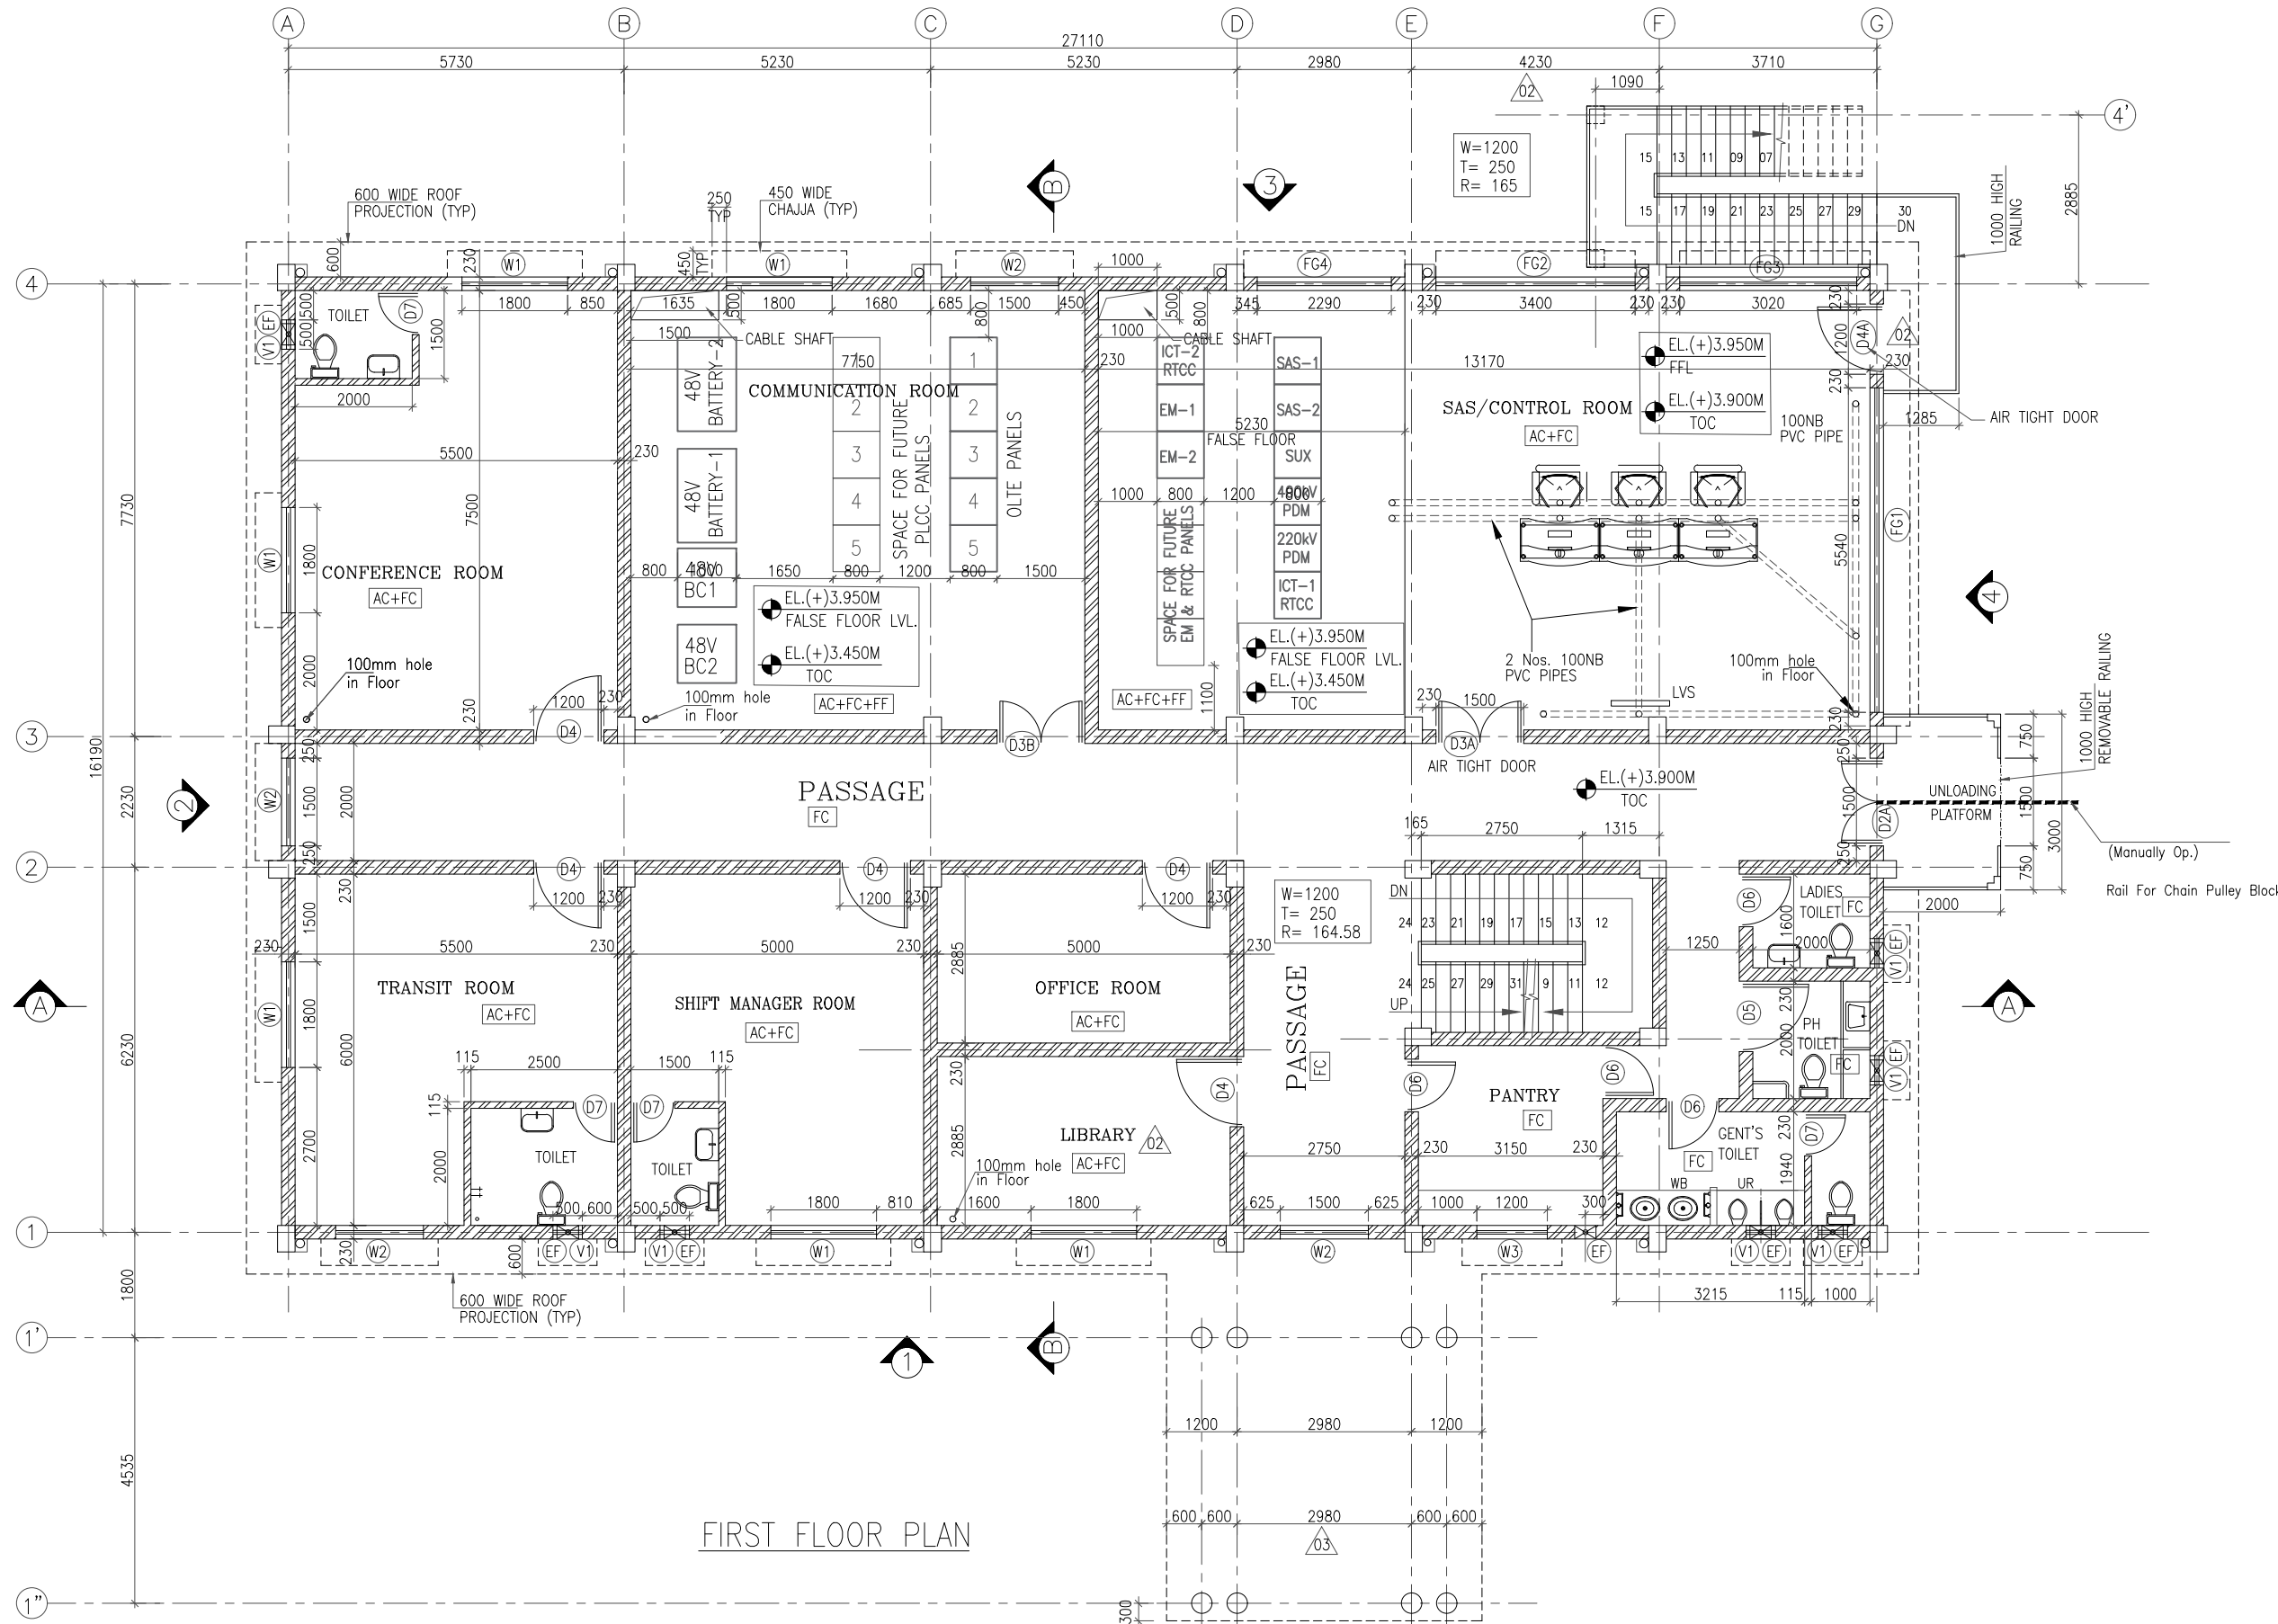

FIRST FLOOR PLAN

SCHEDULE OF FINISHES

(AS PER TECHNICAL SPECIFICATION)

1.0 BRICK WORK:

1.1 230mm THK. BRICK MASONRY IN C.M. (1:5) USING FLY ASH BRICK AS PER OPTCL TS.

2.0 PLASTER:

2.1 INTERNAL:
12mm THK. PLASTER (1:6 CEMENT : SAND) MORTAR ON SMOOTH SIDE OF WALL.
15mm THK. PLASTER (1:6 CEMENT : SAND) MORTAR ON ROUGH SIDE OF SINGLE OR HALF BRICK WALL.

2.2 EXTERNAL:
18mm THK. PLASTER IN TWO LAYER.
UNDER LAYER 12mm THK. (1:5 CEMENT : SAND) MORTAR AND TOP LAYER 6mm THK. (1:3 CEMENT : SAND) MORTAR
2.3 CEILING EXCEPT FOR WHERE FALSE CEILING WILL BE PROVIDED.
6mm THK. PLASTER (1:3 CEMENT : SAND)

3.0 FLOORING:

3.1 OFFICE, PASSAGE, TRANSIT ROOM, CONFERENCE RM, SAS ROOM:-
DOUBLE CHARGED GLAZED VITRIFIED DIGITAL TILE FLOORING AS PER OPTCL TS. 02

3.2 BATTERY ROOM:-
ACID AND ALKALI RESISTANT TILES FLOORING.
ACID AND ALKALI RESISTANT TILES UPTO FULL WALL OF BATTERY ROOM. 02

3.3 LT SWITCH GEAR ROOM, MAINTENANCE ROOM, STORE ROOM:-
DOUBLE CHARGED GLAZED VITRIFIED DIGITAL TILE FLOORING AS PER OPTCL TS. 02

3.4 SHIFT MANAGER ROOM, CHARGER ROOM, STORE ROOM:-
DOUBLE CHARGED GLAZED VITRIFIED DIGITAL TILE FLOORING AS PER OPTCL TS. 02

3.5 TOILET, PANTRY:-
ANTI-SKID CERAMIC DIGITAL TILES IN TOILET FLOORING AND DOUBLE CHARGED VITRIFIED DIGITAL TILE IN PANTRY FLOORING AND SAME TILE ON WALL UPTO CEILING.

3.6 SKIRTING:-
230 HIGH SKIRTING MATCHING WITH THE FLOOR SHALL BE PROVIDED.

5.0 PAINTING, AS PER TS MENTIONED IN CIVIL (PAINTING DETAILS)

5.1 INSIDE FACES OF BRICK WALL WILL HAVE PLASTIC EMULSION/ACRYLIC EMULSION PAINT IN ALL AC AREA, DISTEMPER IN ALL OTHER AREA AND IN TOILET WILL HAVE ABOVE DADO WHITE WASH.

5.2 OUTSIDE FACES OF WALL BE ACRYLIC SMOOTH EXTERIOR PAINT OVER PLASTER SURFACE.

5.3 CEILING TO HAVE PLASTIC EMULSION PAINT, IN BATTERY ROOM HAVE ACID PROOF PAINT.
FALSE CEILING IN PASSAGE AT FIRST FLOOR, CHARGER ROOM, TRANSIT ROOM, SAS ROOM, OFFICE ROOM, CONFERENCE ROOM, CHARGER ROOM, TOILET & PANTRY.

6.0 FURNITURE

6.1 CHAIR, TABLE/DESK & OTHER FURNITURE SHOWN IN THIS DRAWING ARE INDICATIVE. THEIR SUPPLY IS NOT IN THE SCOPE OF BHEL.

WATER PROOFING ON ROOF:

CEMENT BASED WATER PROOFING TREATMENT OF ROOFS BALCONIES, TERRACES ETC. SHALL BE PROVIDED WITH AVERAGE THICKNESS OF 120MM AND MINIMUM THICKNESS AT KHURRA AS 65 MM AND LAID CONSISTING OF THE FOLLOWING OPERATIONS:

(A) A SLURRY COAT OF NEAT CEMENT USING 2.75 KG/SQM OF CEMENT ADMIXED WITH PROPRIETARY WATER PROOFING COMPOUNDS CONFORMING TO IS: 2645 SHALL BE APPLIED AND GROUTED OVER THE RCC SLAB INCLUDING CLEANING THE SURFACE BEFORE TREATMENT.

(B) PLAIN CEMENT CONCRETE 1:5:10 (1: CEMENT: 5 FINE SAND: 10 BURNED BRICK AGGREGATE OF 40 MM NOMINAL SIZE) ADMIXED WITH PROPRIETARY WATER PROOFING COMPOUND CONFORMING TO IS: 2645 OVER 20 MM THICK LAYER OF CEMENT MORTAR OF MIN :5 (CEMENT :5 COARSE SAND) ADMIXED WITH PROPRIETARY WATER PROOFING COMPOUND CONFORMING TO IS: 2645 TO REQUIRED SLOPE AND TREATING SIMILARLY THE ADJOINING WALLS UPTO 300 MM HEIGHT INCLUDING ROUNDING OF JUNCTIONS OF WALLS AND SLABS.

(C) AFTER TWO DAY OF PROPER CURING A SECOND COAT OF CEMENT SLURRY ADMIXED WITH PROPRIETARY WATER PROOFING COMPOUND CONFORMING TO IS: 2645 SHALL BE APPLIED.

(D) THE SURFACE SHALL BE FINISHED WITH 20 MM THICK JOINT LESS CEMENT MORTAR OF MIX 1:4 (1 CEMENT :4 COURSE SAND) ADMIXED WITH PROPRIETARY WATER PROOFING COMPOUND CONFORMING TO IS : 2645 AND FINALLY THE SURFACE SHALL BE FINISHED WITH TROWEL WITH NEAT CEMENT SLURRY AND MAKING OF 300 X 300 MM SQUARE

(E) THE WHOLE TERRACE SO FINISHED SHALL BE FLOODED WITH WATER FOR A MINIMUM PERIOD OF TWO WEEKS FOR CURING AND FOR FINAL TEST. ALL ABOVE OPERATIONS SHALL BE DONE IN ORDER AN AS DIRECTED AND SPECIFIED BY THE ENGINEER-IN CHARGE.

NOTES:-

1 ALL DIMENSIONS ARE IN MILLIMETERS AND LEVELS ARE IN METERS UNLESS OTHERWISE SPECIFIED.

2 ALL DOOR-WINDOW, ETC. HEIGHT SHALL BE CONSIDERED FROM FINISH FLOOR LEVEL.

PROJECT:	400/220kVGIS SUBSTION AT ERSAMA, ODISHA & 400kv AIS FEEDER BAY EXTENSION AT DUBURI, ODISHA			
OWNER:	ODISHA POWER TRANSMISSION CORPORATION LIMITED			
	BHARAT HEAVY ELECTRICALS LTD.		NAME	SIGN.
	TRANSMISSION BUSINESS GROUP		DRN.	DATE
	NOIDA		CHD.	NO.OF VAR.
DEPT. TBG CODE	UNTOL. DIMS. GR. q/m/f	SCALE N.T.S	WEIGHT (KG) N.A.	REF. TO ASSY. DRG. N.A.
TITLE			ITEM NO. N.A.	NO.OF ITEMS N.A.
CONTROL ROOM BUILDING - FIRST FLOOR PLAN			DRG.NO. TB-1-420-607-701	REV. 03
			SHT. No 01	NO. OF SHT. 01

REV.	DATE	ALTERED	REV.	DATE	ALTERED	REV.	DATE	ALTERED	REV.	DATE	ALTERED
		CHD/APPD	03	13-10-23	CHD/APPD	02	18-08-23	CHD/APPD	01	14-06-23	CHD/APPD
ZONE			ZONE			ZONE			ZONE		

REVISED AS PER COMMENTS BY OPTCL DTD. 11.10.23.

REVISED AS PER COMMENTS BY OPTCL

REVISED AS PER COMMENTS BY OPTCL INFORMED IN THE DISCUSSIONS & MEETING DTD. 22-25.05.2023 AT OPTCL BHUBANESWAR OFFICE AND AS PER ELECTRICAL / MECHANICAL REQUIREMENTS.

8

7

6

5

4

3

2

1

SIZE-A1

THE INFORMATION ON THIS DOCUMENT IS THE PROPERTY OF BHARAT HEAVY ELECTRICALS LIMITED. IT MUST NOT BE USED DIRECTLY OR INDIRECTLY IN ANY WAY DETRIMENTAL TO THE INTEREST OF THE COMPANY

FIRST ANGLE PROJECTION

(ALL DIMENSIONS ARE IN mm)

DRG. NO. TB-1-420-607-703

6

5

4

3

2

1

F

E

D

C

B

A

F


E

D


C

B


A

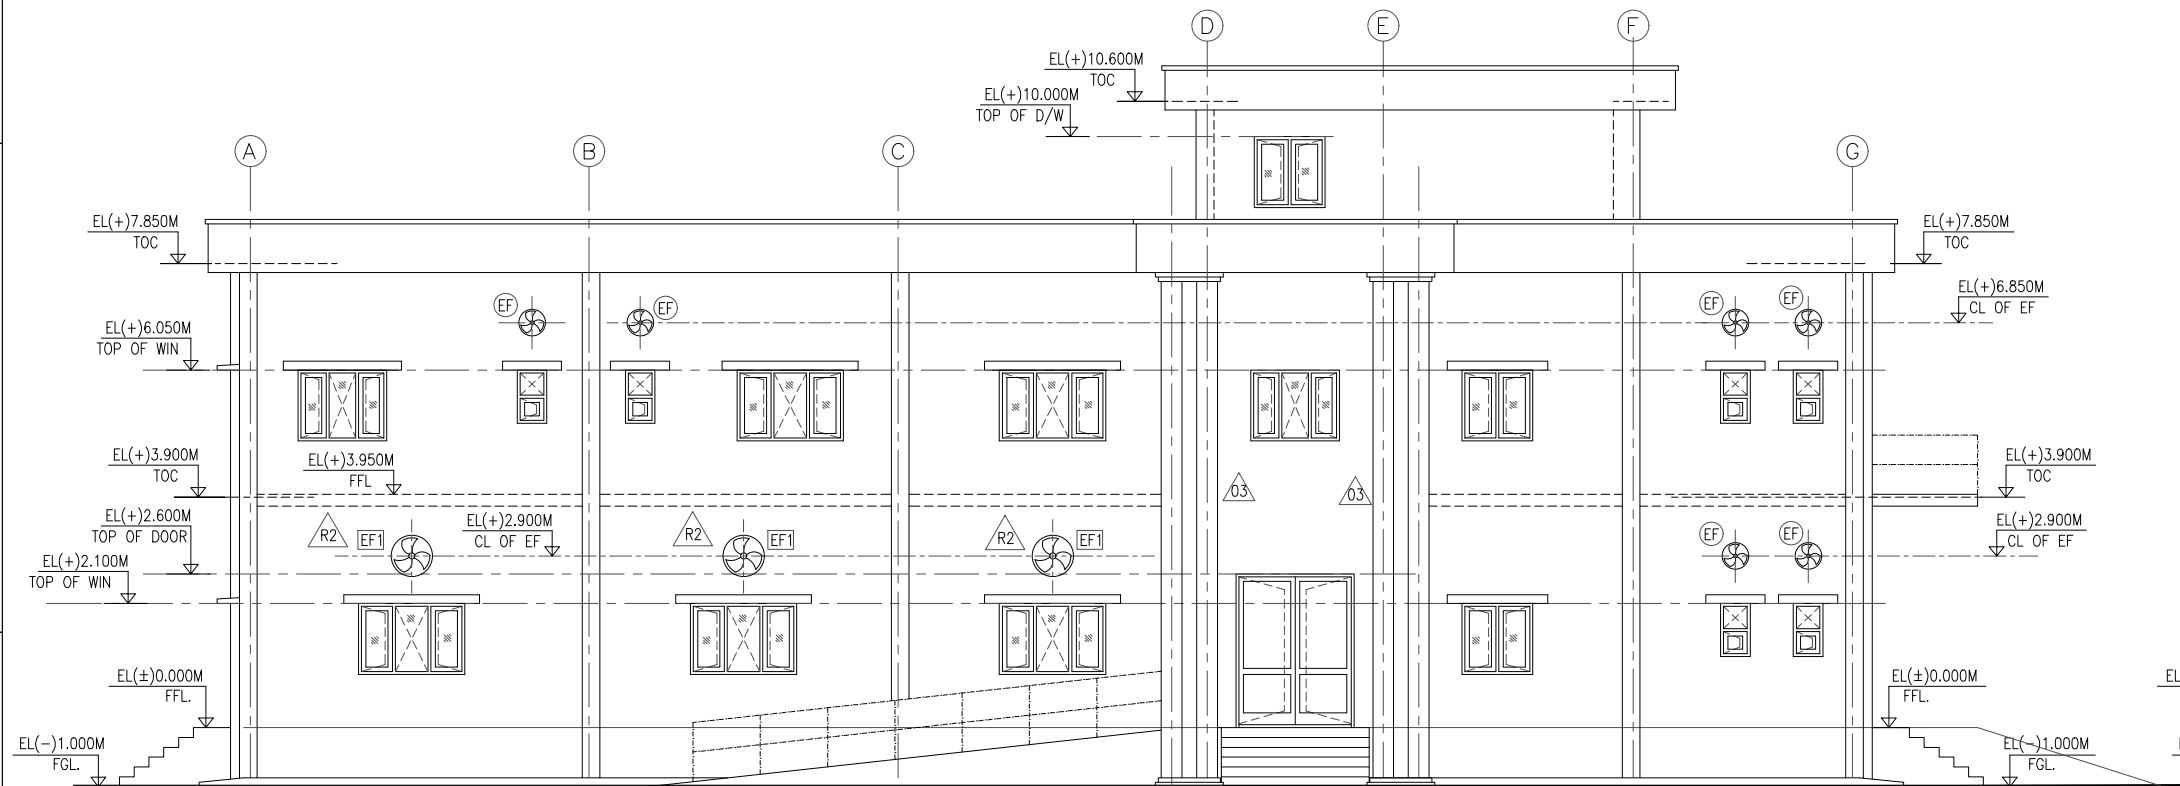

ELEVATION-1

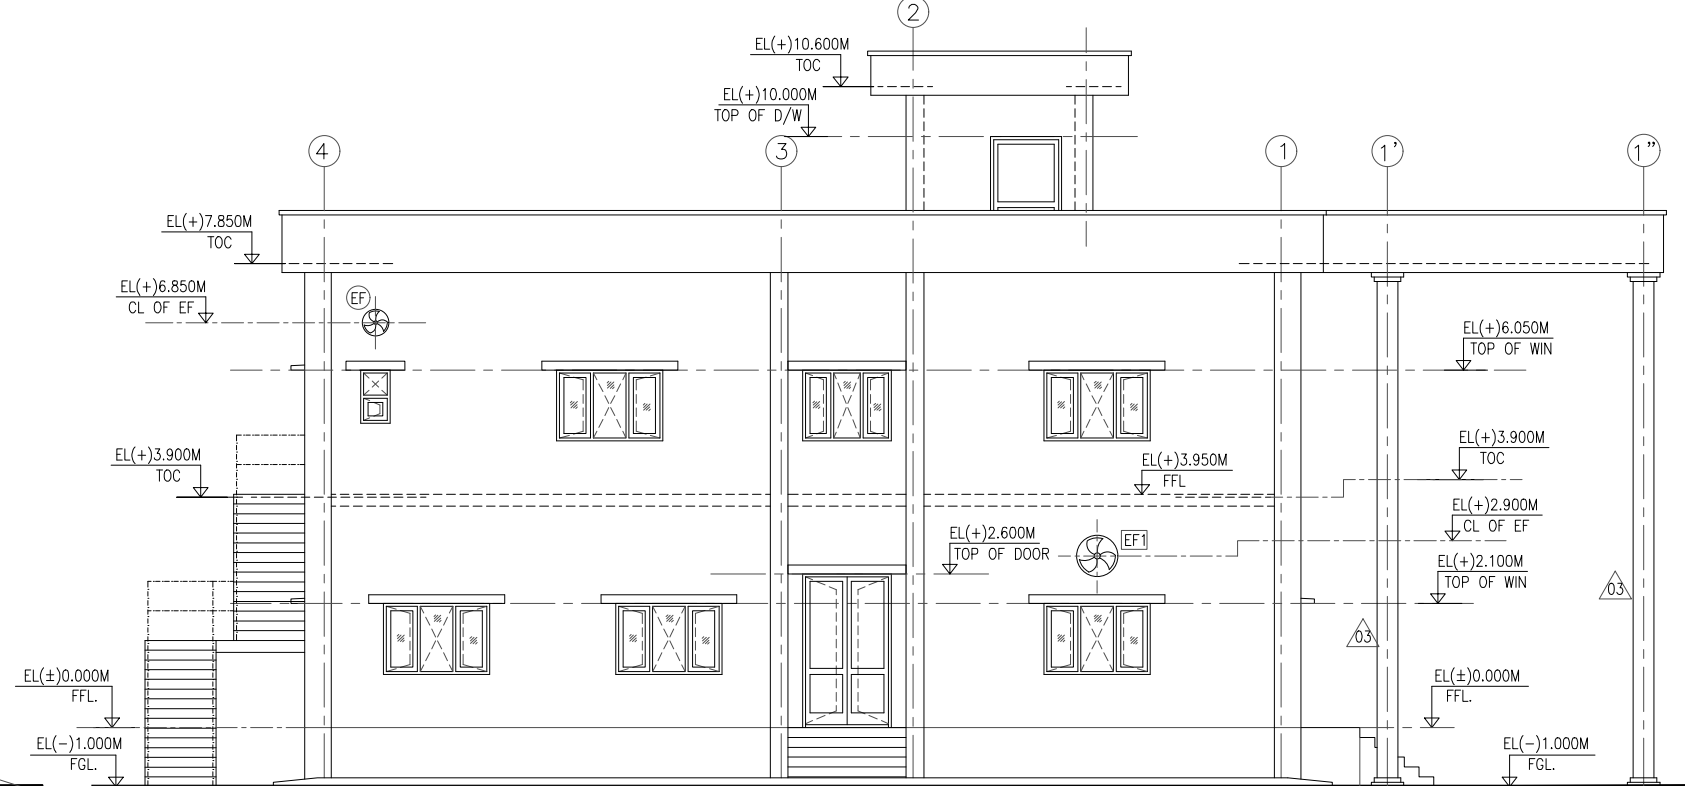

ELEVATION-2

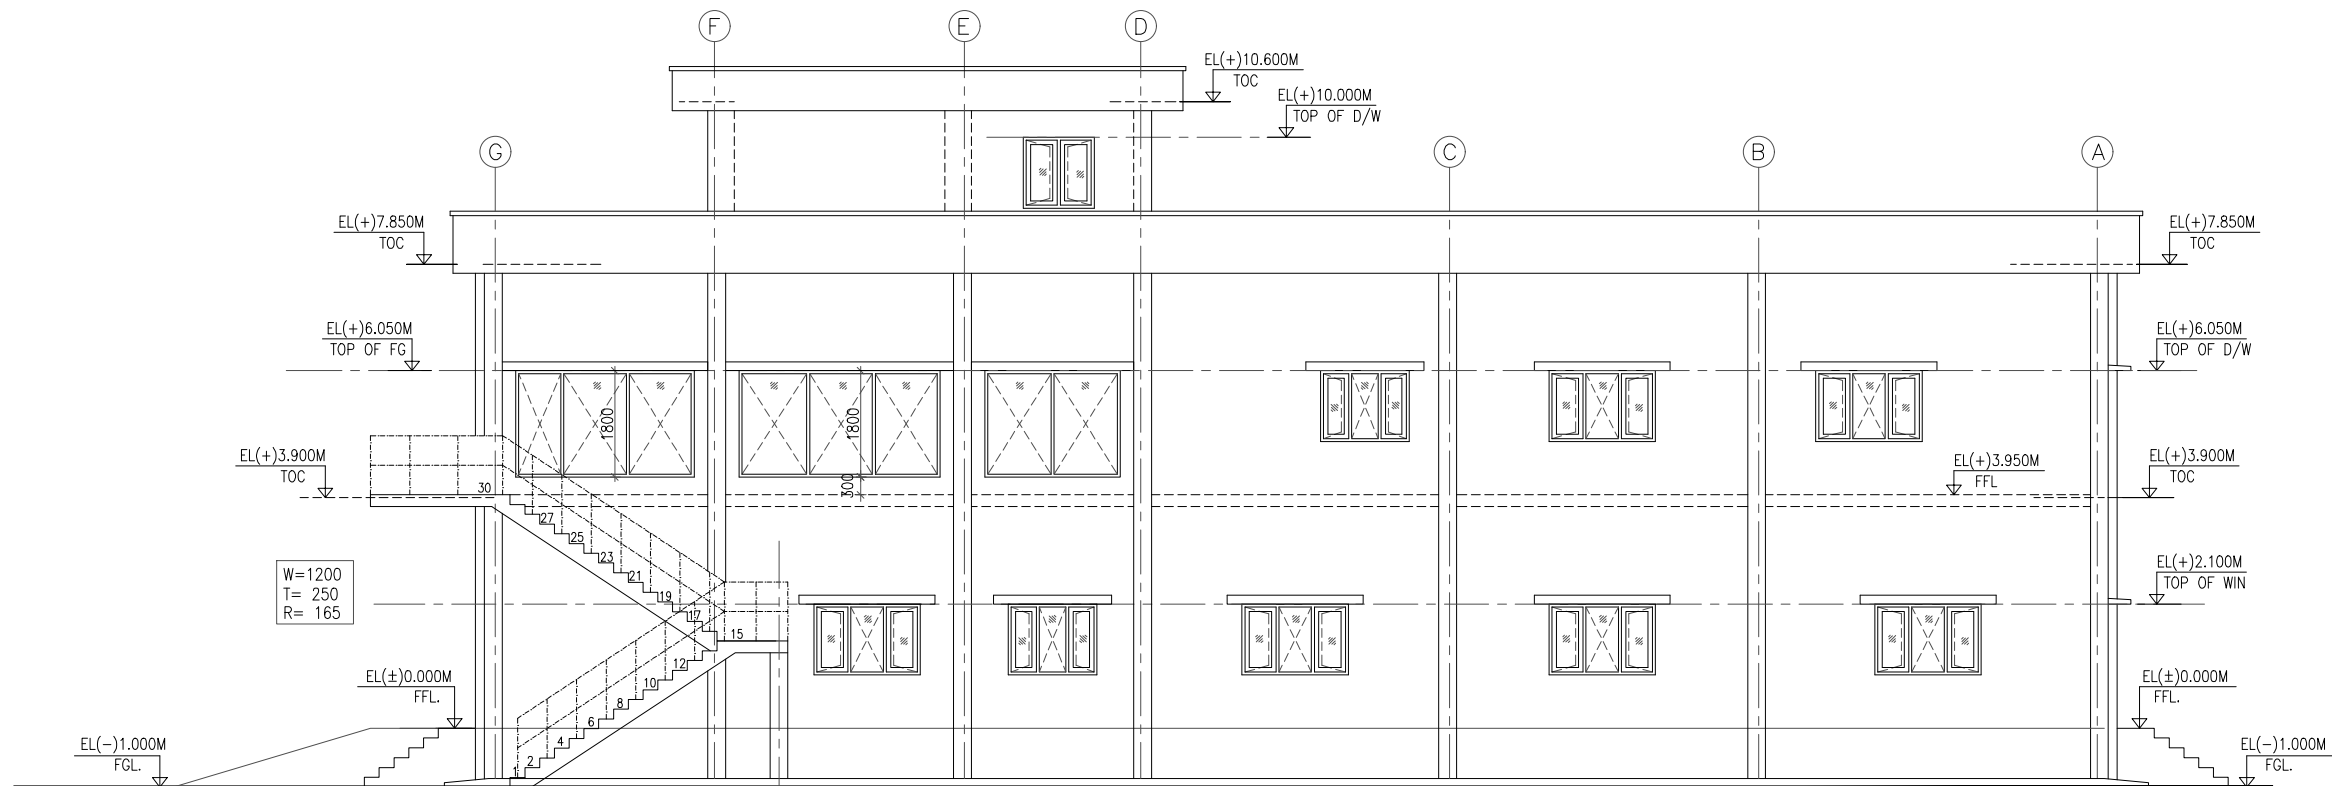


ELEVATION-3

NOTES:-

1 ALL DIMENSIONS ARE IN MILLIMETERS AND LEVELS ARE IN METERS UNLESS OTHERWISE SPECIFIED.

 2 ALL DOOR-WINDOW, ETC. HEIGHT SHALL BE CONSIDERED FROM FINISH FLOOR LEVEL.

PROJECT:		400/220kV GIS SUBSTION AT ERSAMA, ODISHA & 400kV AIS FEEDER BAY EXTENSION AT DUBURI, ODISHA							
OWNER:			ODISHA POWER TRANSMISSION CORPORATION LIMITED						
		BHARAT HEAVY ELECTRICALS LTD. TRANSMISSION BUSINESS GROUP NOIDA		NAME		SIGN.	DATE	NO. OF VARIATIONS	
				DRN. RDA CIVIL		--sd--	01.05.2023		
				CHD. SV/AK		--sd--	02.05.2023		
				APPD. PLK		--sd--	02.05.2023		
DEPT. TBG	UNTOL. DIMS. GR.		SCALE	WEIGHT (KG)	REF. TO ASSY. DRG.		ITEM NO.	NO. OF ITEMS	
CODE	g/m/f		N.T.S	N.A.	N.A.		N.A.	N.A.	
TITLE					DRG.NO.	REV.			
CONTROL ROOM BUILDING – ELEVATIONS					CARD CODE NA	TB-1-420-607-703			R C
						SHT. No 01		NO. OF SHT. 01	

REV.	DATE	ALTERED	REV.	DATE	ALTERED RDA CIVIL	REV.	DATE	ALTERED RDA CIVIL	REV.	DATE	ALTERED RDA CIVIL
		CHD/APPD	03	13-10-23	CHD/APPD SV/AK	02	18-08-23	CHD/APPD SV/AK	01	14-06-23	CHD/APPD SV/AK
ZONE			ZONE	REVISED AS PER COMMENTS BY OPTCL DTD. 11.10.23.		ZONE	REVISED AS PER COMMENTS BY OPTCL		ZONE	REVISED AS PER COMMENTS BY OPTCL INFORMED IN THE DISCUSSIONS & MEETING DTD. 22-25.05.2023 AT OPTCL BHUBANESWAR OFFICE AND AS PER ELECTRICAL / MECHANICAL REQUIREMENTS..	

8

7

6

5

4

3

2

1





SIZE-A1

THE INFORMATION ON THIS DOCUMENT IS THE PROPERTY OF BHARAT HEAVY ELECTRICALS LIMITED. IT MUST NOT BE USED DIRECTLY OR INDIRECTLY IN ANY WAY DETRIMENTAL TO THE INTEREST OF THE COMPANY

FIRST ANGLE PROJECTION

DRG. NO. TB-1-420-607-702

(ALL DIMENSIONS ARE IN mm)

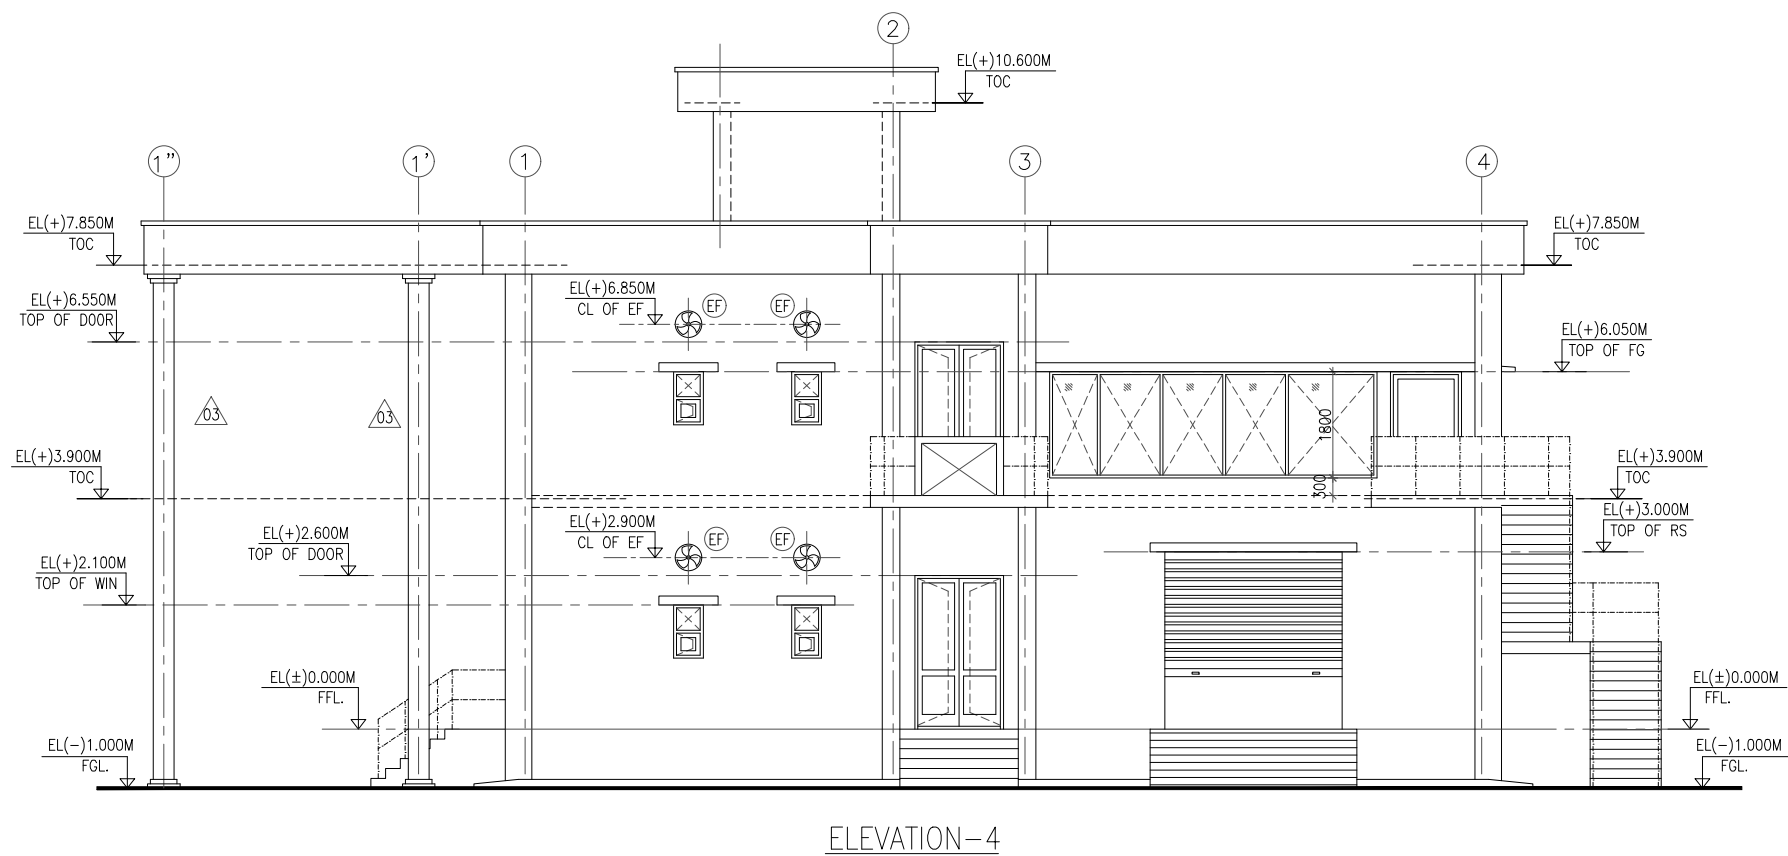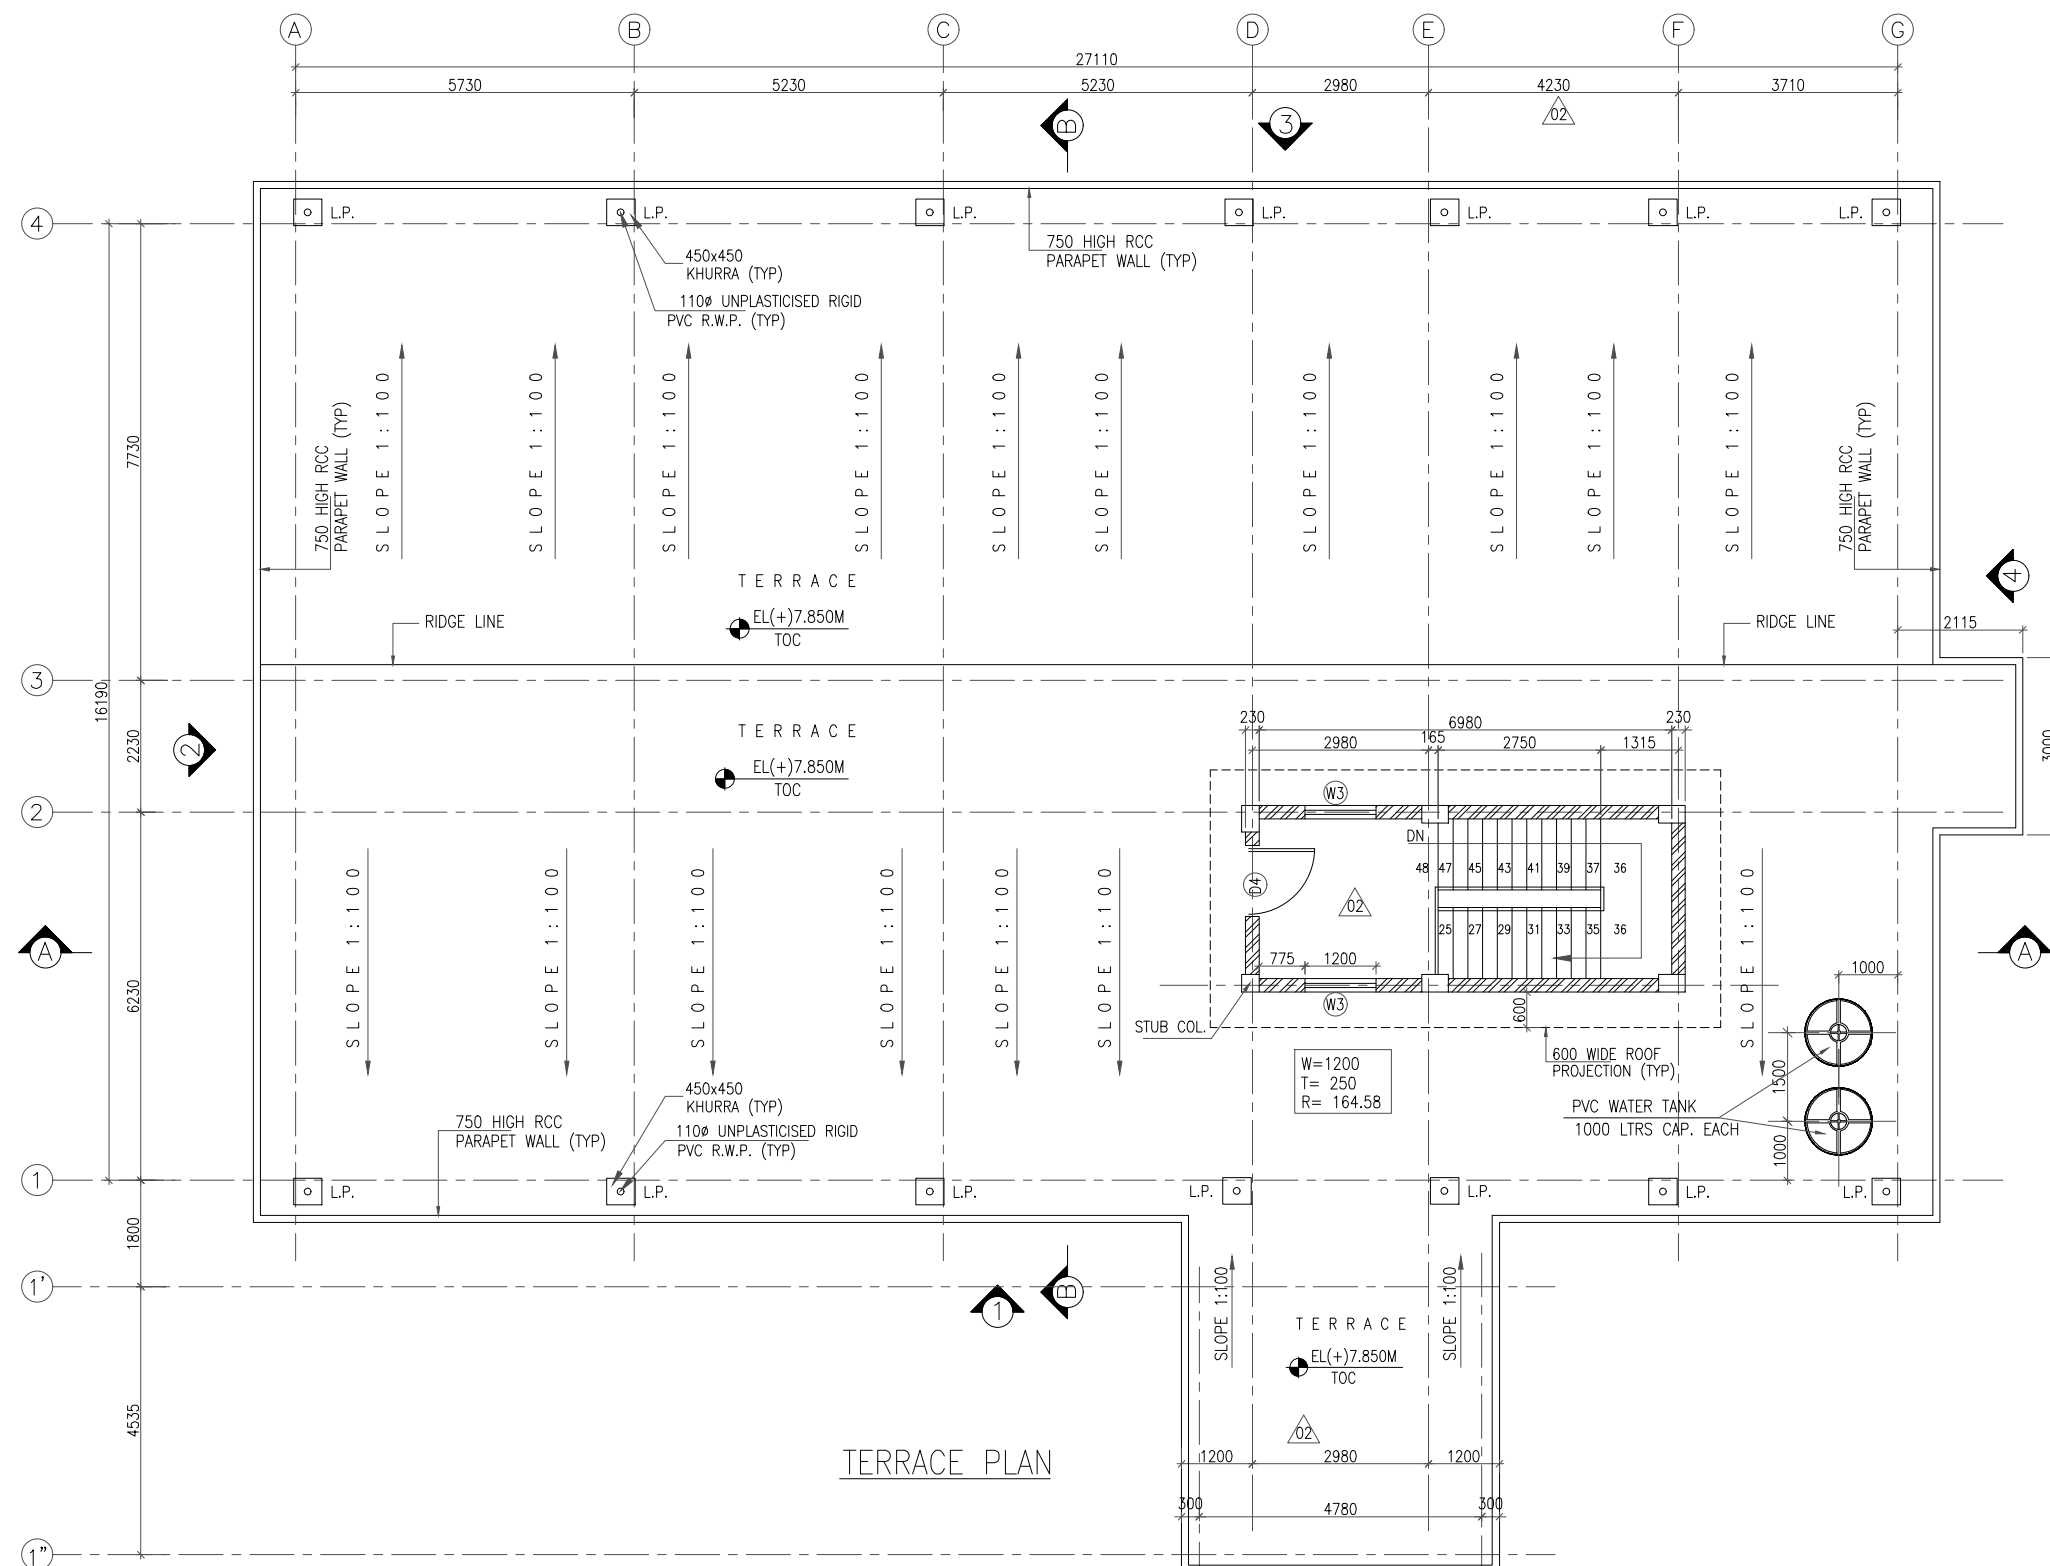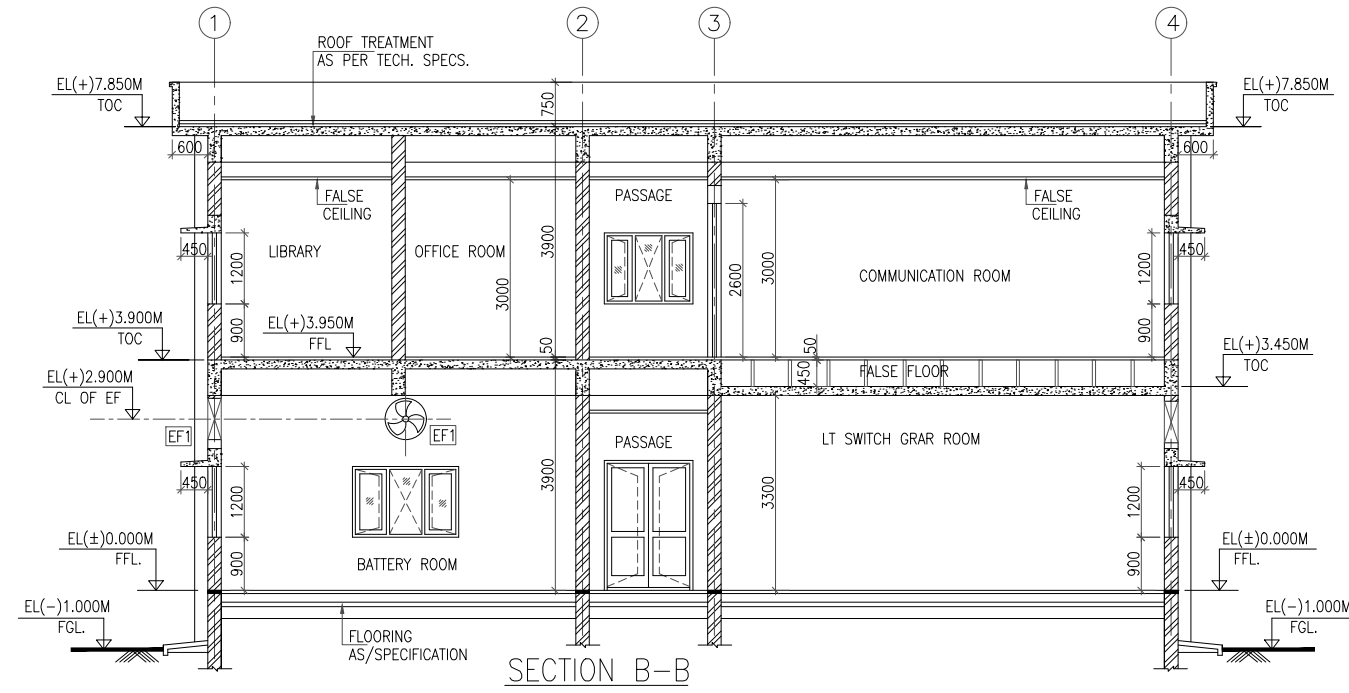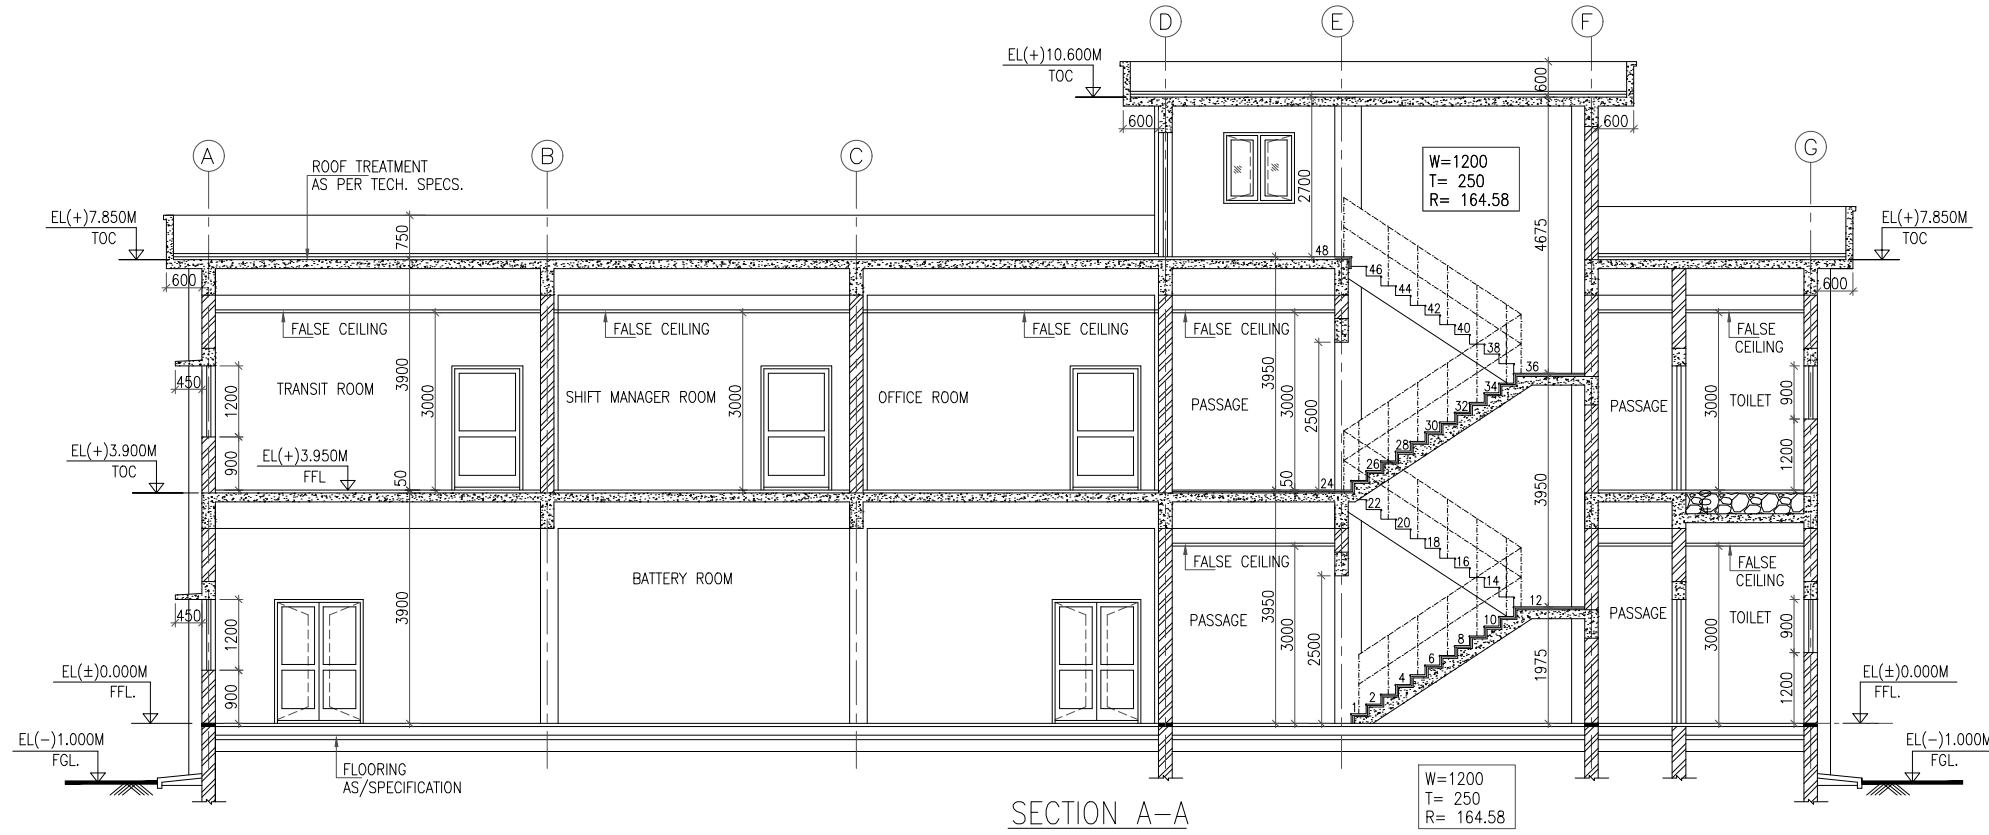

NOTES:-
1 ALL DIMENSIONS ARE IN MILLIMETERS AND LEVELS ARE IN METERS UNLESS OTHERWISE SPECIFIED.
2 ALL DOOR-WINDOW, ETC. HEIGHT SHALL BE CONSIDERED FROM FINISH FLOOR LEVEL.

PROJECT:	400/220kVGIS SUBSTION AT ERSAMA, ODISHA & 400kv AIS FEEDER BAY EXTENSION AT DUBURI, ODISHA			
OWNER:	ODISHA POWER TRANSMISSION CORPORATION LIMITED			
	NAME	SIGN.	DATE	NO.OF VAR.
	DRN. RDA CIVIL	--sd--	01.05.2023	N.A.
	CHD. SV/AK	--sd--	02.05.2023	N.A.
DEPT. TBG CODE	UNTOL. DIMS. GR. q/m/f	SCALE N.T.S	WEIGHT (KG) N.A.	REF. TO ASSY. DRG. N.A.
TITLE	CONTROL ROOM BUILDING - TERRACE PLAN & SECTIONS		CARD CODE NA	REV. 03
SHT. No 01		NO. OF SHT. 01		

REV.	DATE	ALTERED	REV.	DATE	ALTERED	REV.	DATE	ALTERED	REV.	DATE	ALTERED						
		RDA CIVIL			RDA CIVIL			RDA CIVIL									
		CHD/APPD	03	13-10-23	CHD/APPD SV/AK	02	18-08-23	CHD/APPD SV/AK	01	14-06-23	CHD/APPD SV/AK						
ZONE	REVISED AS PER COMMENTS BY OPTCL DTD. 11.10.23.					ZONE	REVISED AS PER COMMENTS BY OPTCL					ZONE	REVISED AS PER COMMENTS BY OPTCL INFORMED IN THE DISCUSSIONS & MEETING DTD. 22-25.05.2023 AT OPTCL				

8

7

6

5

4

3

2

1

 
SIZE-A1

TB-4-420-316-009

DRAWING NO.

LEGEND

CONNECTION TO GROUND MAT THROUGH RISER



CONNECTION TO PIPE ELECTRODE WITH TREATED EARTH PIT



75X10 G.I. FLAT



50x6mm GS FLAT



40mm DIA MS ROD

GENERAL NOTES:

- 1 EARTH STRIP CLEATED TO LATTICE /PIPE TYPE STRUCTURE AT AN INTERVAL OF 1.0M SUITABLE PROVISION SHALL BE MADE WITH SUPPORT STRUCTURE.
- 2 ALL EARTH STRIPS SHALL BE TAKEN ALONG EDGE OF STRUCTURE. ALL DRAWING SHOWS TYPICAL ARRANGEMENT ONLY.
- 3 ALL STRUCTURES/EQUIPMENTS SHALL BE EARTHED AS SHOWN IN THE FOLLOWING SHEETS.
- 4 BOLT SIZE FOR CONNECTING EARTHING FLAT TO THE EQPT/STRUCTURE SHALL BE TO SUIT RESPECTIVE HOLE SIZE.
5. ALL EARTHING SHALL BE DONE IN ACCORDANCE WITH IS:3043 UNLESS OTHERWISE STATED IN TECHNICAL SPECIFICATION
- 6 EACH RISER OF A PARTICULAR EQUIPMENT SHALL BE CONNECTED TO A DIFFERENT EARTHROD (EITHER HORIZONTAL OR VERTICAL CONDUCTORS OF MAIN EARTHMAT).
- 7 FOR WELDING DETAILS REFER SHEET #19 & 20.
- 8 E/WIRE DOWN CONDUCTOR SHALL BE CLEATED AT AN INTERVAL OF 2.0 M ALONG WITH STRUCTURE .
- 9 OEM DRAWING FOR GIS AND IT'S ACCESSORIES ITEM SHALL BE SUBMITTED SEPARATELY.

SHEET NO. DESCRIPTION

- | SHEET NO. | DESCRIPTION |
|-----------|--|
| 01. | TITLE |
| 02. | EARTHING NOTES |
| 03. | MATERIAL & SIZES OF BELOW & ABOVE GROUND EARTHING |
| 04. | 400kV & 220kV POST INSULATOR |
| 05. | 390kV & 216kV SURGE ARRESTER |
| 06. | 400kV HORIZONTAL DOUBLE BREAK ISOLATOR WITH ONE EARTH SWITCH (TYPICAL) |
| 07. | AUXILIARY EARTH MAT FOR ISOLATOR MAIN MECH.,E/S MECH. BOX |
| 08. | 400/220kV 315MVA AUTO TRANSFORMER & 33/0.433kV STATION TRANSFORMER |
| 09. | REACTOR |
| 10. | TOWER WITH PEAK |
| 11. | LIGHTENING MAST (LM) |
| 12. | GATE/FENCE POST |
| 13. | CABLE TRENCH |
| 14. | RAIL BONDING |
| 15. | PIPE EARTH ELECTRODE WITH TREATED PIT |
| 16. | DELETED |
| 17. | CONTROL AND RELAY PANELS/BATTERY CHARGER/ AC DC BOARDS/MLDB |
| 18. | TYPICAL ARRANGEMENT OF BOLTED JOINTS |
| 19. | WELDING DETAILS |
| 20. | WELDING DETAILS |

PROJECT		EQUIPMENT EARTHING PHILOSOPHY & DETAILS FOR 400kV/220kV GIS SUB STATION AT ERSAMA						
OWNER		ODISHA POWER TRANSMISSION CORPORATION LIMITED						
		BHARAT HEAVY ELECTRICALS LTD TRANSMISSION BUSINESS GROUP NOIDA		DEPT CODE M	NAME AK CHD AK APPD DKS	SIGN	DATE	
REV.		DATE	ALTERED	AK	TITLE			
01		16.03.24	CHECKED	AK	EQUIPMENT EARTHING PHILOSOPHY AND DETAILS FOR 400/220kV GIS SUB STATION AT ERSAMA			
ZONE		ZONE	APPROVED	VK	DRAWING NO.			
			DOCUMENT REVISED AS PER OPTCL COMMENTS.		TB-4-420-316-009			
					SHEET 01 OF 20			REV. 01

1. RISER FROM THE EARTH GRID SHALL BE 40MM DIAMETER MILD STEEL ROD. RISER SHALL RISE FROM THE GROUND ALONG THE NEAREST EQUIPMENT FOUNDATION/BUILDING COLUMN/WALL TO AVOID ANY OBSTRUCTION TO MOVEMENT OF PERSONNEL.
2. CONNECTION TO ALL EQUIPMENT AND TOWERS SHALL BE BY BOLTED JOINTS. CONTACT SURFACES SHALL BE THOROUGHLY CLEANED BEFORE CONNECTIONS. EQUIPMENT BOLTED CONNECTIONS AFTER BEING TESTED AND CHECKED SHALL BE PAINTED WITH ANTI CORROSIVE PAINT/COMPOUND.
3. CONNECTIONS BETWEEN EQUIPMENT EARTHING LEADS AND BETWEEN MAIN EARTHING CONDUCTORS SHALL BE OF WELDED TYPE. FOR RUST PROTECTION THE WELDS SHOULD BE TREATED WITH RED LEAD COMPOUND AND AFTERWARDS THICKLY COATED WITH BITUMEN COMPOUND.
THE SURFACES TO BE WELDED SHALL BE CLEANED OF DIRT, OIL, GREASE AND OXIDES BEFORE WELDING. ANY OXIDE FILMS THAT MAY HAVE FORMED DURING WELDING MUST BE REMOVED FROM THE WELDED JOINT.
4. EARTHING CONDUCTOR FOR EQUIPMENT SHALL BE OF GALVANISED STEEL OF SIZE 75x10/50x6 mm. THE CONDUCTOR BELOW THE GROUND LEVEL SHALL BE 40 mm DIA MS ROD.
5. IN THE ATTACHED DRAWINGS FGL REPRESENTS FINISHED GROUND LEVEL.
6. ALL EQUIPMENT STRUCTURES & TOWERS SHALL BE EARTHED AT TWO POINTS WITH 75x10 mm GI FLAT EVEN THOUGH THEY ARE SHOWN OR NOT IN THE DRAWING DUE TO CLARITY.
7. ALL JUNCTION BOXES, MECHANISM BOXES, GROUND MOUNTED CONTROL CABINETS, CUBICLES, PANELS, MBs ETC. SHALL BE EARTHED AT TWO POINTS WITH 50x6mm G.I. FLAT BY TWO SEPARATE AND DISTINCT EARTH CONNECTERS.
8. THE GROUNDING MAT (40mm DIA. MS ROD) SHALL BE BURIED AT 700mm BELOW FGL IN COMPLETE FENCED AREA AND EXTENDING 2m BEYOND THE FENCE. AT THE PERIPHERY OF MAIN MAT, PIPE ELECTRODES AT EVERY 5m SHALL BE PROVIDED.
9. EARTHING CONDUCTORS FROM EQUIPMENT STRUCTURES SHALL BE CONNECTED TO THE NEAREST POSSIBLE EARTH MAT RISER. EQUIPMENT EARTHING SHALL BE AS PER IS 3043.
10. ALL JOINTS BETWEEN 40 DIA M.S. ROD AND 75x10 mm. G.I. FLAT SHALL BE 150mm ABOVE GROUND LEVEL.
11. FOR WELDED JOINTS LOW HYDROGEN CONTENT ELECTRODES SHALL BE USED.
12. METTALIC SHEATHS/SCREENS, AND ARMOUR OF MULTI CORE CABLES SHALL BE EARTHED AT BOTH ENDS. METTALIC SHEATHS AND ARMOUR OF SINGLE CORE CABLES SHALL BE EARTHED AT SWITCHGEAR END ONLY UNLESS OTHERWISE INSTRUCTED BY THE EMPLOYER.
13. EQUIPMENT BOLTED CONNECTIONS AFTER BEING TESTED AND CHECKED SHALL BE PAINTED WITH ANTI CORROSIVE PAINT/COMPOUND.
14. LOCATION OF EARTHING CONDUCTORS/RISERS SHOWN IN THE EARTHING DRAWING MAY CHANGE TO SUIT THE SITE CONDITION.
15. FOR SURGE ARRESTER, EARTHING LEAD FROM SURGE COUNTER TO MAIN EARTH MAT SHALL BE SHORTEST IN LENGTH AS PRACTICALLY AS POSSIBLE.
16. AN ADDITIONAL AUXILIARY GRID OF 1500MMX1500MM COMPRISING OF CLOSELY SPACED(300MMX300MM) 40mm DIA CONDUCTORS AT A DEPTH OF 300MM FROM FINISHED GROUND LEVEL SHALL BE PROVIDED BELOW THE OPERATING HANDLE OF ISOLATORS AND EARTH SWITCHES. THIS GRID SHALL BE CONNECTED TO THE MAIN GROUND GRID. THE EARTH CONNECTION TO OPERATING HANDLE SHALL BE MADE OF FLEXIBLE CONNECTION. THE MOM BOX OF THE ISOLATOR TO BE CONNECTED TO THIS AUX. GRID.
17. ALL NON CURRENT CARRYING METALIC PARTS SHALL BE EARTHED AT TWO DIFFERENT PLACES.
18. ALL EQUIPMENT DRAWINGS SHOWN ARE INDICATIVE ONLY.
19. WELDING OF EARTHING CONDUCTOR SHALL BE CONNECTED IN VERTICAL PLANE WHEREVER POSSIBLE.
20. ALL GROUND CONNECTIONS SHALL BE MADE BY ELECTRIC ARC WELDING.
21. ALL THE EQUIPMENT/ SYSTEM SHOWN ARE INDICATIVE AND SCHEMATIC, HENCE ANY ADDITIONAL REQUIREMENT PERTAINING TO EARTHING SHALL BE CARRIED OUT AT SITE TO MEET THE REQUIREMENT.
22. ANY OTHER SYSTEM/ EQUIPMENT FOR WHICH EARTHING PHILOSOPHY IS NOT COVERED HERE, SHALL BE DONE AS PER OEM RECOMMENDATION.



EQUIPMENT EARTHING DETAILS EARTHING NOTES

COMPUTER REF. NO.

DRG. No.

TB-4-420-316-009

SHEET No.
02

BELOW AND ABOVE GROUND EARTHING CONDUCTOR DETAILS :-

ANNEXURE - MATERIALS AND SIZE OF BELOW/ ABOVE GRADE GROUNDING SYSTEM				
TABLE 1: BELOW GROUND EARTHING SYSTEM - CONDUCTOR MATERIAL AND SIZE				
SL. No.	Description	Material	Size	Remarks
1	Main Grounding Grid Conductor	Mild Steel Rod	40mm Dia	
2	Auxiliary Grounding Mat Conductor	Mild Steel Rod	40mm Dia	
3	Riser (For connection between ground grid & above ground equipment earthing strip)	Mild Steel Rod	40mm Dia	
4	Electrode for Auto transformer/ Reactor/ Station & Lighting transformers' neutral and Surge Arresters	Mild Steel Pipe Electrode	50mm Dia, 3m Long	Treated pit with test link
5	Fence Corners, Main mat periphery, Down conductors/ corners of GIS building/ CRB/ FFPH building etc.	Mild Steel Pipe Electrode	50mm Dia, 3m Long	Treated pit with test link
TABLE 2: ABOVE GROUND EARTHING SYSTEM - CONDUCTOR MATERIAL AND SIZE				
SL. No.	Description	Material	Size (mm)	Remarks
1	400kV, 220kV & 33kV Outdoor Equipment	GI Mild Steel Flat	75 X 10	
2	400/220kV Auto Transformer, 400kV Reactor and 33/0.433kV Station Transformer	GI Mild Steel Flat	75 X 10	
3	Towers and Structure/ Lightning Masts	GI Mild Steel Flat	75 X 10	
4	Cable trench, hanger/ rack assembly and cable trestle	GI Mild Steel Flat	50 X 6	
4	Building Lightning Protection (if required)	GI Mild Steel Flat	50 X 6	
6	LT ACDB, DCDB and other Switchgear including Battery charger panel	GI Mild Steel Flat	50 X 6	
7	Control & Protection Panel, Control desk, Distribution Boards, Lighting Panels, Lighting Poles and lighting transformer	GI Mild Steel Flat	50 X 6	
8	Outdoor Kiosks, Junction Box	GI Mild Steel Flat	50 X 6	
9	HV/LV/ LV Neutral cable box, Drive mechanism boxes	GI Mild Steel Flat	50 X 6	
10	Gates and Fence	GI Mild Steel Flat flexible copper braid	75 X 10/ 50 X 6	
11	Lighting Fixtures and Receptacles	GI Steel Wire	16 SWG	




EQUIPMENT EARTHING DETAILS
MATERIAL & SIZES OF BELOW & ABOVE GROUND EARTHING

COMPUTERREF.NO.

DRG. No.

TB-4-420-316-009

SHEET No.
03

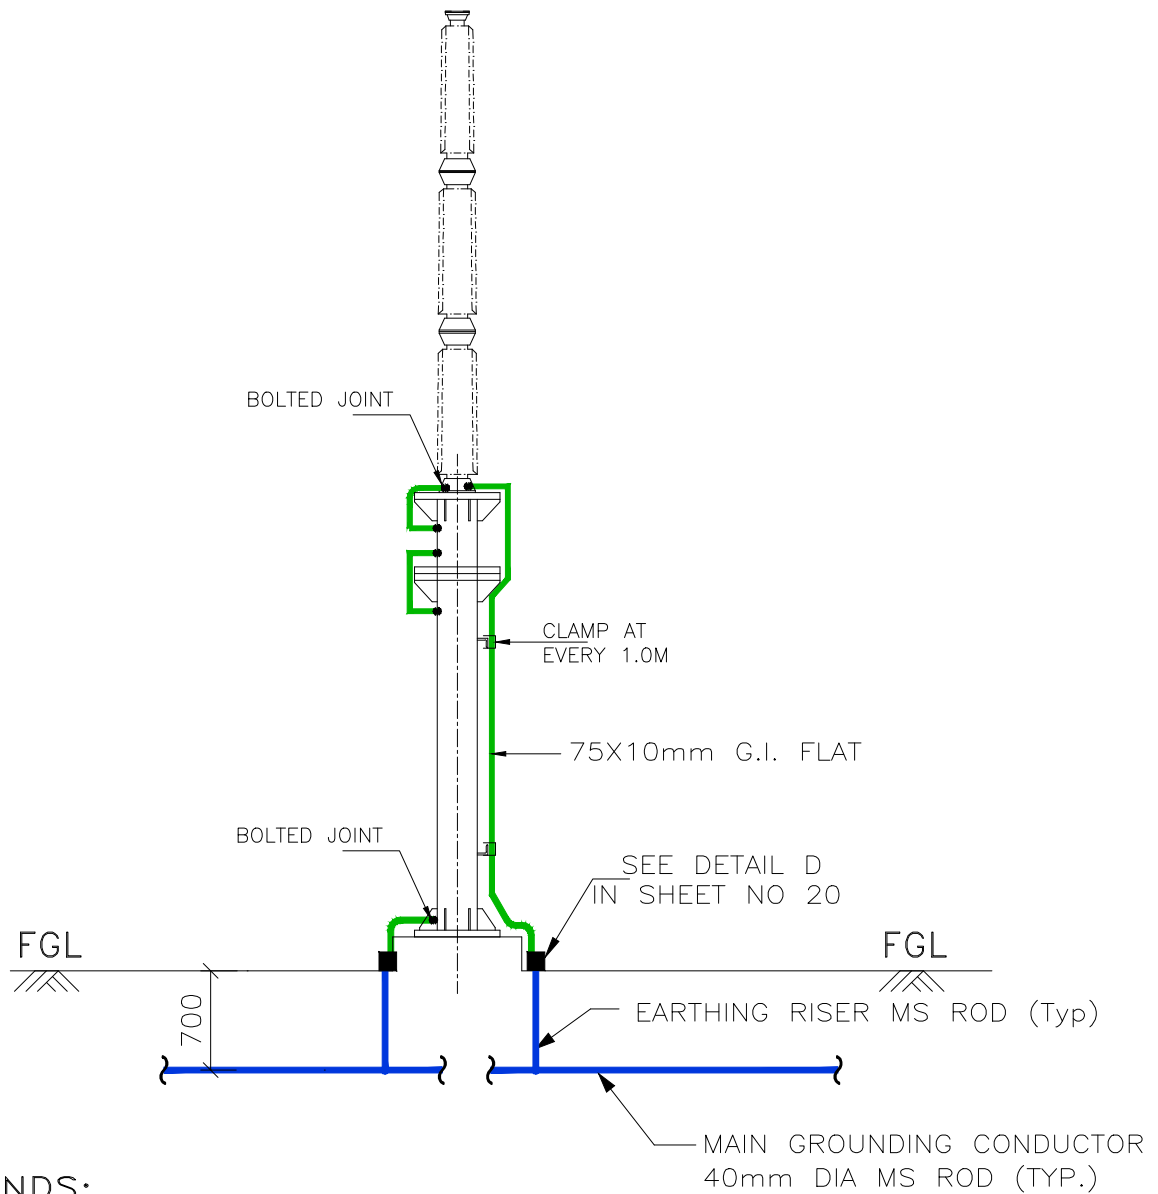

LEGENDS:

- 40mm ϕ MS ROD
- 75x10mm GI FLAT

NOTES:

1. NO. OF RISERS= 2NOS./PHASE




EQUIPMENT EARTHING DETAILS 400kV & 220kV POST INSULATOR

COMPUTERREF.NO.

DRG. No.

TB-4-369-316-009

SHEET No.
04

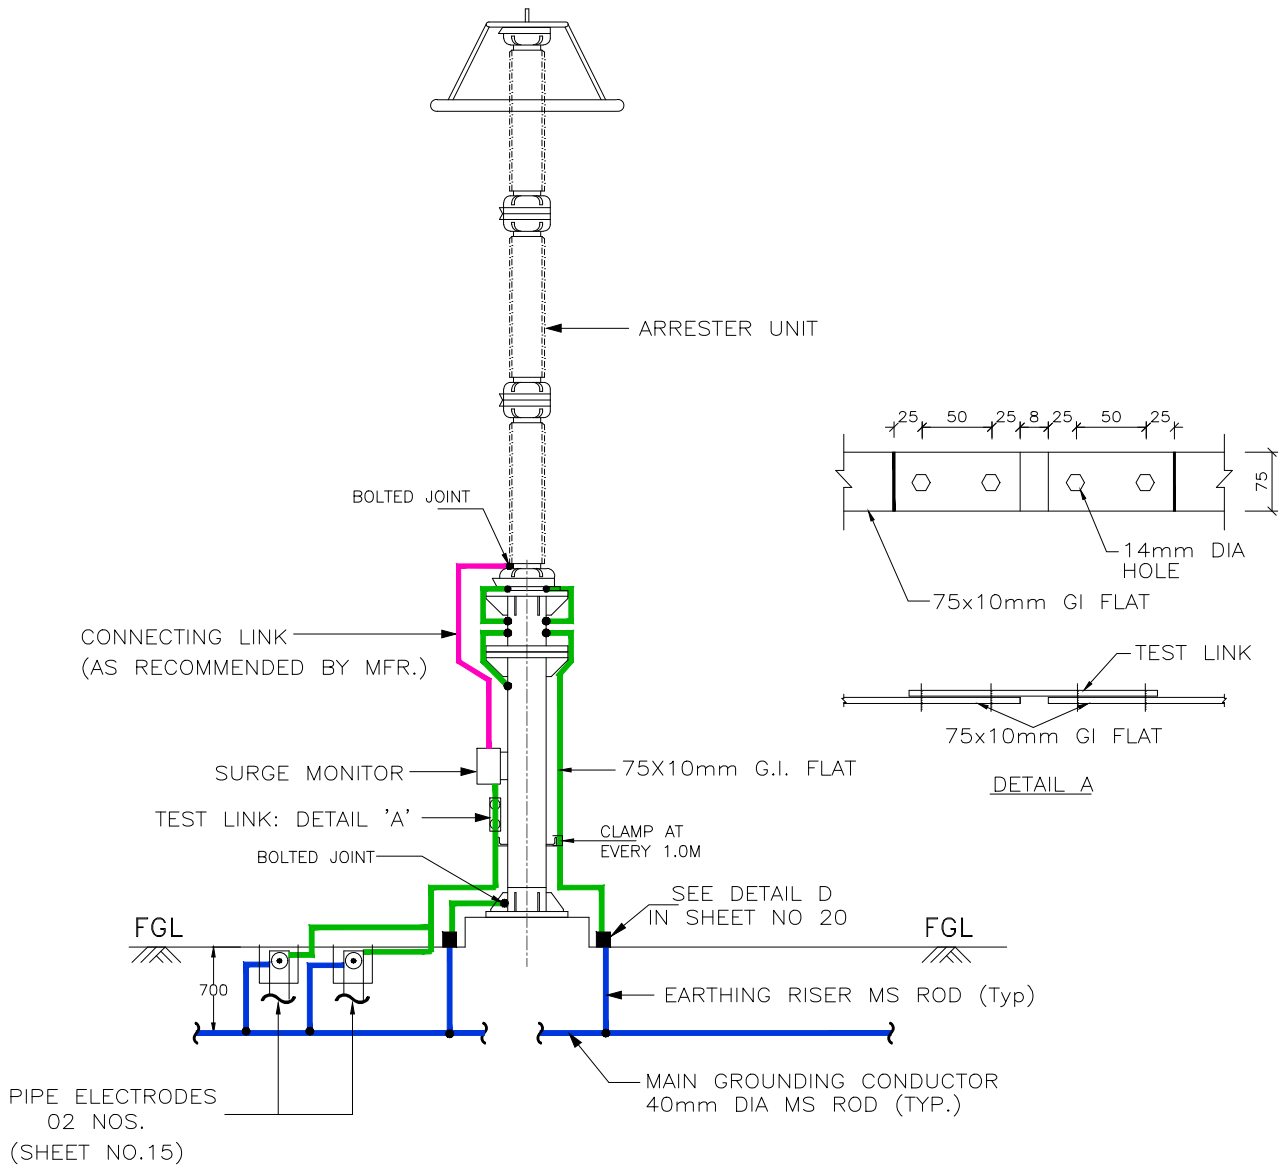

LEGENDS:

	40mm ϕ MS ROD
	75x10mm GI FLAT
	CONNECTING LINK AS PER OEM

NOTES:

1. NO. OF RISERS= 3NOS./PHASE
2. NO. OF PIPE ELECTRODE IN TREATED PIT WITH TEST LINK= 2NOS./ PHASE
3. CLEAT CLAMP SHALL BE PROVIDED AT 1m INTERVAL.
4. MINIMUM DISTANCE OF 5000MM SHALL BE MAINTAINED BETWEEN TWO TREATED (PIPE) ELECTRODES.
5. SURGE COUNTER EARTHING SHALL NOT PASS THROUGH ANY PIPE AND SHALL HAVE SHORTEST LENGTH.





EQUIPMENT EARTHING DETAILS 390kV & 216kV SURGE ARRESTER

COMPUTERREF.NO.

DRG. No.

TB-4-420-316-009

SHEET No.
05

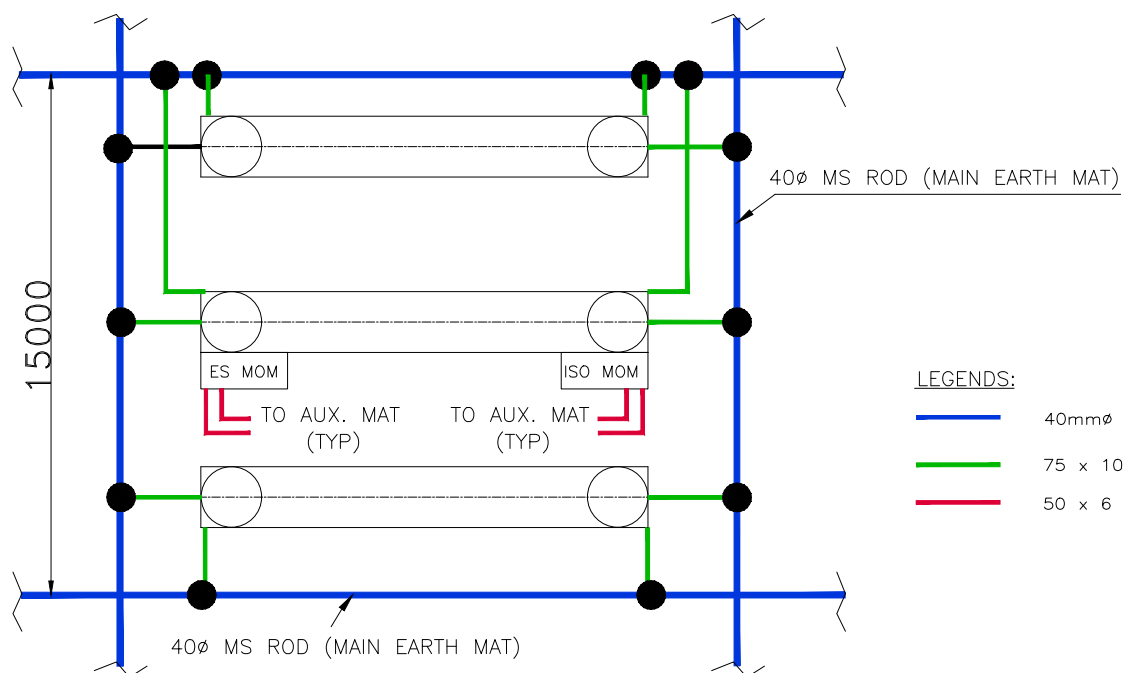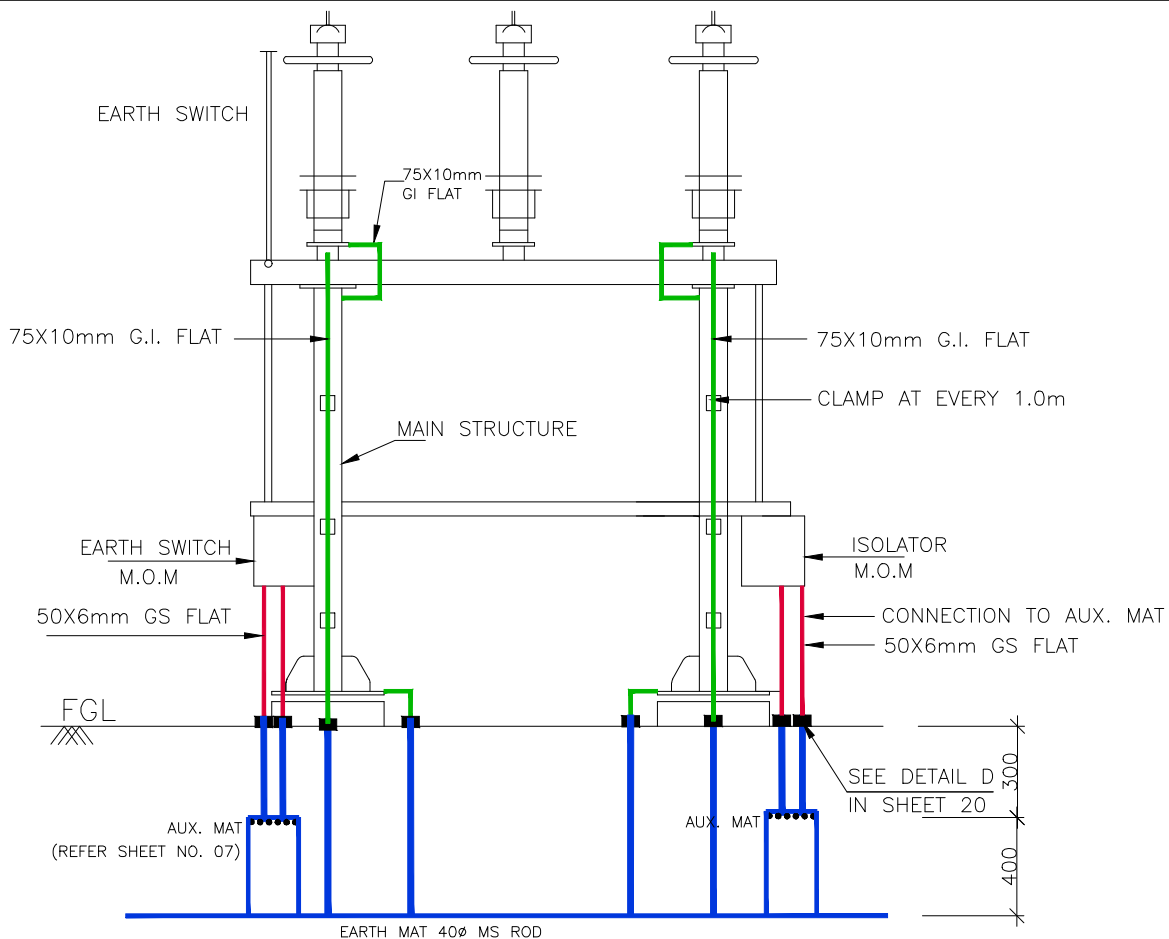

NOTES:

1. NO. OF RISER FOR EQUIPMENT = 4 Nos./PHASE (EXCLUDING RISERS FOR MOM BOXES)
2. NO. OF RISER FOR MECHANISM BOX = 2 Nos./BOX
3. NO. OF AUXILIARY MAT = 1 No./BOX



EQUIPMENT EARTHING DETAILS



400kV & 220kV DOUBLE BREAK
ISOLATOR (TYPICAL) WITH ONE EARTHSWITCH

COMPUTERREF.NO.

DRG. No.

TB-4-420-316-009

SHEET No.
06

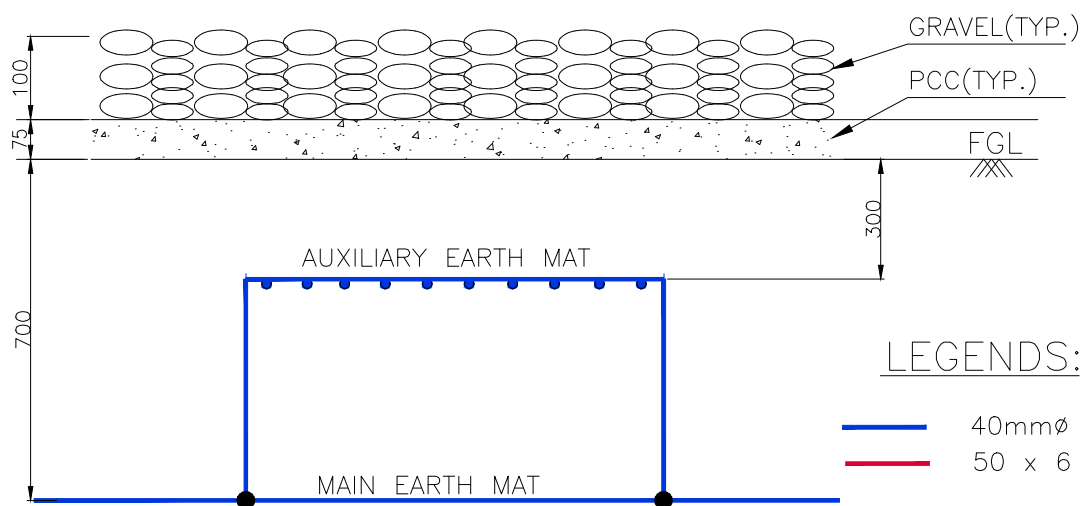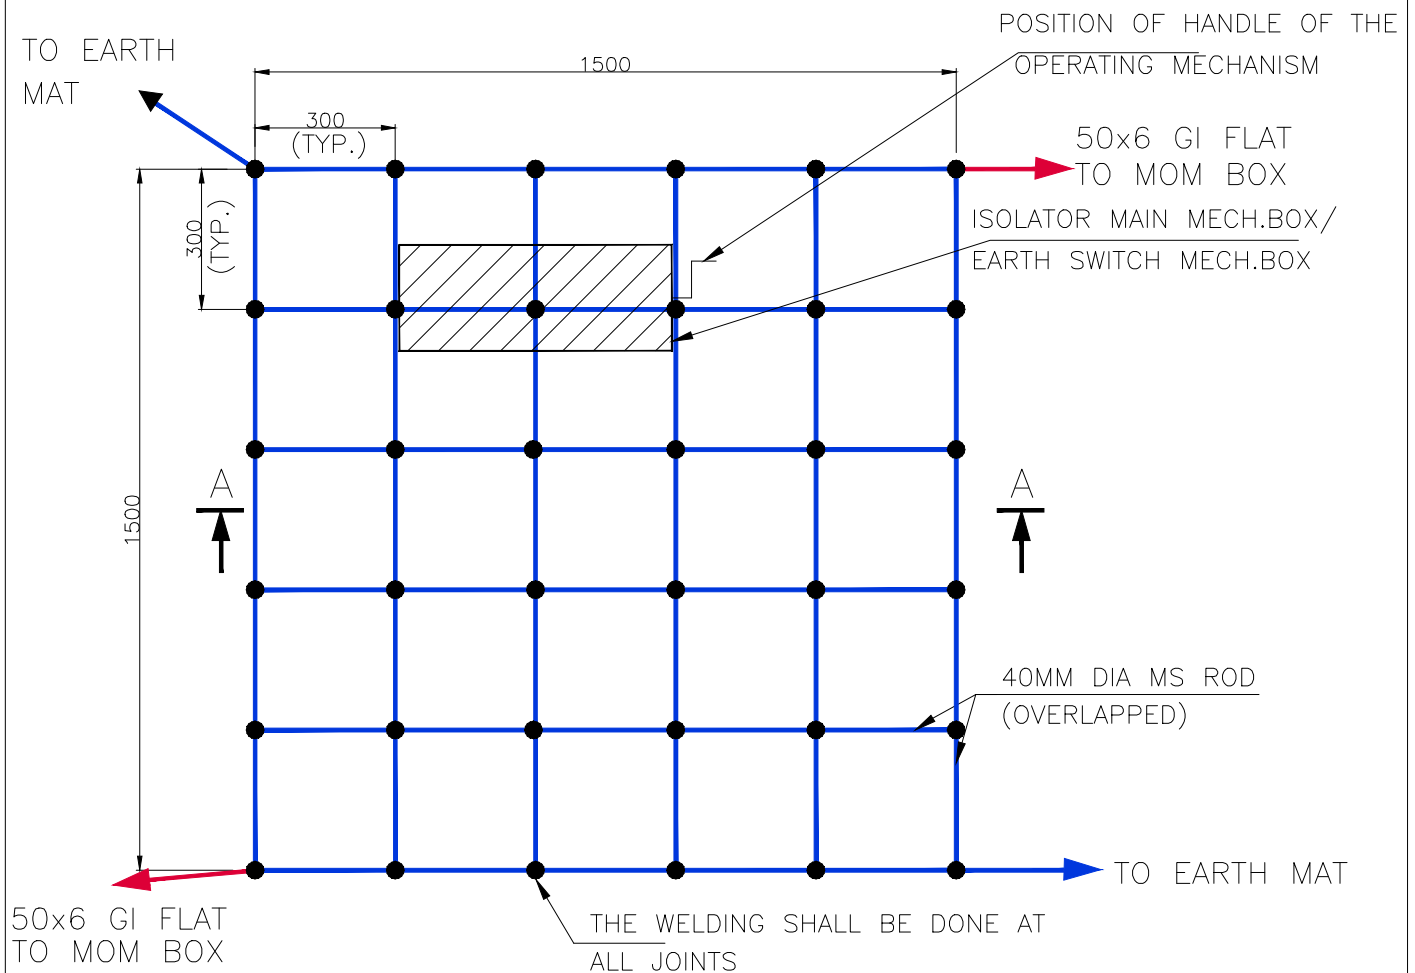

LEGENDS:

- 40mm ϕ MS ROD
- 50 x 6 mm GI FLAT

SECTION AA

NOTES:

- AUX. EARTH MAT SHALL BE SO POSITIONED THAT THE FOOT OF THE OPERATOR ALWAYS LIE OVER THE AUX. EARTH MAT AREA WHILE ATTENDING / OPERATING THE MECH. BOX THE CABLE TRENCH ROUTING SHALL BE PLANNED ACCORDINGLY.



EQUIPMENT EARTHING DETAILS


AUXILIARY EARTH MAT FOR ISOLATOR MAIN MECH.,E/S MECH. BOX

COMPUTER REF. NO.

DRG. No.

TB-4-420-316-009

SHEET No.
07

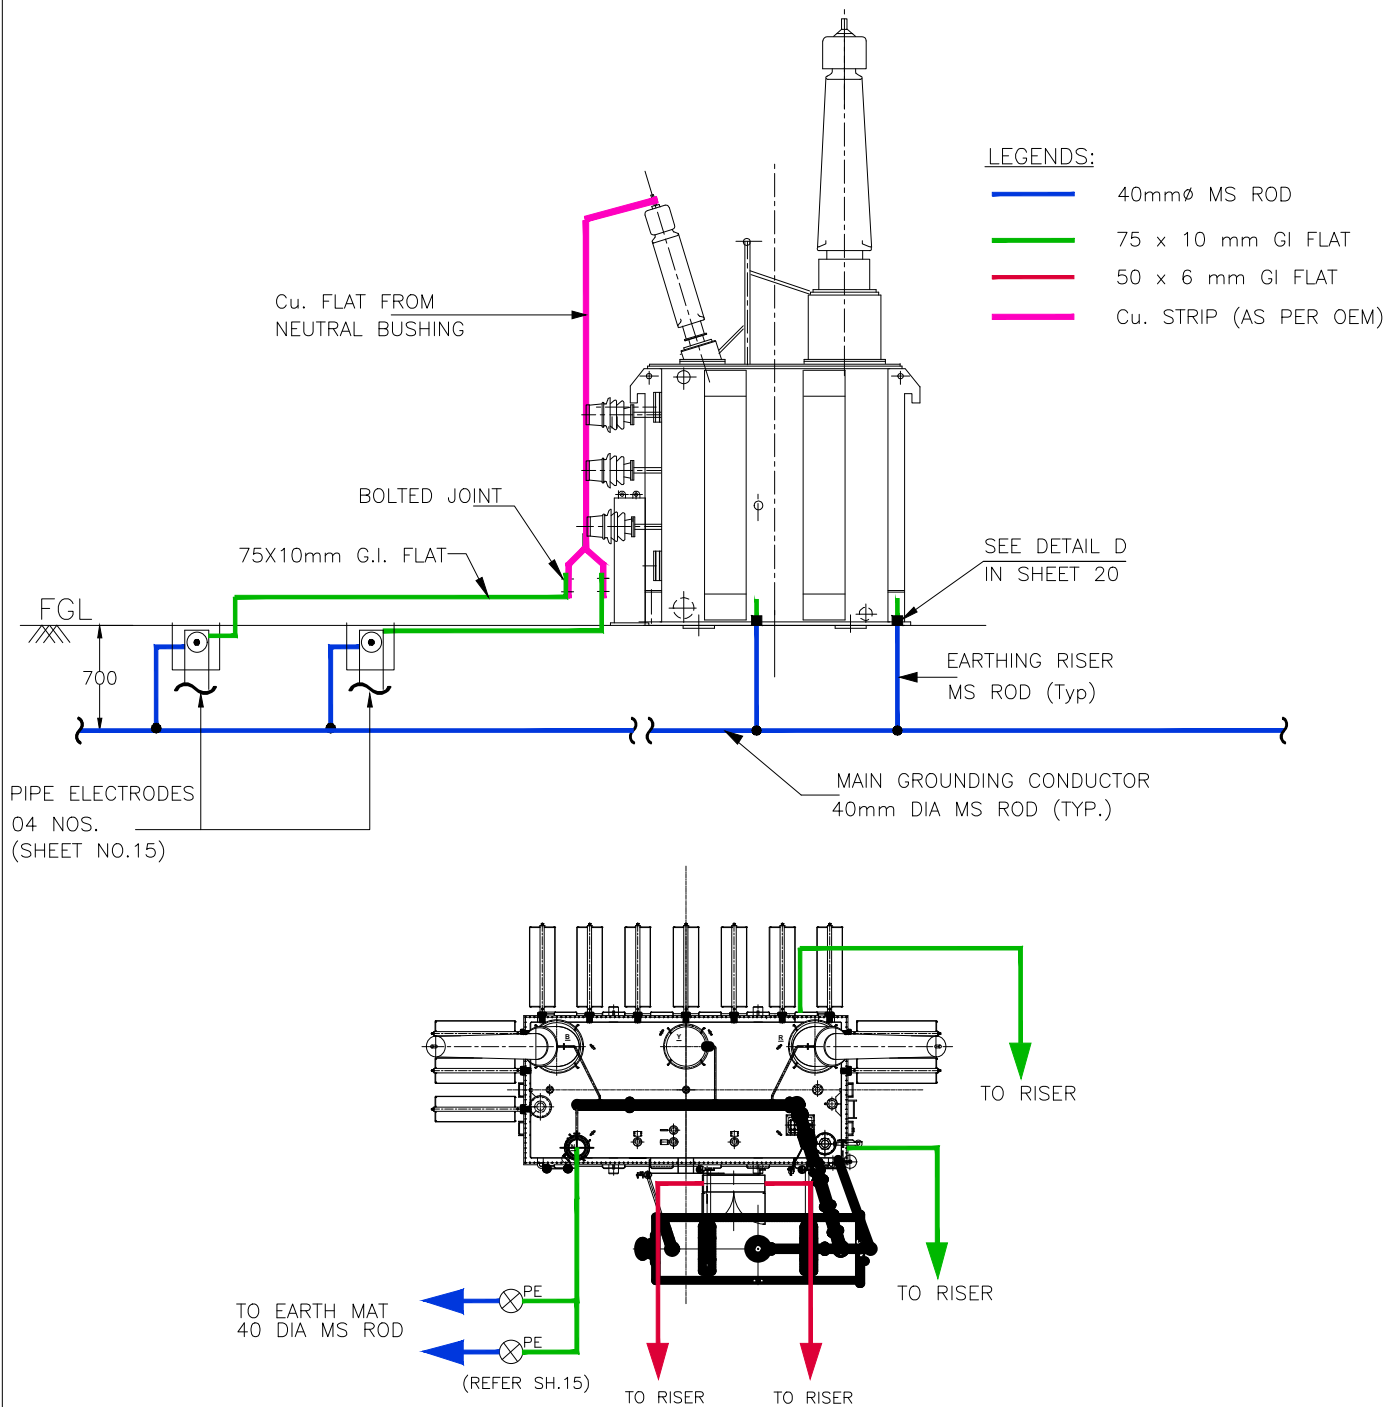

NOTES:

- MINIMUM DISTANCE OF 5000MM SHALL BE MAINTAINED BETWEEN TWO TREATED (PIPE) ELECTRODES.
 NO. OF PIPE EARTH ELECTRODE WITH TREATED PIT = 2NOS. (NEUTRAL)
 NO.OF RISERS = 06 NOS. FOR EARTHING OF FOLLOWING PARTS OF REACTOR
 (TWO EARTHING STRIPS CAN BE CONNECTED TO ONE RISER)
- | | |
|--------------------|---|
| MAIN TANK | - 2 Nos. (75X10 GI FLAT) |
| CONTROL CABINET/MB | - 2 Nos. (50x6 GS FLAT) |
| NEUTRAL EARTHING | - 2 Nos. (75X10 GI FLAT THROUGH PIPE ELECTRODE) |




EQUIPMENT EARTHING DETAILS REACTOR

COMPUTERREF.NO.

DRG. No.

TB-4-420-316-009

SHEET No.
09

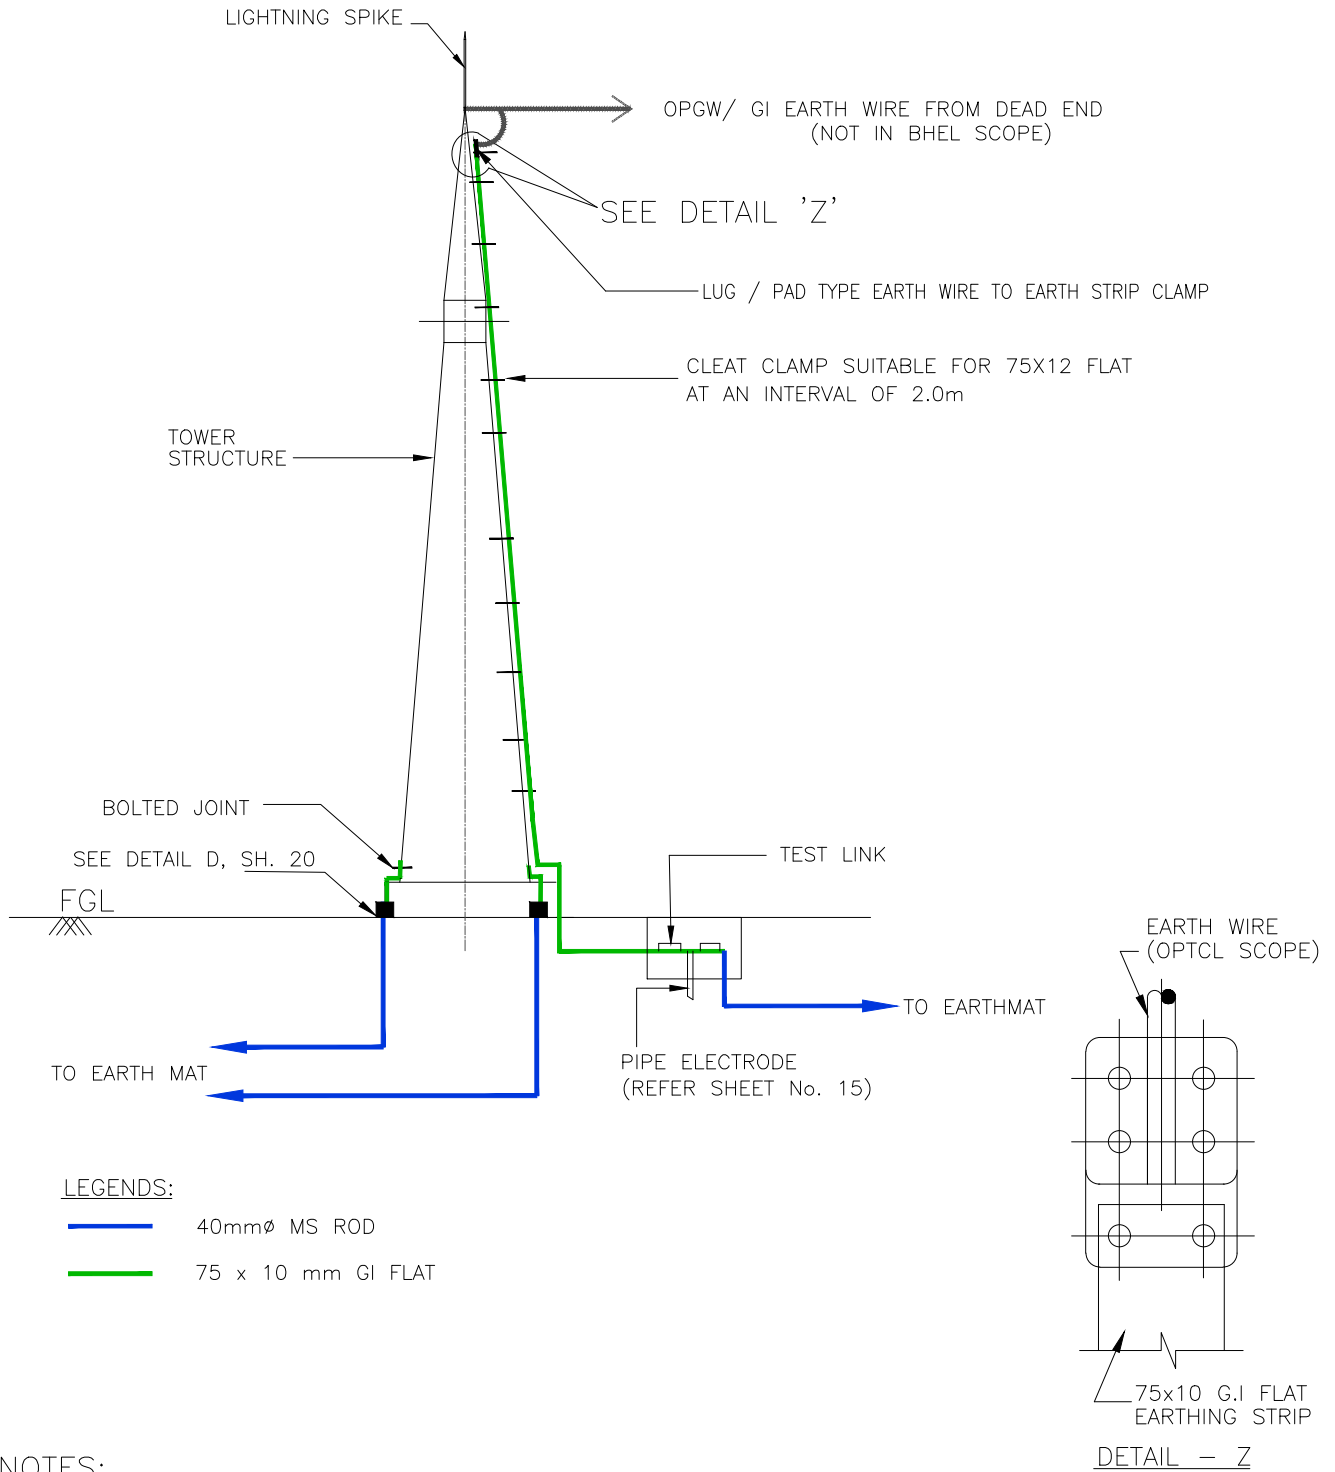

NOTES:

1. NO. OF PIPE ELECTRODE : 1 NO. PER TOWER WITH DOWN CONDUCTOR.
2. NO. OF RISERS = 2 NOS.



EQUIPMENT EARTHING DETAILS TOWER WITH PEAK

COMPUTERREF.NO.


DRG. No.

TB-4-420-316-009


SHEET No.
10

2 X M12/M16 Bolts (Bolt size to suit hole in the structure)


Structure

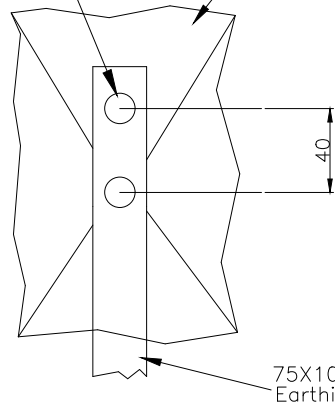

Detail - Z

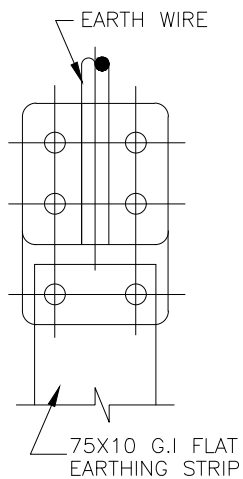

DETAIL - X

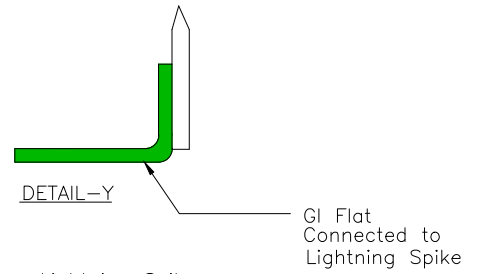

DETAIL-Y

GI Flat Connected to Lightning Spike

Lightning Spike

Lug for Earthwire

DETAIL-Y

2000 (TYP)

CLEAT CLAMP SUITABLE FOR 75X12 FLAT AT AN INTERVAL OF 2.0m

Lighting Mast Structure

See Detail - Z

BOLTED JOINT

A

SEE DETAIL D, SH. 20

A

FGL

TO EARTH MAT


PIPE ELECTRODE (REFER SHEET No. 15)

TO EARTH MAT

LEGENDS:

- 40mm ϕ MS ROD
- 75 x 10 mm GI FLAT

TO RISER

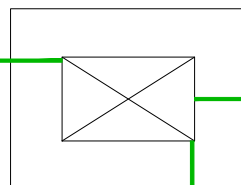

TO RISER

View A-A

PE
PIPE ELECTRODE

TO EARTH MAT

NOTES:

- NO. OF PIPE ELECTRODE : 1 NO.
- NO. OF RISERS = 2 NOS.



EQUIPMENT EARTHING DETAILS LIGHTENING MAST (LM)

COMPUTER REF. NO.




DRG. No.

TB-4-420-316-009

SHEET No.
11

FENCE GATE

FENCE GROUNDING

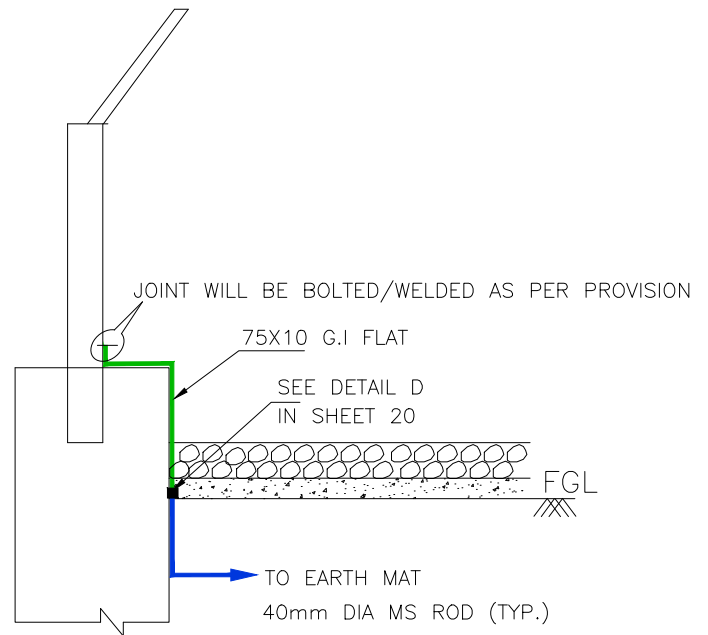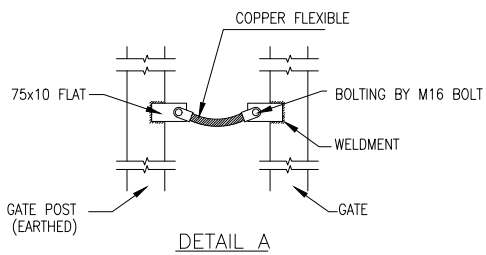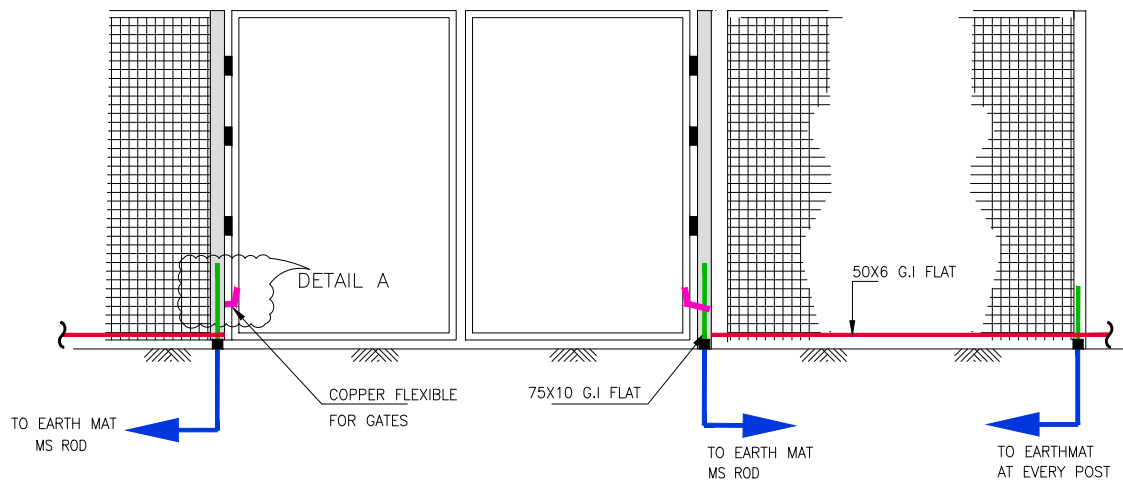

LEGENDS:

- 40mm $\varnothing$ MS ROD
- 75 x 10 mm GI FLAT
- 50 x 6 mm GI FLAT
- BRAIDED Cu. CONDUCTOR (FOR EARTHING OF GATES)

NOTES:

1. EVERY POST OF FENCE & GATES SHALL BE CONNECTED TO EARTHING GRID BY 75X10 MM GI FLAT.
2. A CONTINUOUS EARTH STRIP OF SIZE 50X6mm SHALL RUN ALL THROUGH THE FENCE.
3. EARTHING CONDUCTOR SHALL BE BURIED 2000mm OUTSIDE THE SWITCHYARD FENCE.





EQUIPMENT EARTHING DETAILS GATE/FENCE POST

COMPUTER REF. NO.

DRG. No.

TB-4-420-316-009

SHEET No.
12

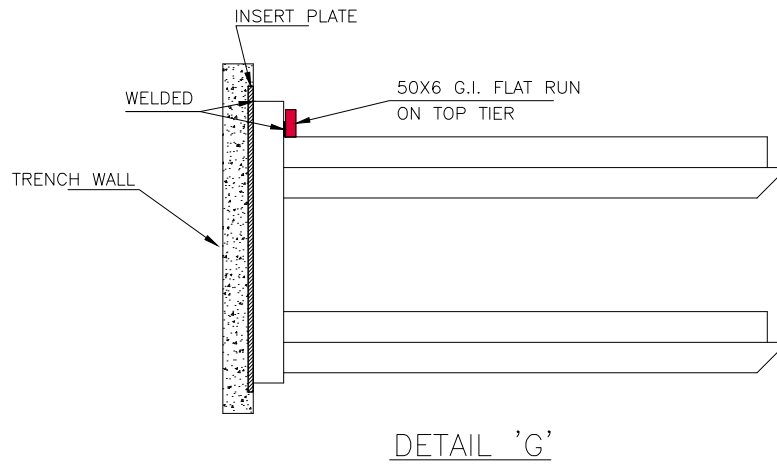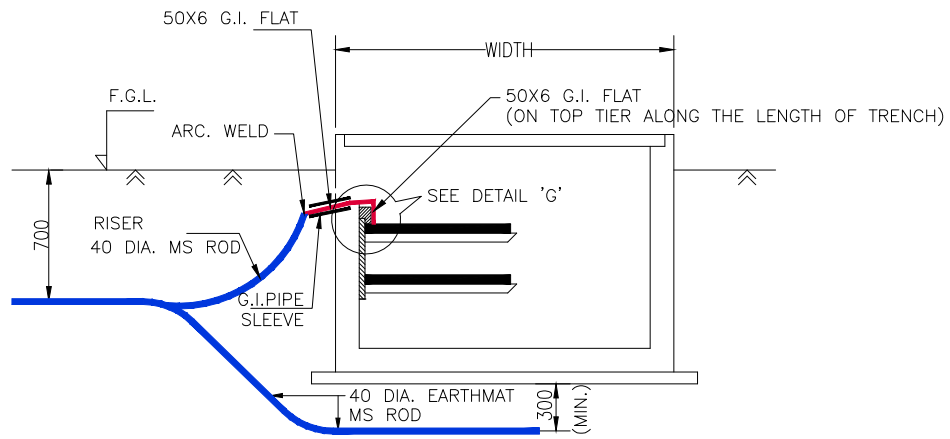

DETAIL FOR CONNECTING GI FLAT RUNNING
ON TOP TIER TRENCH TO EMBEDDED PLATE.

LEGENDS:

- 40mm $\varnothing$ MS ROD
- 50x6mm GI FLAT

NOTES:

1. RISERS SHALL BE PROVIDED AT AN INTERVAL OF 20M ALONG THE LENGTH OF TRENCH.
2. THE EARTH STRIP (50x6mm G.I. FLAT) SHALL BE WELDED/CLEATED TO TOP RACK ALONG THE TRENCH RUN AT EVERY 1.5M.
3. WHERE THE CABLE RACKS ARE PROVIDED ON BOTH SIDES OF THE TRENCH, BOTH SIDES SHALL BE EARTHED AS PER ABOVE.
4. CABLE & CABLE TRAY EARTHING SHALL BE DONE AS PER SPECIFICATION.




EQUIPMENT EARTHING DETAILS CABLE TRENCH

COMPUTER REF. NO.

DRG. No.

TB-4-420-316-009

SHEET No.
13

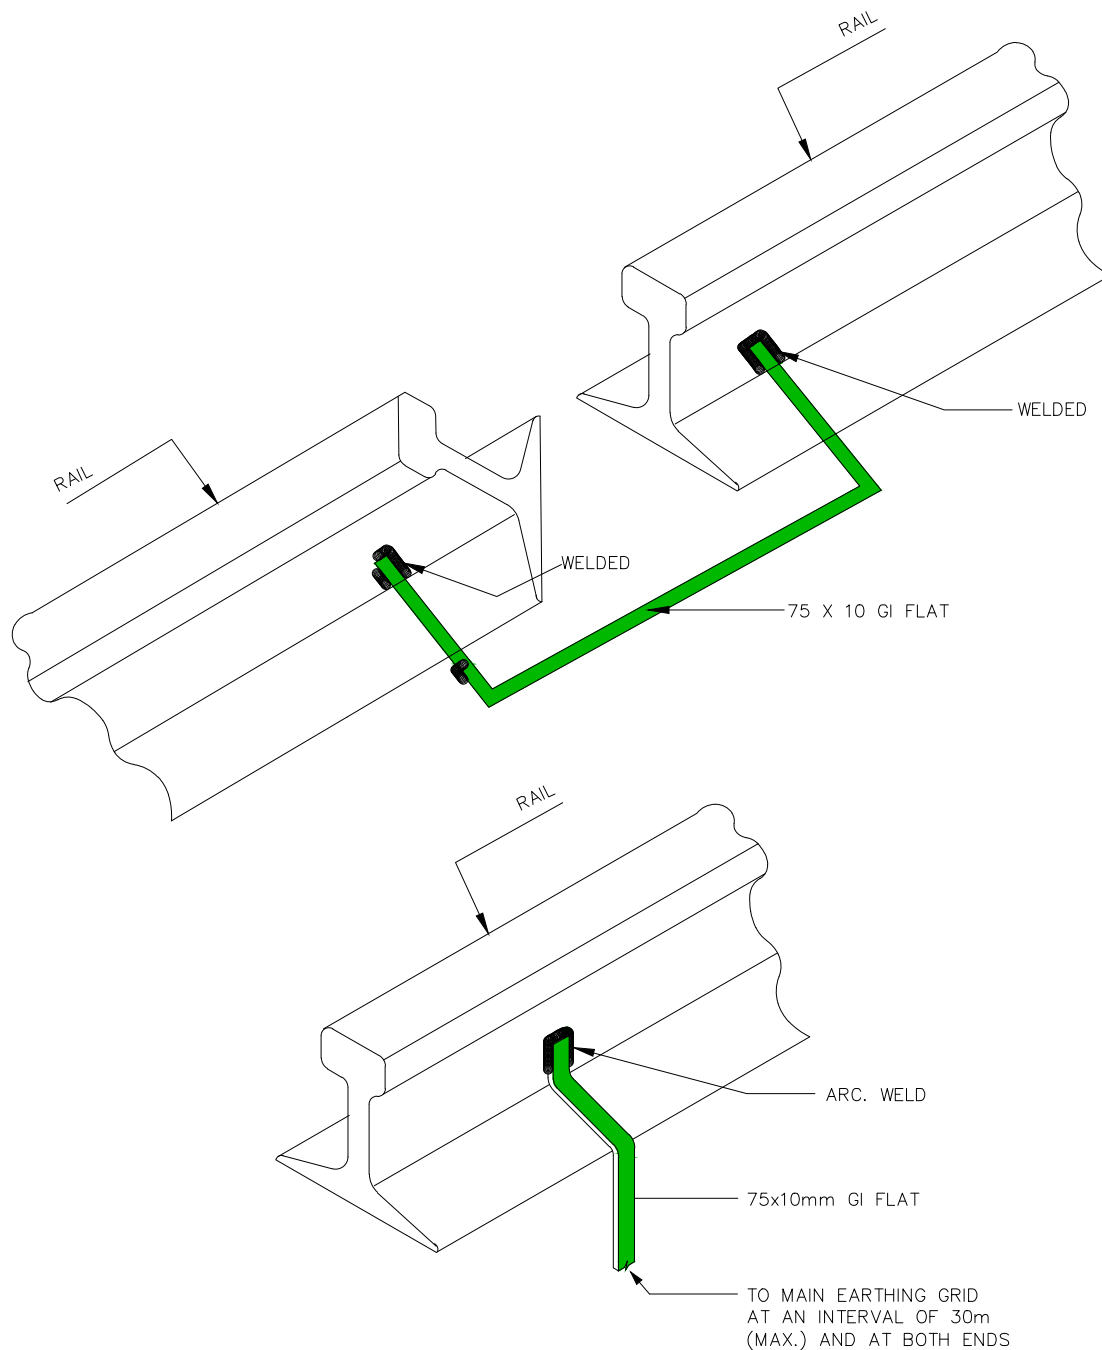

LEGENDS:

——— 75x10mm GI FLAT

NOTES:

1. RAILWAY TRACKS WITHIN SWITCHYARD AREA SHALL BE EARTHED AT A SPACING OF NOT MORE THAN 30m AND ALSO AT BOTH ENDS.




EQUIPMENT EARTHING DETAILS RAIL BONDING

COMPUTERREF.NO.

DRG. No.

TB-4-420-316-009

SHEET No.
14

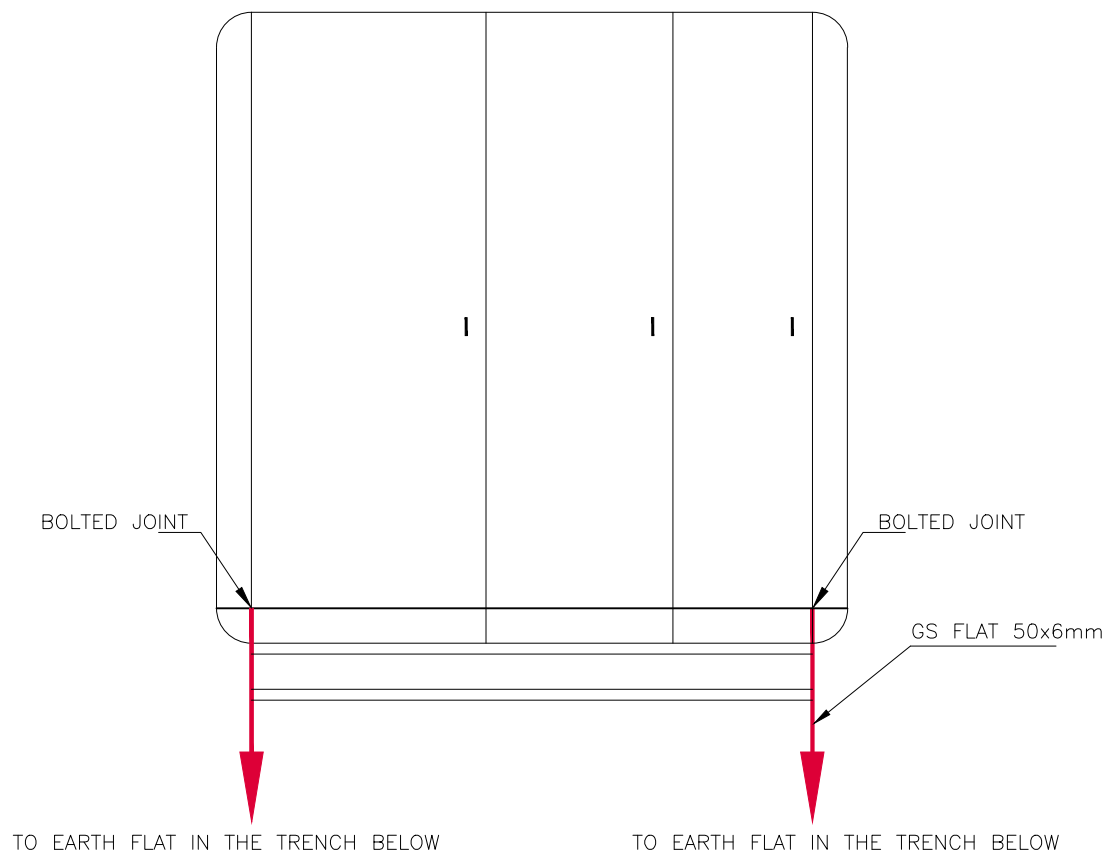

LEGENDS:

— 50x6mm GI FLAT

NOTES:

1. ALL PANELS/ BOARDS/ KIOSKS/ MBs SHALL BE EARTHED AT TWO LOCATIONS USING 50x6mm GI FLAT, WHICH IN TURN SHALL BE CONNECTED TO MAIN EARTH MAT THROUGH EARTH CONDUCTORS IN TRENCHES OR THROUGH RISERS.



EQUIPMENT EARTHING DETAILS



CONTROL AND RELAY PANELS/BATTERY CHARGER/AC DC BOARDS/MLDB

COMPUTERREF.NO.

DRG. No.

TB-4-420-316-009

SHEET No.
17

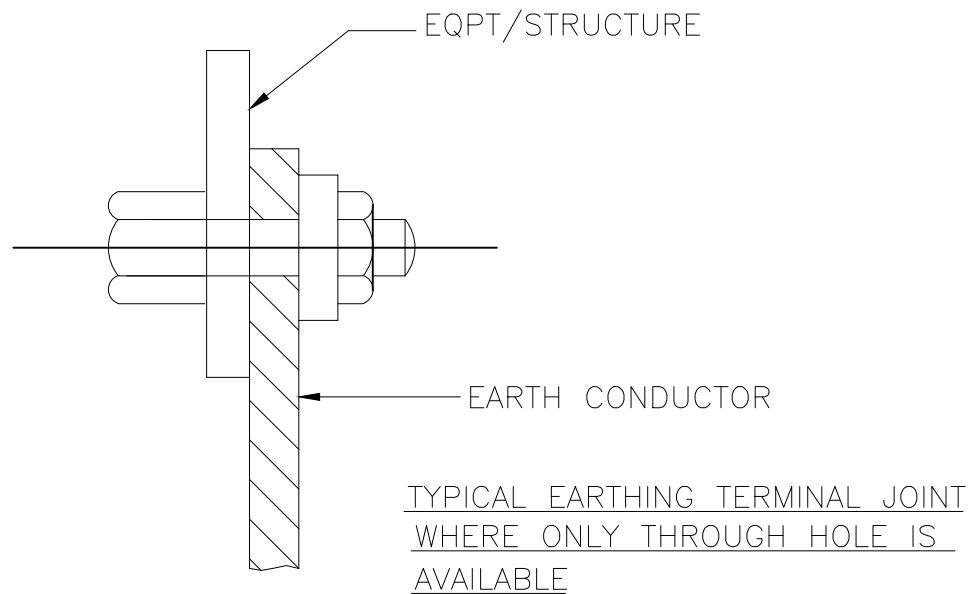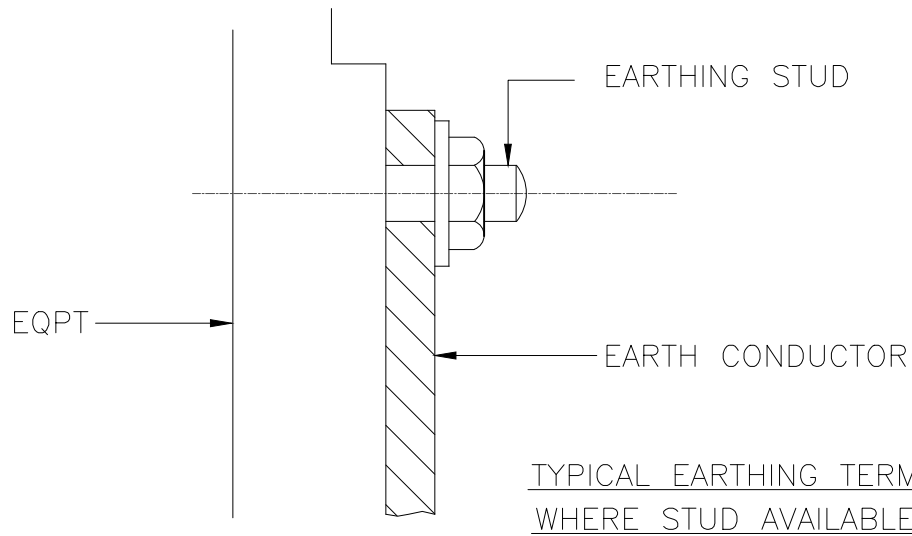

NOTE

1. THIS IS GENERAL TYPICAL BOLTING ARRANGEMENT APPLICABLE TO ALL PANELS, EQUIPMENT ETC. WHERE BOLTING ARRANGEMENT IS PROVIDED.
2. IN CASE EARTHING TERMINAL COMPRISES ONLY A TAPPED HOLE SUITABLE BOLT/ SCREW WITH WASHER MAY BE USED FOR EARTHING CONDUCTOR TERMINATION



EQUIPMENT EARTHING DETAILS

TYPICAL ARRANGEMENT OF BOLTED JOINTS

COMPUTERREF.NO.


DRG. No.

TB-4-420-316-009


SHEET No.
18

STRIP TO STRIP (75x10/50X6 GI FLAT)

1. STRAIGHT LAP JOINT/RISER

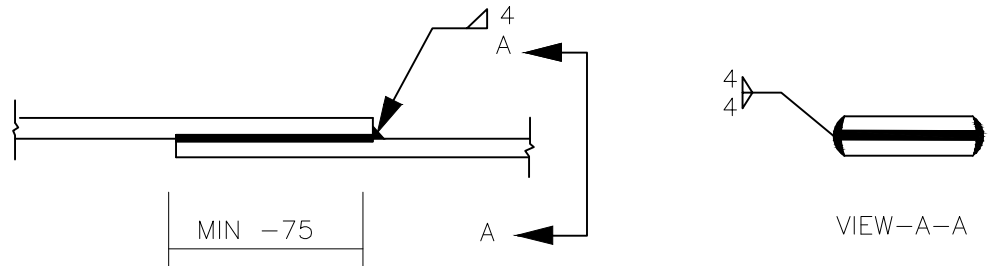

2. CROSS LAP JOINT

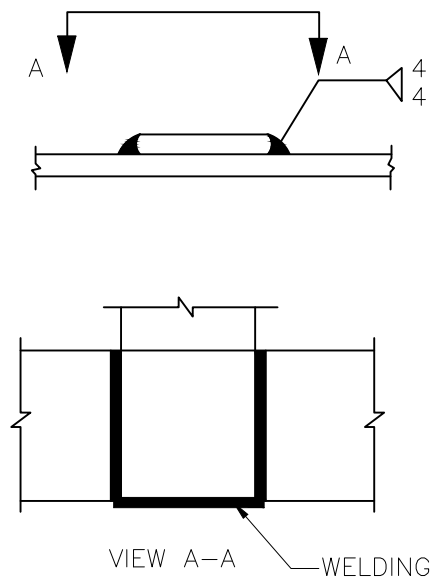

EQUIPMENT EARTHING DETAILS


WELDING DETAILS

COMPUTERREF.NO.


DRG. No.

TB-4-420-316-009


SHEET No.
19

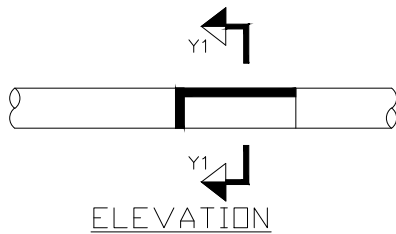


ELEVATION
(CONDUCTOR IN HORIZONTAL PLANE)

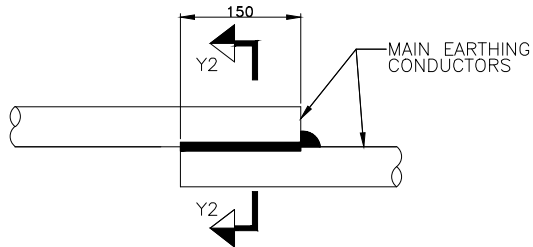


ELEVATION
(CONDUCTOR IN VERTICAL PLANE)

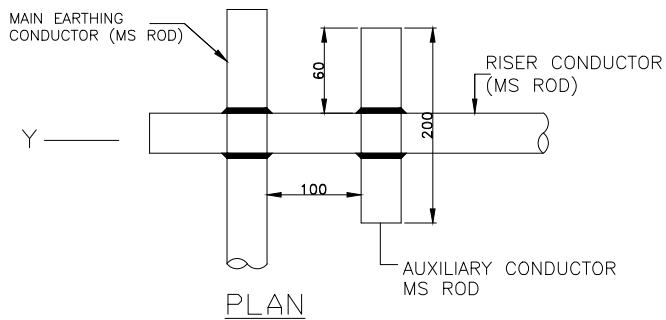

PLAN

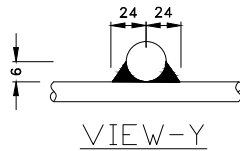


VIEW-Y

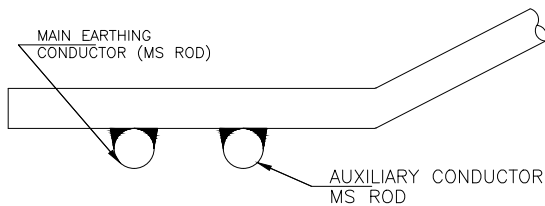



ELEVATION
DETAIL-C

TYPICAL OVERLAPPING JOINT OF TWO CONDUCTORS

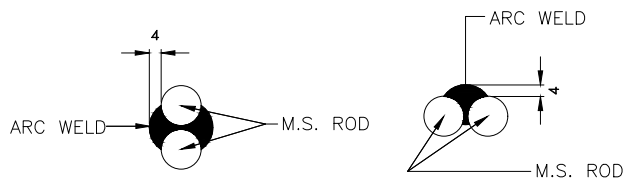


SECTION Y2-Y2


SECTION Y1-Y1

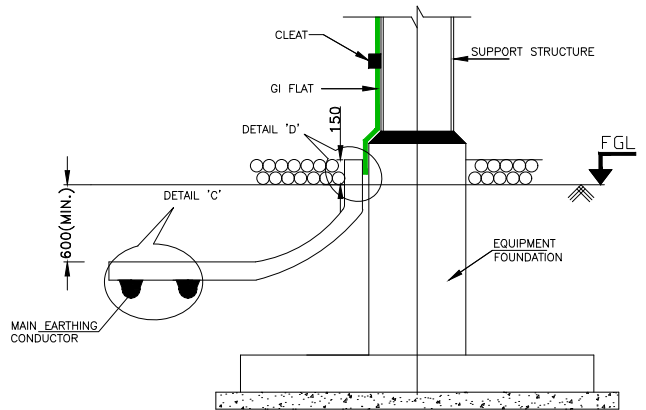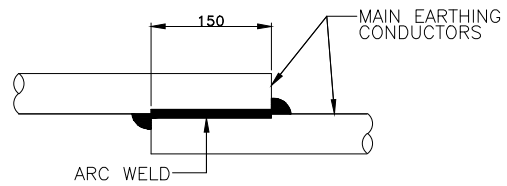

TYPICAL DETAILS OF RISER

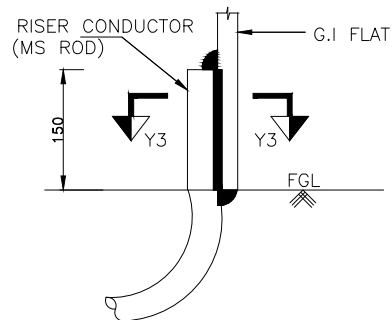

ELEVATION
DETAIL-D

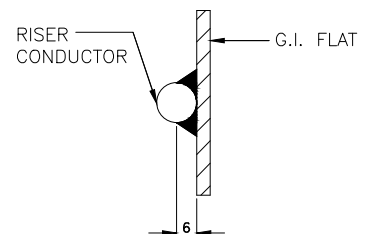

SECTION Y3-Y3



EQUIPMENT EARTHING DETAILS


WELDING DETAILS

COMPUTER REF. NO.

DRG. No.

TB-4-420-316-009

SHEET No.
20

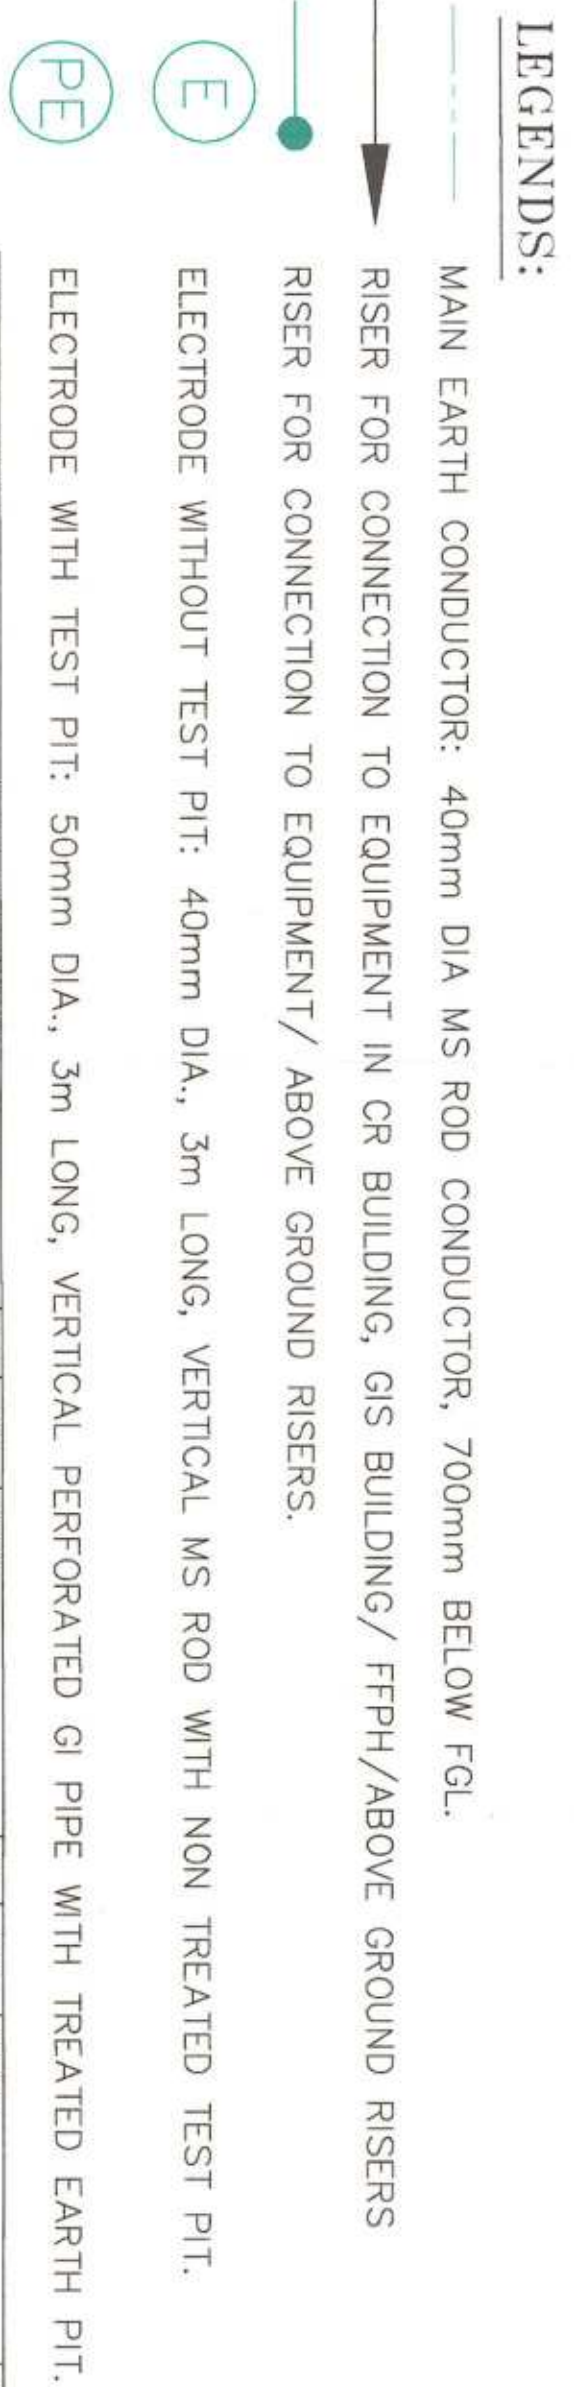

Problems in text: (PE) may be provided @ session - extra

Finishing: Corrosion: PE may be provided (Cath. corr. prev. PE)

For NUTS & Washers - Body 3005, Nut - 4001, Ep for both washers & bolts

Nuts: - Epoxy coating provided for 415 washers to be shown

As per IEEE spec guide 602

Rephrased: The main need (Corrosion NUTS) shall be done with epoxy for the coating

(PE) 415 washers & bolts shall be provided (Cath. corr. prev. PE)

1. THE EARTHING SYSTEM DOWN IS SCHEMATIC. EXACT LOCATION OF EARTH CONDUCTOR, RISER PIGTAILS, ROD ELECTRODES, PIPE ELECTRODES WITH TEST PIT SHALL BE DETERMINED AT SITE AS PER SITE CONDITIONS.
2. ALL EQUIPMENT AND STRUCTURES SHALL, IN GENERAL, BE GROUNDED AT TWO POINTS AT OPPOSITE CORNERS WHENEVER SHOWN IN DRAWING OR NOT AND THESE SHALL BE CONNECTED TO DIFFERENT PARTS OF THE MATS WHEREVER POSSIBLE IN ADDITION ALL EARTHING AS PER TYPICAL EARTHING DETAIL IN DRG. NO. TB-4-420-316-009 TO BE FOLLOWED.
3. SPACING OF BURRED CONDUCTOR SHALL BE 5M IN BOTH DIRECTIONS AS FAR AS POSSIBLE EXCEPT WHERE ADDITIONAL CONDUCTORS ARE SHOWN FOR GROUNDING OF MAJOR STRUCTURAL COLUMNS/BUILDINGS/EQUIPMENT.
4. THE GROUNDING MAT (60mm DIA. MS ROD) SHALL BE BURIED AT 700mm BELOW FFL.
5. CONNECTION WITH EQUIPMENT EARTHING PAD SHALL BE BOLTED TYPE; CONNECTION BETWEEN EQUIPMENT GROUNDING LEADS AND MAIN GROUND CONDUCTORS SHALL BE WELDED TYPE. FOR RUST PROTECTION THE WELDS SHALL BE CLEANED WITH MILD BRUSH, TREATED WITH RED PRIMER AND AFTERWARDS THICKLY COATED WITH BITUMEN.
6. ALL GROUND CONNECTIONS SHALL BE MADE BY ELECTRIC ARC WELDING. ALL WELDED JOINTS SHALL BE ALLOWED TO COOL DOWN GRADUALLY TO ATMOSPHERIC TEMPERATURE BEFORE PUTTING ANY LOAD ON THEM. ARTIFICIAL COOLING SHALL NOT BE ALLOWED.
7. ALL ARC WELDING OF LARGE DIAMETER CONDUCTORS SHALL BE DONE BY MANUAL LOW HYDROGEN CONTENT ELECTRODES.
8. IN CASE HIGH TEMPERATURE IS ENCOUNTERED AT SOME LOCATION THE EARTHING CONDUCTOR SHALL BE Laid MINIMUM 1500mm AWAY FROM SUCH LOCATIONS.
9. EARTHING OF GAS INSULATED BUS DUCT SUPPORT STRUCTURE SHALL BE SHOWN SEPARATELY ALONG WITH GAS.
10. ALL STEEL COLUMNS & RCC COLUMNS WHETHER SPECIFICALLY SHOWN OR NOT, SHALL BE CONNECTED TO EARTHING SYSTEM.
11. WHEREVER EARTHING CONDUCTOR GROSSES UNDER GROUND SERVICE DUCTS, PIPES, TRANCHES, RAILWAY TRACKS ETC., IT SHALL BE Laid MINIMUM 300MM BELOW OR AT A SUITABLE DEPTH TO CLEAR THEIR CIVIL WORKS. THE EARTHING CONDUCTOR SHALL BE RE-ROUTED IN CASE IT FOLLS WITH EQUIPMENT FOUNDATIONS ALREADY ERRECTED.
12. GROUNDING CONDUCTOR AROUND THE BUILDING SHALL BE BURIED IN EXERTY AT A MINIMUM DISTANCE OF 2m FROM THE OUTER WALL / FOUNDATION / BOUNDARY OF THE BUILDING.
13. EACH EARTHING LEAD FROM THE NEUTRAL OF H.V./L.T. POWER TRANSFORMER/RECTOR & EACH SURGE ARRESTER SHALL BE DIRECTLY CONNECTED TO TWO INDEPENDENT PIPES/WELDED ELECTRODES WITH TEST PITS WHICH IN TURN SHALL BE CONNECTED TO STATION EARTH GRID. MINIMUM 5000mm SPACING BETWEEN PIPE ELECTRODES SHALL BE PROVIDED.
14. EARTHING TERMINAL OF LIGHTNING DOWN CONDUCTOR [FROM TOWER WITH PEAK, LM, BUILDINGS] CORNERS OF FENCE SHALL BE DIRECTLY CONNECTED TO ROD ELECTRODE WHICH IN TURN SHALL BE CONNECTED TO STATION EARTHING GRID.
15. LOCATION OF PIPE ELECTRODES, PE & ROD ELECTRODES, E ARE SHOWN TEXTUALLY.
4.6. EARTH MAT SHOULD BE Laid 2m BEYOND FENCE ON ALL SIDES. In x & y direction it shall be 4.6m wide. It shall be covered by 150mm layer of FILL SHALL BE USED FOR EARTHING OF CABLE TRANCHES. ALL TRANCHES SHALL BE EARTHED THROUGH RISERS AT AND INTERVAL OF 20m ALONG THE LENGTH OF THE TRENCH & AT ALL ENDS OF THE TRENCHES.
16. GROUNDING CONDUCTORS EMBEDDED IN CONCRETE SHALL HAVE APPROXIMATELY 50MM CONCRETE COVER. If grounding conductor is required to be EMBEDDED IN MAJOR FOUNDATIONS, THEN IT SHALL BE Laid IN A SLEEVE.
17. RAILWAY TRACKS WITH SWITCHBOARD AREA SHALL BE BONDED ACROSS IRON PLATES AND CONNECTED TO EARTHING GRID AT SEVERAL LOCATIONS.
20. RISERS FOR KIOSK, JB, CT/REACTOR/ISOLATOR MBs AND 33KV EQUIPMENT ARE NOT SHOWN FOR THE SAKE OF CLARITY. FOR TYPICAL DETAILS PLEASE REFER SEPARATE EQUIPMENT EARTHING DRG. NO. TB-4-420-316-009.
21. CONDUCTORS SHALL BE Laid AFTER COMPLETION OF ADJACENT COLUMN/ EQUIPMENT FOUNDATIONS. Laying of GROUND CONDUCTORS SHALL BE SEQUENTIALLY COORDINATED WITH THE ERECTION OF ALL UNDERGROUND FACILITIES (CABLE TRENCH, SLUMP PITS, DRAINS ETC).
22. GROUNDING CONDUCTORS ALONG THEIR RUN ON CABLE TRENCH, LODDER, COLUMNS, BEAMS, WALLS, ETC. SHALL BE SUPPORTED BY SUITABLE WELDING/CLEANING AT AN INTERVALS OF 1.5m. GROUNDING CONDUCTOR ALONG CABLE TRENCHES SHALL BE ON THE WALL NEAR TO THE EQUIPMENT. WHEREVER A GROUNDING CONDUCTOR PASSES THROUGH WALL, FLOORS ETC GALVANIZED IRON SLEEVE SHALL BE PROVIDED FOR THE PASSAGE OF THE CONDUCTOR. BOTH END OF THE SLEEVE SHALL BE SEALED TO PREVENT THE PASSAGE OF WATER THROUGH THE SLEEVE.
23. ALL STEEL COLUMNS, METALLIC STAIRS ETC. SHALL BE CONNECTED TO THE NEAREST GROUNDING CONDUCTOR BY GROUNDING LEADS. ELECTRICAL CONTINUITY SHALL BE ENSURED BY BONDING THE DIFFERENT SECTIONS OF HAND RAILS AND METALLIC STAIRS.
24. METALLIC PIPES, CONDENSATS AND CABLE TRAY SECTION FOR CABLE INSTALLATION SHALL BE BONDED TO DISBURSE ELECTRICAL CONNECTION TO GROUNDING CONDUCTOR AT NON MORE THAN 20m INTERVAL APART FROM INTERMEDIATE CONNECTION. BOTH ENDS SHALL ALSO BE CONNECTED TO THE GROUNDING SYSTEM.
25. WHEREVER GROUNDING CONDUCTOR GROSSES OR RUNS ALONG METALLIC STRUCTURES SUCH AS GAS/METERY/STEAM CONDUNIT/PIPES ETC. AND STEEL REINFORCEMENT OF CONCRETE, IT SHALL BE BONDED TO THE SAME.
26. FOR EQUIPMENT, FENCE GATE, AUXILIARY EARTH MAT, ELECTRODES ETC. DETAILS REFER EQUIPMENT EARTHING DETAILS DRAWING NO. TB-4-420-316-009.
27. EVERY POST OF FENCE AND GATE SHALL BE CONNECTED TO EARTH GRID BY ONE LEAD OF Size 10x10mm and a Conductor of Length 300mm shall be kept at Site.
28. THE EARTHING LAOUT SHOWN IN DRAWING IS FOR BASIC UNDERSTANDING PURPOSE ONLY. THE GROUNDING SPACING CAN BE CHANGED SLIGHTLY TO SUIT THE SITE CONDITIONS.
29. THIS DRAWING IS TO BE READ FOR EARTHING/ GROUNDING FOR OUTDOOR SUB-STATION AREA ONLY.

S.NO.	EQUIPMENT / FACILITY	NO. OF RISERS PER ECP
1	400/220KV ICT	08
2	400KV REACTOR	08
3	33/0.433KV STATION TRANSFORMER	04
4	SURGE ARRESTER	03
5	POST INSULATOR	02


7	OUTDOOR KIOSK / 1B / PANEL		02
8	CONTROL ROOM BUILDING		04
9	FPPH / DG BUILDING		05
10	400KV GIS BUILDING		
11	220KV GIS BUILDING		AS PER THE
12	SWG TO AIR BUSHING		EARTHING
13	GIS SUPPORT STRUCTURE		PHILOSOPHY
14	GIS BUILDING STEEL COLUMN		OF GIS LTM *

EARTHING PHILOSOPHY.

all the earthy dense will be consider for ϵ_p ϵ_{min} ϵ_{max}

	SIGNATURE	NAME	SON.	DATE
	AK	AK	AK	12.06.2018
	AK	AK	AK	13.06.2018
	DVS	-SIGNED-		13.06.2018


TRUE NORTH
PLANT NORTH

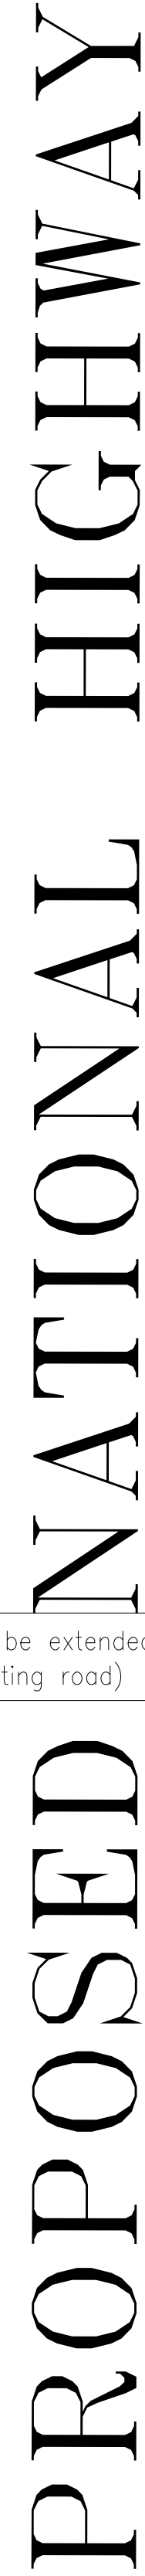

1. ALL DIMENSIONS ARE IN mm.
2. THE LOCATION OF CABLE TRENCHES MARKED IN THIS DWG. MAY BE SLIGHTLY MODIFIED TO SUIT SITE CONDITIONS.
3. OPENINGS FOR TAKING OUT PIPES/Pipes TO EQUIPMENTS SHALL BE PROVIDED IN CABLE TRENCHES, DRENING OF SITE SUITABLE TO DA.
4. 50/70 PIPE SHALL BE PROVIDED BELOW TOP CABLE SURFACE.
5. LOCATIONS OF OUTDOOR WORKS, CONSOLE BOXES TO BE SUITABLY DECIDED AT SITE.
6. CABLE ENTRY/EXIT FROM TRENCH IS INDICATED AS
 - FULL BOXES (600x600x400) SHALL BE USED AT THE END TURNING AND Ø150mm PIPE LENGTH EXCEEDS 15M.
7. CABLE SUPPORT FOR OUTDOOR TRENCHES SHALL BE PROVIDED AT EVERY 1m INTERVAL. SUPPORT CHANNEL SHALL BE FIXED TO WELDED ON IRSECTES IN TRENCH WALL USING 10mm Ø PLAT CHANG.
8. 11KV CONTROL CABLES SHALL BE PLACED IN MULTILAYER ON TRAYS SUPPORTED BY G1 CABLE RACK SUPPORT (ANGLE).
9. AUXILIARY POWER CABLES SHALL BE LAID IN TOP TIER AND CONTROL CABLES IN BOTTOM TIER.
10. FIBER OPTIC CABLE (IF PROVIDED) SHALL BE LAID IN HOPE PIPE AND SAME SHALL BE ROUTED THROUGH BOTTOM OF CABLE TRENCH.
11. CABLES FOR LIGHTING PURPOSE SHALL BE LAID IN G1 PIPE/ TRENCH. SEPARATE DRAWING SHALL BE SUBMITTED FOR LIGHTING SYSTEM.
12. CABLES FOR TRENCH LIGHTING PURPOSE SHALL BE PROVIDED IN TRENCH. ROOM SHALL BE SHOWN IN SEPARATE DRAWING.
13. EARTH CONNECTION 50MM G1 PLAT TO BE WELDED IN PIPERAIL ON THE CABLE SUPPORT BEFORE INSTALLATION OF CABLES.
14. FOR POWER & CONTROL CABLES, SEPARATE PIPES SHALL BE USED CONSIDERING 60% VOID FOR EACH PIPE i.e., 40% FILLING FIBER.
15. ALL OTHER DETAILS PERTAINING TO CABLE WORKS SHALL BE REFLECTED IN THE RESPECTIVE CABLE DRAWINGS.
16. THE TRENCH SHALL BE SUITABLY COVERED AT BOTH ENDS.
17. AFTER LAYING CABLES THE ENDS OF PIPES SHALL BE FULLY SEALED TO PREVENT INGRESS OF WATER INSIDE THE PIPE.
18. THE PURPOSE OF TRENCH LAYING DRAINING IS FOR USE AS FOLLOWS:
 - TO BE USED AS CIVIL INPUT FOR CABLE TRENCHES.
 - FOR LAYING OF CABLE BACKS & TRAY AT SITE.
 - FOR LAYING AND ROUTING AT SITE.
19. ■ INDICATES CULVERT FOR ROAD CROSSING OF CABLE TRENCH.
20. ■ INDICATES ROUTE OF 23KV CABLE FROM TERRACE OF CITY TO STATION TRANSFORMER.



THE INFORMATION ON THIS DOCUMENT IS THE PROPERTY OF BHARAT HEAVY ELECTRICALS LIMITED. IT MUST NOT BE USED DIRECTLY OR INDIRECTLY IN ANY WAY DETRIMENTAL TO THE INTEREST OF THE COMPANY

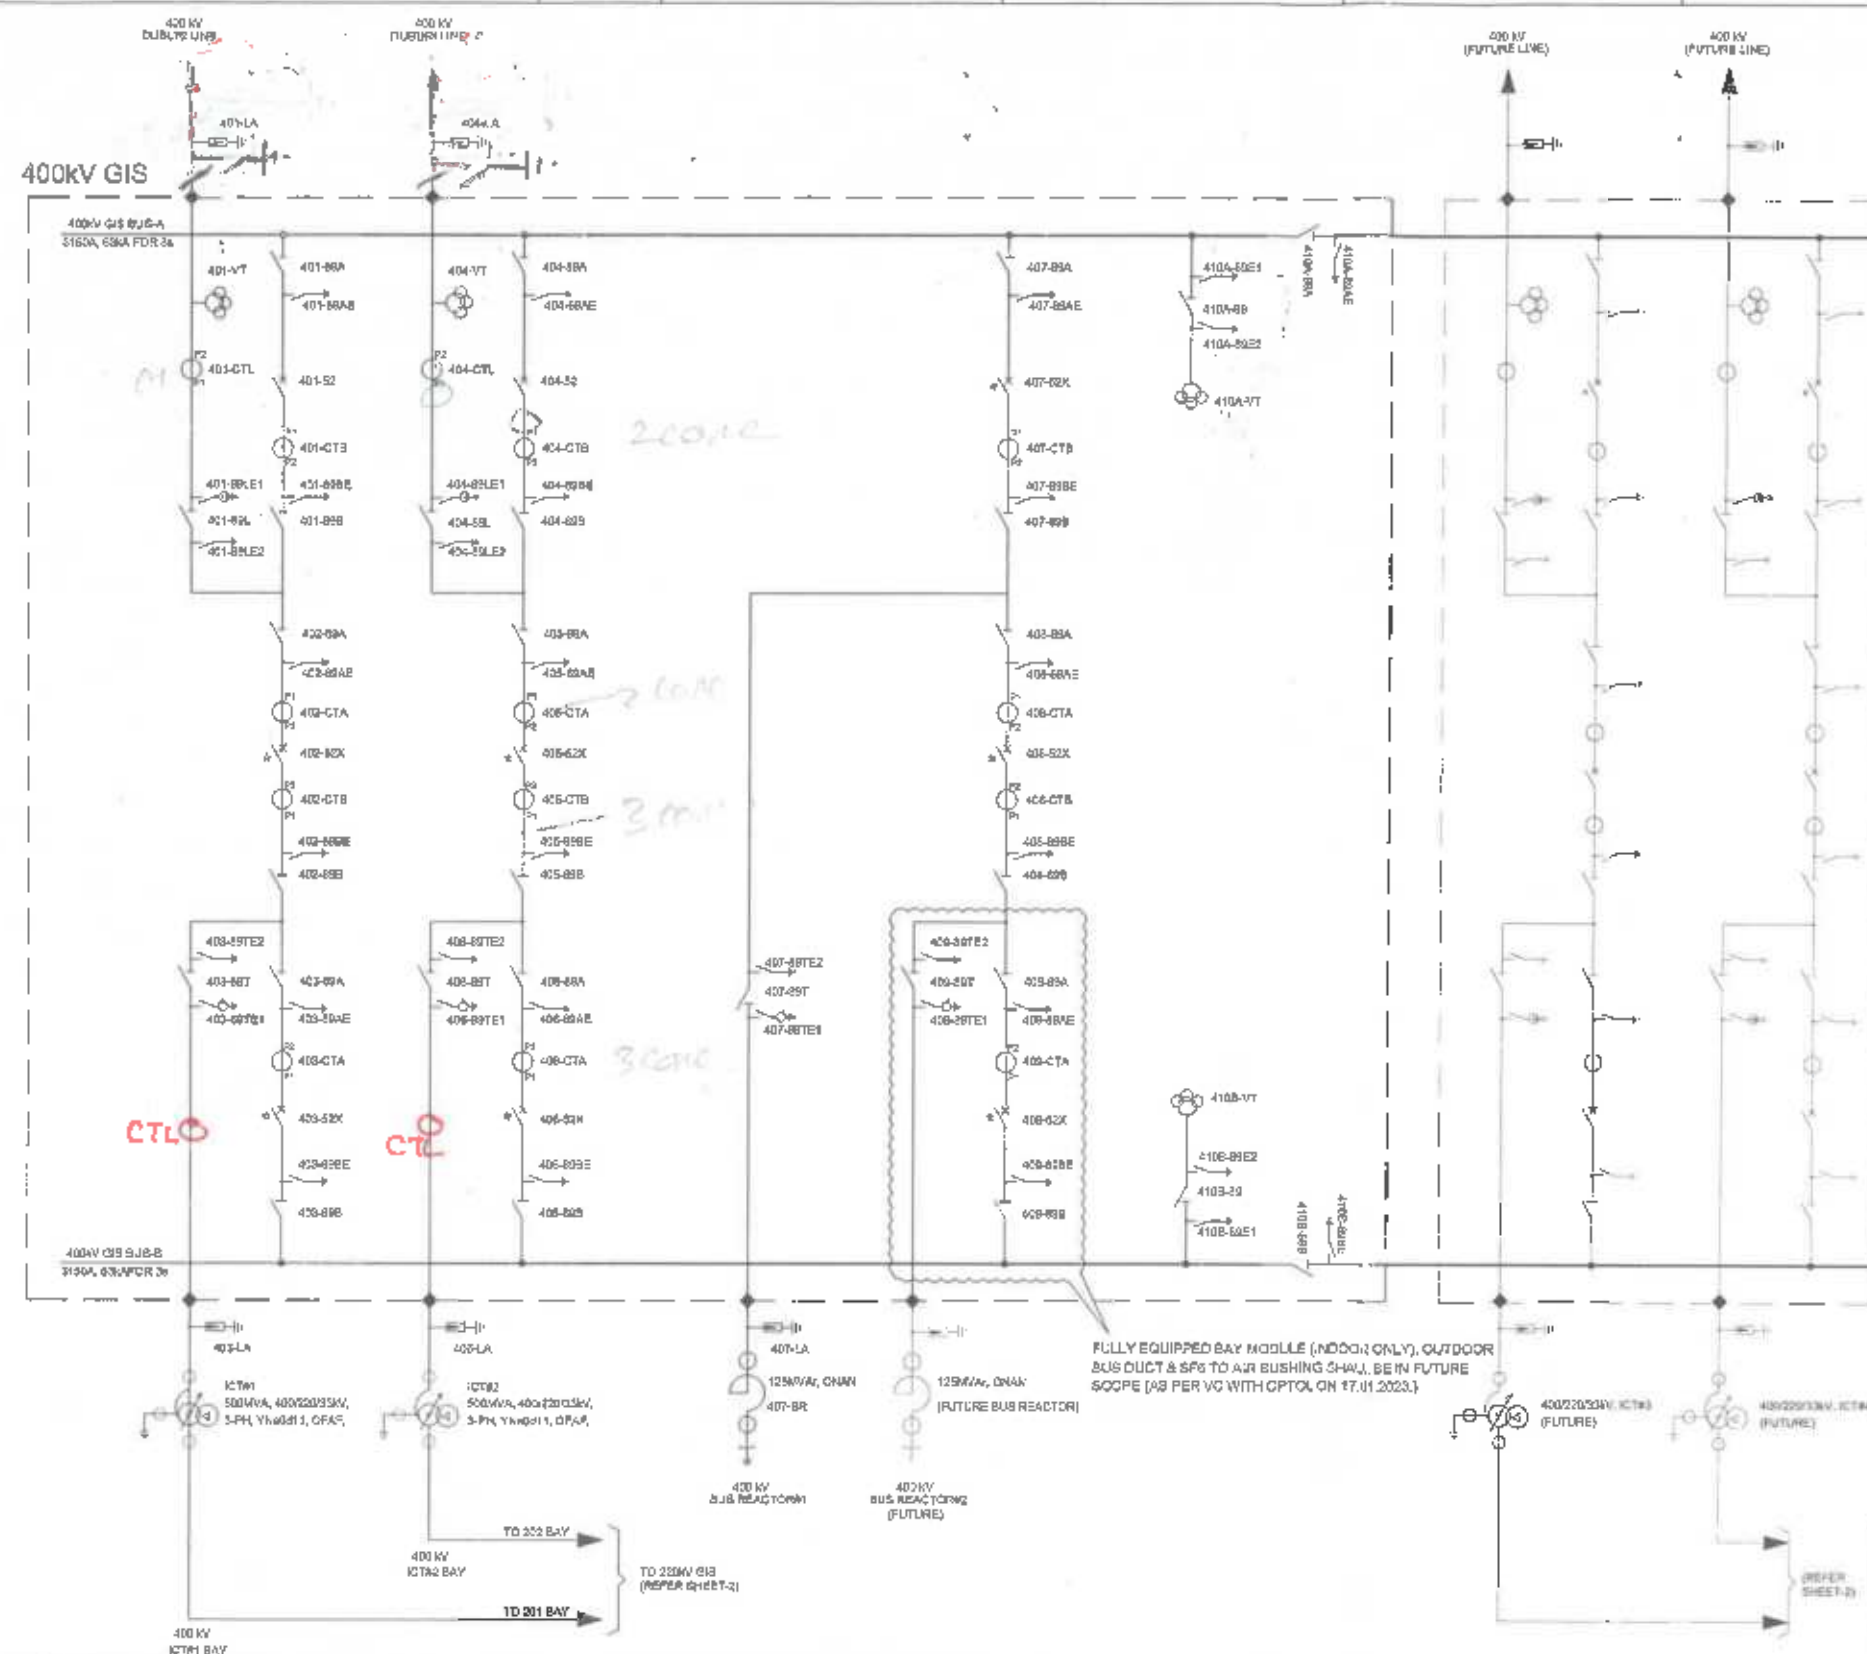

Executive Director
Zonal Office, OPTCL, BBSR

Deputy General Manager (EL.)
Zonal Office, OPTCL
Bhubaneswar

FAULT-LOCATION DESIGNATION FOR SLD

F	D1	DB	A/B/L/T	X
				EARTH SWITCH
				A-EQUIPMENT CONNECTED ON BUS-1 SIDE
				B-EQUIPMENT CONNECTED ON BUS-2 SIDE
				L-DEVICE CONNECTED TO LINE BUS
				T-EQUIPMENT CONNECTED TO TRANSFORMER/REACTOR
				BOUNDS DESIGNATION (REGULATOR)
				347 NO. 1: 01.02.00.00

VOLTAGE LEVEL = 480V

Deputy Manager (EL.)
Zonal Office, OPTCL
Bhubaneswar

COUNTERSIGNED

General MERRILL (CLOP)
 EMT Construction Circle
 10211, Birmingham, Ala 35229

Manager(Elect.)
EHT (Const.) Circle,
OPTCL, Bhubaneswar

Deputy General Manager (Elect.
E.H.T. Construction Division,
OPCL, Paradeep

- ## NÓTEG

1. PRESENT
FUTURE
2. - GIS WITH CONTROLLED SWITCHING DEVICE SHALL BE PROVIDED IN 400KV XCTN, 17CTN & BUS REACTOR BAYS ALONG WITH THEIR ASSOCIATED THE BAYS.
3. BAY SEQUENCE FOR GIS IS TENTATIVE & MAY CHANGE IN LINE WITH THE REQUIREMENTS OF SERVICE CONTINUITY AND STANDARD DESIGN OF OEM.
4. LOCATION OF GIS CT IN BAY MAY CHANGE AS PER THE RECOMMENDATIONS OF OEM.
5. INDIVIDUAL EQUIPMENT OF GIS OR AIS WILL BE PROVIDED AS PER REQUIREMENTS OF TECHNICAL SPECIFICATION & DEVIATIONS (IF ANY) FROM TECHNICAL SPECIFICATION WILL BE TAKEN UP SEPARATELY.
6. CT/NT PARAMETERS OF 400KV GIS ARE DETAILED IN SEPARATE SHEET OF THIS DRAWING. PARAMETERS OF BUSHING CT OF TRANSFORMERS AND BUS REACTOR WILL BE PROVIDED LATER.

7. 420KV 3150A, 63K isohm with one EJS to be provided in each line feeder.

8. CSP to be provided on both the 400KV Line Bay.

PROJECT:		400/220KV GIS SUBSTATION AT ERSAMA, ODISHA & 400KV AIS FEEDER BAY EXTENSION AT DUBURI, ODISHA				
OTHER:		ODISHA POWER TRANSMISSION CORPORATION LIMITED				
 BHARAT HEAVY ELECTRICALS LTD. TRANSMISSION BUSINESS GROUP HYDRA		DRN.	NAME	SNCL	DATE	NO. VAL
		CHD.	AK			
		APPD.	OMS			
			VK			
DEPT. TEG CODE	UNITD. DIMS. OR, 7/4/7		SCALE	WEIGHT (KG)	REF. TO ASSY. DRG.	ITEM NO.
			N.T.S	N.A.	N.A.	N.A.
TITLE		CARGO CODE		RE		
SINGLE LINE DIAGRAM OF 400/220KV GIS SUB STATION AT ERSAMA		N.A.		TB-S-420-510-001		
		SHT. No 01		NO. OF SHT 06		

FIRST ANGLE PROJECTION

(ALL DIMENSIONS ARE IN mm)

100-3-420-510-001

DRG. NO.

6


5

4

3

2

1

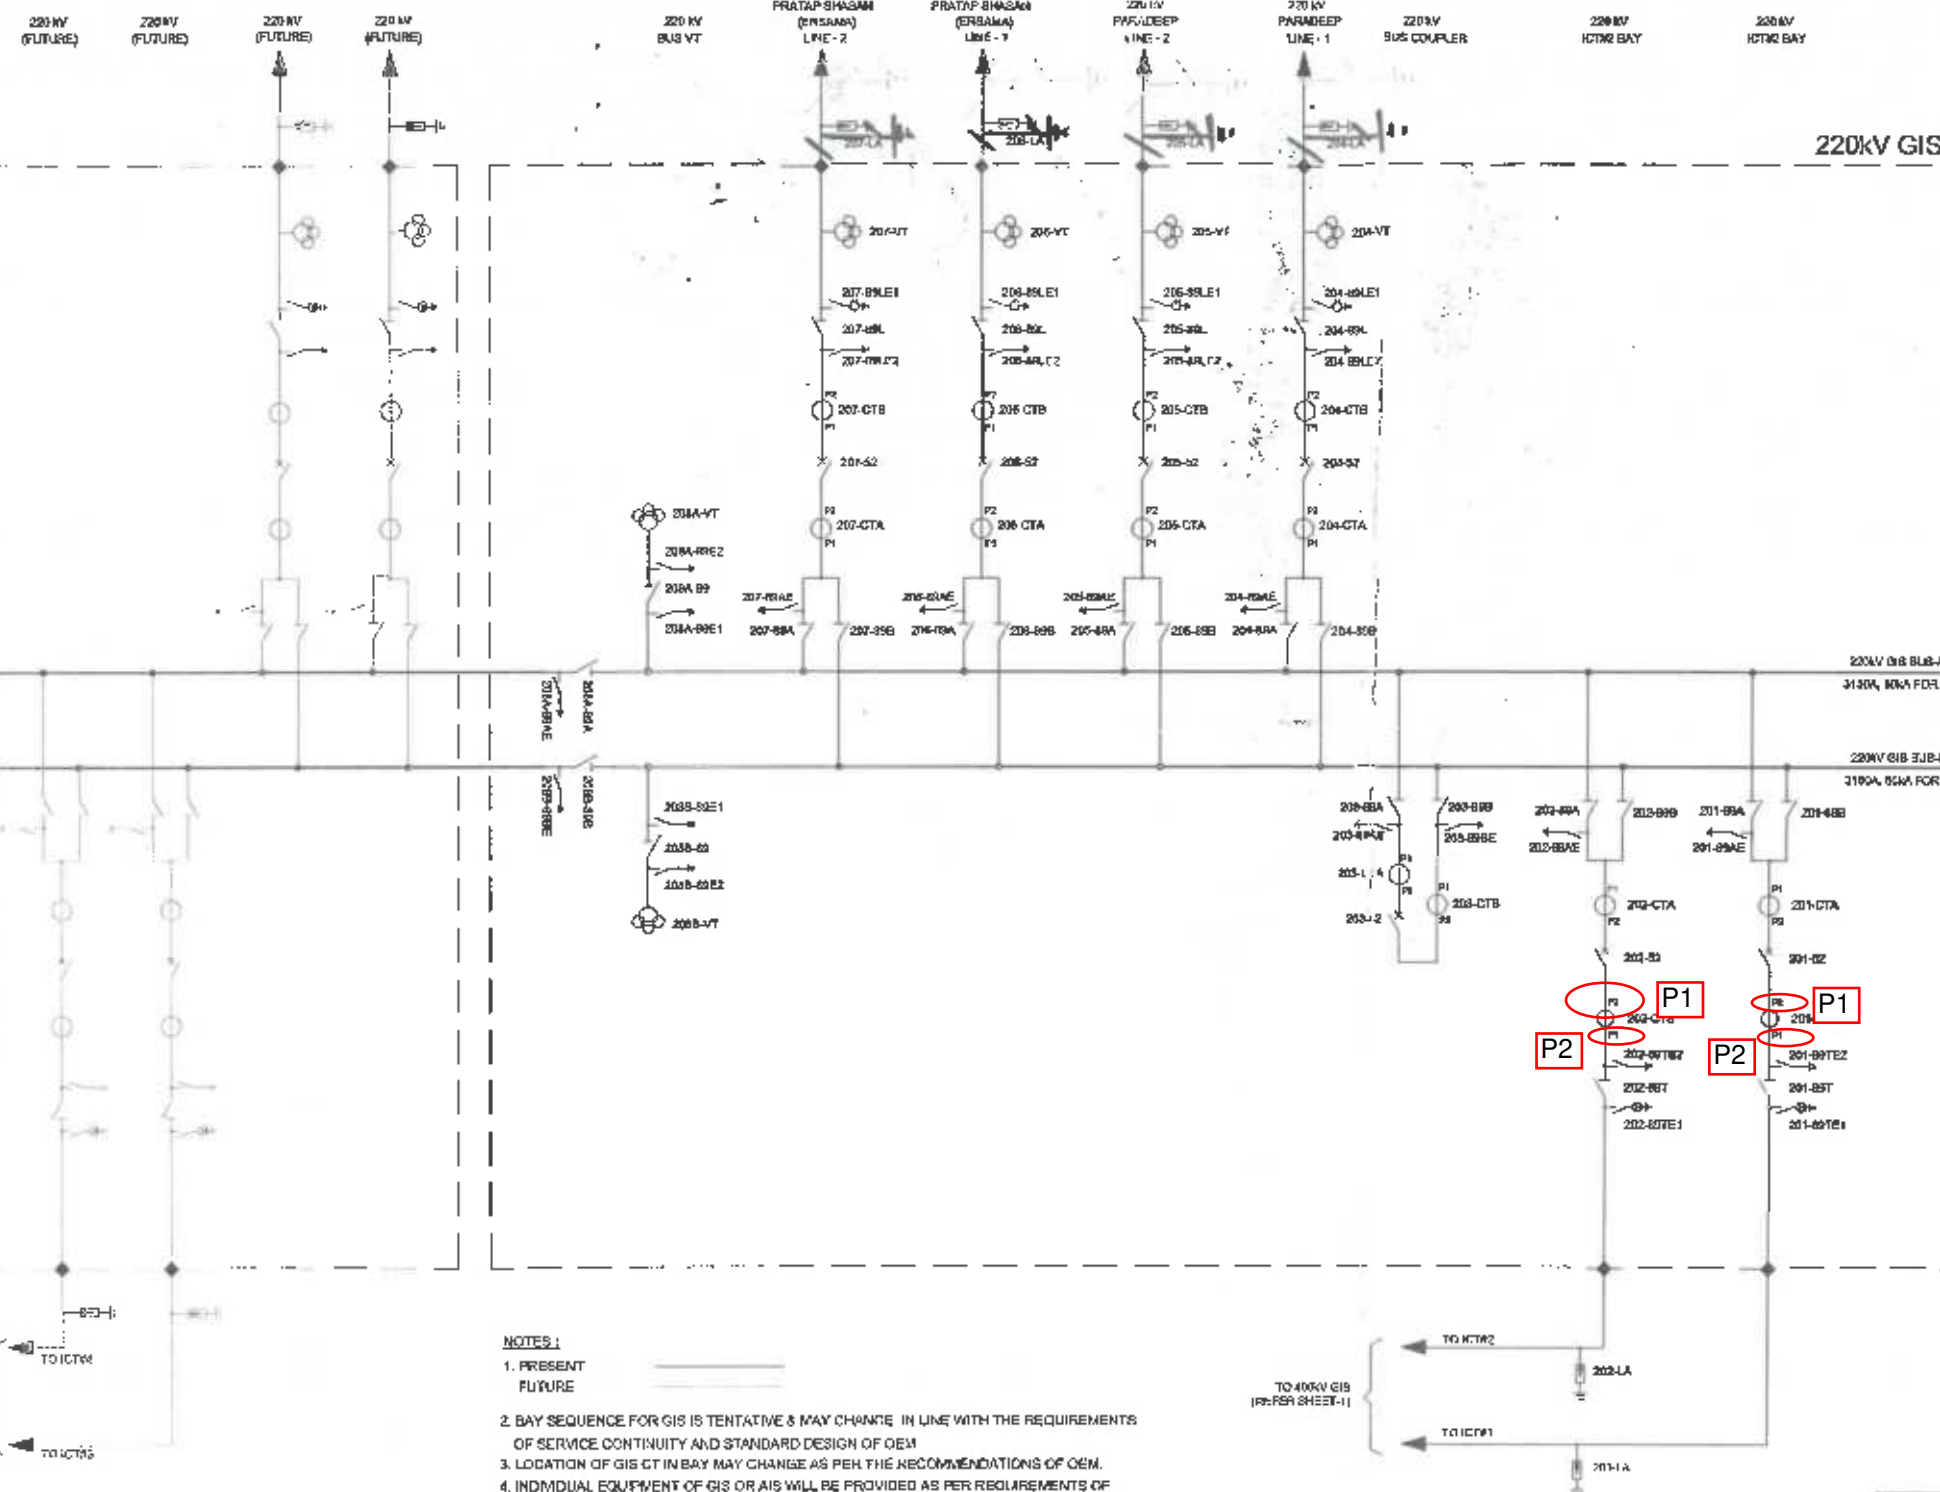

APPROVED

Executive Director
Zonal Office, OPTCL, BBSRDeputy General Manager (EL.)
Zonal Office, OPTCL
Bhubaneswar

EQUIPMENT DESIGNATION FOR SLD

2	01	00	A/B/L/T	E
EARTH SWITCH				
A-EQUIPMENT CONNECTED ON BUS-1 SIDE				
B-EQUIPMENT CONNECTED ON BUS-2 SIDE				
L-DEVICE CONNECTED TO LINE SIDE				
T-EQUIPMENT CONNECTED TO TRANSFORMER/REACTOR				
EQUIPMENT IDENTIFICATION (ISOLATOR)				
BAY NO. : 01 02 ... n				
VOLTAGE LEVEL : 220KV				

Deputy Manager (EL.)
Zonal Office, OPTCL
BhubaneswarDeputy General Manager (Elect.)
E.H.T. Construction Division,
OPTCL, ParadeepManager (Elect.)
EHT (Const.) Circle,
OPTCL, Bhubaneswar

COUNTERSIGNED

General Manager (ELC.)
EHT, Construction Circle
OPTCL, Bhubaneswar

NOTES:

1. PRESENT
FUTURE
2. BAY SEQUENCE FOR GIS IS TENTATIVE & MAY CHANGE IN LINE WITH THE REQUIREMENTS OF SERVICE CONTINUITY AND STANDARD DESIGN OF OEM.
3. LOCATION OF GIS CT IN BAY MAY CHANGE AS PER THE RECOMMENDATIONS OF OEM.
4. INDIVIDUAL EQUIPMENT OF GIS OR AIS WILL BE PROVIDED AS PER REQUIREMENTS OF TECHNICAL SPECIFICATION & DEVIATIONS (IF ANY) FROM TECHNICAL SPECIFICATION WILL BE TAKEN UP SEPARATELY.
5. CT/VT PARAMETERS OF 220KV GIS ARE DETAILED IN SEPARATE SHEET OF THIS DRAWING. PARAMETERS OF BUSHING CT OF TRANSFORMERS AND BUS REACTOR WILL BE PROVIDED LATER.

6. 245 KV 2000A 40 KA S/I with one E/S to be provided in each line feeder.

REV.	DATE	ALTERED	REV.	DATE	ALTERED	REV.	DATE	ALTERED	REV.	DATE	ALTERED
		CHD/APPD			CHD/APPD			CHD/APPD			CHD/APPD

ZONE	ZONE	ZONE	ZONE	ZONE	ZONE
------	------	------	------	------	------

PROJECT:	400/220KV GIS SUBSTATION AT ERSAMA, ODISHA & 400KV AIS FEEDER BAY EXTENSION AT DUBURI, ODISHA							
OWNER:	ODISHA POWER TRANSMISSION CORPORATION LIMITED							
			BIHARAT HEAVY ELECTRICALS LTD.		NAME	SIGN.	DATE	
			TRANSMISSION BUSINESS GROUP		DRN.	AK		
			NOIDA		CHD.	JKS		
					APPO.	VK		
DEPT. TAG CODE	UNVOL. DIMS. OR. 9/24/17	SCALE N.T.S	WEIGHT (KG) N.A.	EFF. TO ASSY. JOB. N.A.	ILLU. NO. N.A.			
TITLE				CARD CODE	BRDNO.			
SINGLE LINE DIAGRAM OF 400/220KV GIS SUB STATION AT ERSAMA				NA	TR-3-420-510-001			
					SHT. No. 02 NO. OF SHT. 05			

512E-A9

S.N.	DESCRIPTION	SYMBOL	LEGEND	BAY NO./LOCATION	UNIT	QTY
1.	400KV, 3150A, 63KA FOR 3 SEC, 3-PH CIRCUIT BREAKER		52	401, 404	SETS	02
2.	400KV, 3150A, 63KA FOR 3 SEC, 3-PH CIRCUIT BREAKER WITH CSD		52X	402, 403, 405, 406, 407, 408, 409	SETS	07
3.	400KV, 3150A, 63KA FOR 1 SEC, 3-PH DISCONNECTOR		88A 88B 88L 88T 88	401, 402, 403, 404, 405, 406, 407, 408, 409, 410A 401, 402, 403, 404, 405, 406, 407, 408, 409, 410B 401, 404 403, 406, 407, 408 410A, 410B	SETS	26
4.	EARTH SWITCH, 3-PH, GROUP OPERATED		98AE 98BE 99LE2 99TE2 98E1 98E2	401, 402, 403, 404, 405, 406, 407, 408, 409, 410A 401, 402, 403, 404, 406, 407, 408, 409, 410B 401, 404 403, 406, 407, 409 410A, 410B 410A, 410B	SETS	30
5.	HIGH SPEED EARTHING SWITCH, 3-PH, GROUP OPERATED		99LE1 99TE1	401, 404 403, 406, 407, 409	SETS	06
6.	400KV, 3000A, 63KA FOR 1 SEC, 1-PH, CURRENT TRANSFORMER (5-CORE)		CTA CTB	402, 403, 405, 406, 408, 409 401, 402, 404, 405, 407, 408	SETS	36
7.	400KV, 3000A, 63KA FOR 1 SEC, 1-PH, CURRENT TRANSFORMER (2-CORE)		CTL	401, 404	SETS	06
8.	400KV, 1-PH, 3 SECONDARY VOLTAGE TRANSFORMER		VT	401, 404, 410A, 410B	SETS	12

S.N.	DESCRIPTION	SYMBOL	LEGEND	BAY NO./LOCATION	UNIT	QTY
1.	220KV,3150A, 50KA FOR 3 SEC, 3-PH CIRCUIT BREAKER		52	201, 202, 203, 204, 205, 206, 207	SETS	07
2.	220KV,3150A, 50KA FOR 1 SEC, 3-PH GROUP OPERATED DISCONNECTOR		B9 B9A B9B B9L B9T	208A, 208B 201, 202, 203, 204, 205, 206, 207, 208A 201, 202, 203, 204, 205, 206, 207, 208B 204, 205, 206, 207 201, 202	SETS	24
3.	EARTH SWITCH, 3-PH, GROUP OPERATED		B9AE B9BE B9LE2 B9TE2 B9E1 B9E2	201, 202, 203, 204, 205, 206, 207, 208A 203, 208B 204, 205, 206, 207 201, 202 208A, 208B 208A, 208B	SETS	20
4.	HIGH SPEED EARTHING SWITCH, 3-PH, GROUP OPERATED		B9TE1 B9LE1	201, 202 204, 205, 206, 207	SETS	06
5.	220KV, 3000A, 50KA FOR 1 SEC, 1-PH,CURRENT TRANSFORMER (2-CORE)		CTA	201, 202, 203, 204, 205, 206, 207	SETS	21
6.	220KV, 3000A, 50KA FOR 1 SEC, 1-PH, CURRENT TRANSFORMER (3-CORE)		CTB	201, 202, 203, 204, 205, 206, 207	SETS	21
7.	220KV, 1-PH, 3 SECONDARY VOLTAGE TRANSFORMER		VT	204, 205, 206, 207, 208A, 208B	SETS	18

S.N.	DESCRIPTION	SYMBOL	LEGEND	BAY NO/LOCATION	UNIT	QTY
1.	500MVA, 400/220/33KV, YNd11, DFAF, 3-PH ICT		ICT	ICT#1, ICT#2	NOS	02
2.	400KV, 125MVA, 3-PH BUS REACTOR		BR	409	NOS	01
3.	380KV, 20KA, CLASS-IV, 83KA, 1-PH, SURGE ARRESTER		LA	401, 403, 404, 406, 409	NOS	15
4.	218KV, 10KA, CLASS-III, 50KA, 1-PH, SURGE ARRESTER		LA	201, 202, 204, 205, 206, 207	NOS	18
5.	400KV, 3150A, 83KA FOR 1 SEC. SFB TO AIR BUSHING			401, 403, 404, 406, 407, 409	NOS	15
6.	220KV, 3150A, 50KA FOR 1 SEC. SFB TO AIR BUSHING			201, 202, 204, 205, 206, 207	NOS	18

S.N.	SYSTEM PARAMETERS	400kV	220kV
1.	NOMINAL VOLTAGE	400kV ✓	220kV ✓
2.	HIGHEST SYSTEM VOLTAGE	420kV ✓	245kV ✓
3.	RATED FREQUENCY	50Hz ✓	50Hz ✓
4.	RATED SHORT TIME CURRENT	83kA for 3s/1s (as applicable) ✓	50kA for 3s/1s (as applicable)
5.	POWER FREQUENCY WITHSTAND VOLTAGE	630kV (rms) ✓	460kV (rms)
6.	LIGHTNING IMPULSE WITHSTAND VOLTAGE	±1425 kV peak ✓	±1050 kV peak ✓
7.	SWITCHING IMPULSE WITHSTAND VOLTAGE	±1050 kV peak ✓	N/A
8.	CREEPAGE	31mm/kV (13020mm)	31mm/kV (7995mm)
9.	GROUNDING	Effectively earthed	Effectively earthed

Deputy General Manager (EL)
Zonal Office, OPTCL
Bhubaneswar

COUNTERSIGNED

General Manager (E.L.C.)
EHT, Construction Circle
OPTCL, Bhubaneswar

Manager(Elect.)
EHT (Const.) Circle,
OPTCL, Bangalore

Deputy Manager (EL.)
Zonal Office, OPTCL
Bhubaneswar

Deputy General Manager (Elect.)
E.H.T. Construction Division,
OPTCL, Paradeep

REV.	DATE	ALTERED	REV.	DATE	ALTERED	REV.	DATE	ALTERED	REV.	DATE	ALTERED
		CHD/APPD			CHD/APPD			CHD/APPD			CHD/APPD

PROJECT:	400/220KV GIS SUBSTATION AT ERSAMA, ODISHA & 400KV AIS FEEDER BAY EXTENSION AT DUDURI, ODISHA									
OWNER:	ODISHA POWER TRANSMISSION CORPORATION LIMITED									
		BHARAT HEAVY ELECTRICALS LTD. TRANSMISSION BUSINESS GROUP NOIDA				NAME	SIZE	DATE	BY	CHECKED
DESIGN NO.	REV.	DATE	BY	CHECKED	DATE	BY	CHECKED	DATE	BY	CHECKED
001	1.0	10/10/2018	AK	AK	10/10/2018	AK	AK	10/10/2018	AK	AK
002	2.0	10/10/2018	AK	AK	10/10/2018	AK	AK	10/10/2018	AK	AK
003	3.0	10/10/2018	AK	AK	10/10/2018	AK	AK	10/10/2018	AK	AK
118	118.0	10/10/2018	AK	AK	10/10/2018	AK	AK	10/10/2018	AK	AK
119	119.0	10/10/2018	AK	AK	10/10/2018	AK				

TB-3-420-510-001

DRG. NO.

6

5

4


3

2

1

FROM ICT # 1
TERTIARY LOADING
500MVA, 400/220/33KV

FROM ICT # 2
TERTIARY LOADING
500MVA, 400/220/33KV

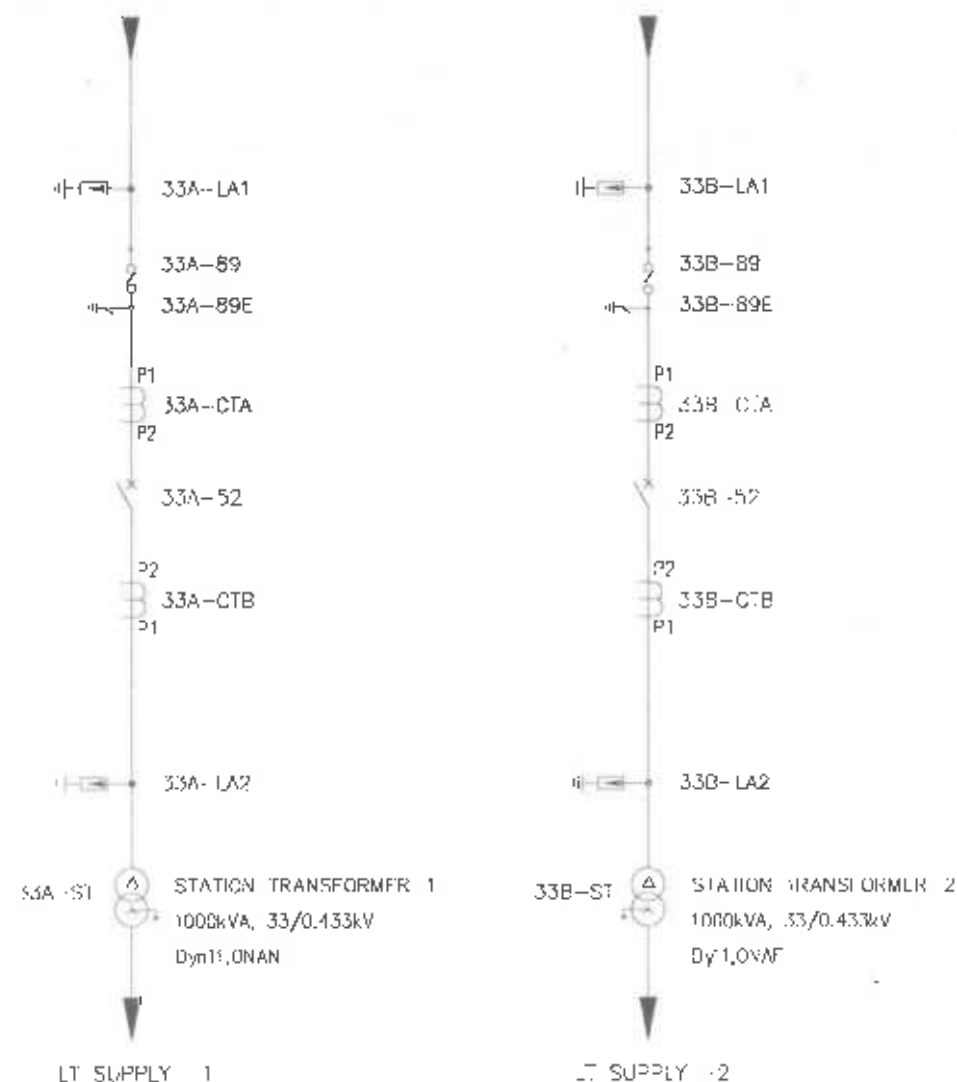

33kV SYSTEM PARAMETERS:-

S.N.	SYSTEM PARAMETERS	33kV
1.	NOMINAL VOLTAGE	33kV <i>35.2kV</i>
2.	HIGHEST SYSTEM VOLTAGE	36kV <i>35.2kV</i>
3.	RATED FREQUENCY	50Hz
4.	RATED SHORT TIME CURRENT	31.5kA for 3s/1s (as applicable)
5.	POWER FREQUENCY WITHSTAND VOLTAGE	70kV (rms) <i>25kV (rms)</i>
6.	LIGHTNING IMPULSE WITHSTAND VOLTAGE	±170 kV peak <i>250kV peak</i>
7.	CREEPAGE	31mm/kV (1116mm) <i>1612mm</i>
8.	GROUNDING	Effectively earthed

BILL OF QTY. FOR 33kV OUTDOOR EQUIPMENT:

SL.NO.	DESCRIPTION	SYMBOL	LEGEND	BAY NO./ LOCATION	UNIT	QTY. (NO.)
1	33/0.433kV, 1000kVA, 3-PH OIL FILLED STATION TRANSFORMER		ST	33A, 33B	SET	02
2	36kV, 1250A, 31.5kA FOR 3 SEC., 3-PH VACUUM CIRCUIT BREAKER		52	33A, 33B	SET	02
3	36kV, 1250A, 31.5kA FOR 1 SEC., 3-PH ISOLATOR WITH ONE EARTH SWITCH		89	33A, 33B	SET	02
4	36kV, 50A, 31.5kA FOR 1 SEC., 1-PH, CURRENT TRANSFORMER		CTA	33A, 33B	NOS.	06
5	36kV, 1200A, 31.5kA FOR 1 SEC., 1-PH, CURRENT TRANSFORMER		CTB	33A, 33B	NOS.	06
6	30kV, 10kA, CLASS-III, 1-PH, LIGHTNING ARRESTER		LA1/LA2	33A, 33B	NOS.	12

NOTES:

LT SUPPLY SOURCE -1 & 2: 33kV SIDE OF STATION TRANSFORMERS-1 & 2 ARE TO BE FED THROUGH TERTIARY LOADING OF ICT#1 & ICT#2. FURTHER, AS PER THE REPLY TO PRE-BID QUERY OF P4G-36(1)/2020-21, PROVIDED BY OPTCL IN ADDENDUM-2, EQUIPMENT WITH HIGHEST SYSTEM VOLTAGE OF 36kV ARE BEING PROVIDED IN THIS CIRCUIT.

2. As per tender condition complete design & engineering is on the scope of M/s BHEL, hence 33kV equipment is to be supplied as per data of 1st tertiary bushing.

REV.	DATE	ALTERED	REV.	DATE	ALTERED	REV.	DATE	ALTERED	REV.	DATE	ALTERED
		CHD/APPD			CHD/APPD			CHD/APPD			CHD/APPD
ZONE			ZONE			ZONE			ZONE		

APPROVED

Executive Director
Zonal Office, OPTCL BSR

Deputy General Manager (EL.)
Zonal Office, OPTCL
Bhubaneswar

COUNTERSIGNED

Deputy Manager (EL.)
Zonal Office, OPTCL
Bhubaneswar

Manager (Elect.)
EHT (Construction Circle,
OPTCL, Bhubaneswar

General Manager (EL.)
EHT, Construction Circle
OPTCL, Bhubaneswar

PROJECT: 400/220kV GIS SUBSTATION AT ERSAMA, ODISHA & 400kV AIS FEEDER BAY EXTENSION AT DUBURI, ODISHA

OWNER: ODISHA POWER TRANSMISSION CORPORATION LIMITED

DESIGNER: BHARA HEAVY ELECTRICALS LTD. TRANSMISSION BUSINESS GROUP NOIDA

DOPT. 100 CODE: 9/24/23

TITLE: SINGLE LINE DIAGRAM OF 400/220kV GIS SUB STATION AT ERSAMA

FIRST ANGLE PROJECTION

(ALL DIMENSIONS ARE IN mm)

TB-3-420-510-001

ON DND

6

5

4

3

2

1

400kV GIS CT DETAILS (CTA & CTB)

Core No.	Current Ratio	Output Burden at Lowest Tap (VA)	Minimum KPV (V)	Max. Ie (mA) at KPV	Maximum Rct (Ohms)	Accuracy Class	Purpose
1	3000-2000-1000/1A	-	3000-2000-1000	20-30-40	15-10-5	PS	Protection
2	3000-2000-1000/1A	-	3000-2000-1000	20-30-40	15-10-5	PS	Protection
3	3000-2000-1000/1A	20	-	-	-	0.2s, ISFs5	Metering
4	3000-2000-1000/1A	-	3000-2000-1000	20-30-40	15-10-5	PS	Protection
5	3000-2000-1000/1A	-	3000-2000-1000	20-30-40	15-10-5	PS	Protection

400kV GIS VT DETAILS (VT)

Winding No.	Ratio	Accuracy Class	Rated Burden (VA)	Purpose
1	(400kV/√3) / 110V/√3	0.2	50	Metering
2	(400kV/√3) / 110V/√3	3P	50	Protection
3	(400kV/√3) / 110V/√3	3P	50	Protection

400kV GIS LINE CT DETAILS (CTL)

Core No.	Current Ratio	Output Burden at Lowest Tap (VA)	Minimum KPV (V)	Max. Ie (mA) at KPV	Maximum Rct (Ohms)	Accuracy Class	Purpose
1	3000-2000-1000/1A	10	-	-	-	0.2s, ISFs5	Metering
2	3000-2000-1000/1A	10	-	-	-	0.2s, ISFs5	Metering

220kV GIS VT DETAILS (VT)

Winding No.	Ratio	Accuracy Class	Rated Burden (VA)	Purpose
1	(220kV/√3) / 110V/√3	0.2	50	Metering
2	(220kV/√3) / 110V/√3	3P	50	Protection
3	(220kV/√3) / 110V/√3	3P	50	Protection

220kV GIS CT DETAILS

Core No.	Current Ratio	Output Burden at Lowest Tap (VA)	Minimum KPV (V)	Max. Ie (mA) at KPV	Maximum Rct (Ohms)	Accuracy Class	Purpose
CTA							
1	1600-800/1 A	-	1600-800	20-40	8-4	PS	Protection
2	1600-800/1 A	-	1600-800	20-40	8-4	PS	Protection
CTB							
3	1600-800/1 A	-	1600-800	20-40	8-4	PS	Protection
2	1600-800/1 A	-	1600-800	20-40	8-4	PS	Protection
1	1600-800/1 A	20	-	-	8-4	0.2s, ISFs5	Metering

33kV OUTDOOR CT DETAILS

Core No.	Current Ratio	Output Burden at Lowest Tap (VA)	Minimum KPV (V)	Max. Ie (mA) at KPV	Maximum Rct (Ohms)	Accuracy Class	Purpose
CTA							
1	50-25/1 A	15	-	-	-	PS	Protection
2	50-25/1 A	15	-	-	-	0.2s, ISFs5	Metering
CTB							
1	1200-600/1 A	-	1200-600	50-100	6-3	PS	Protection
2	1200-600/1 A	-	1200-600	50-100	6-3	PS	Protection
3	1200-600/1 A	-	1200-600	50-100	6-3	PS	Protection

NOTES:

1. PARAMETERS OF BUSHING CT OF TRANSFORMERS AND BUS REACTOR WILL BE PROVIDED LATER.

REV.	DATE	ALTERED	REV.	DATE	ALTERED	REV.	DATE	ALTERED	REV.	DATE	ALTERED
		CHD/APPD			CHD/APPD			CHD/APPD			CHD/APPD

ZONE

ZONE

ZONE

ZONE

PROJECT:		400/220kV GIS SUBSTATION AT ERSAMA, ODISHA & 400kV AIS FEEDER BAY EXTENSION AT DUBURI, ODISHA			
OWNER:		ODISHA POWER TRANSMISSION CORPORATION LIMITED			
DESIGNER:		BHARAT HEAVY ELECTRICALS LTD. TRANSMISSION BUSINESS GROUP		NOIDA	
DEPT. TB2	JHDL DWS	SCALE	WEIGHT (KG)	REF. TO ASSY. DRG.	ITEM NO.
CODE	GR. 2/11/1	N.T.S	N.A.	N.A.	N.A.
TITLE		SINGLE LINE DIAGRAM OF 400/220kV GIS SUB STATION AT ERSAMA		REV.	
CARD CODE		TB-3-420-510-001		00	
SMT. No.		Q5		NO. OF SMT. Q6	

1 SIZE-A0