



**3x40 MW NTPC RAMMAM STAGE-III
HYDRO ELECTRIC PROJECT
HVAC SYSTEM
TENDER DRAWINGS**

SPECIFICATION No: PE-TS-414-571-11000-A001

SECTION : II

Sub Section : 6

REV. 00


DATE: MARCH 2021

SECTION: II

SUB SECTION: 6

TENDER DRAWINGS

COPY RIGHT AND CONFIDENTIAL
The information on this document is the property of BHARAT HEAVY ELECTRICALS LIMITED
it must not be used directly or indirectly in any way detrimental to the interest of the company.
COMPUTER FILE NAME :

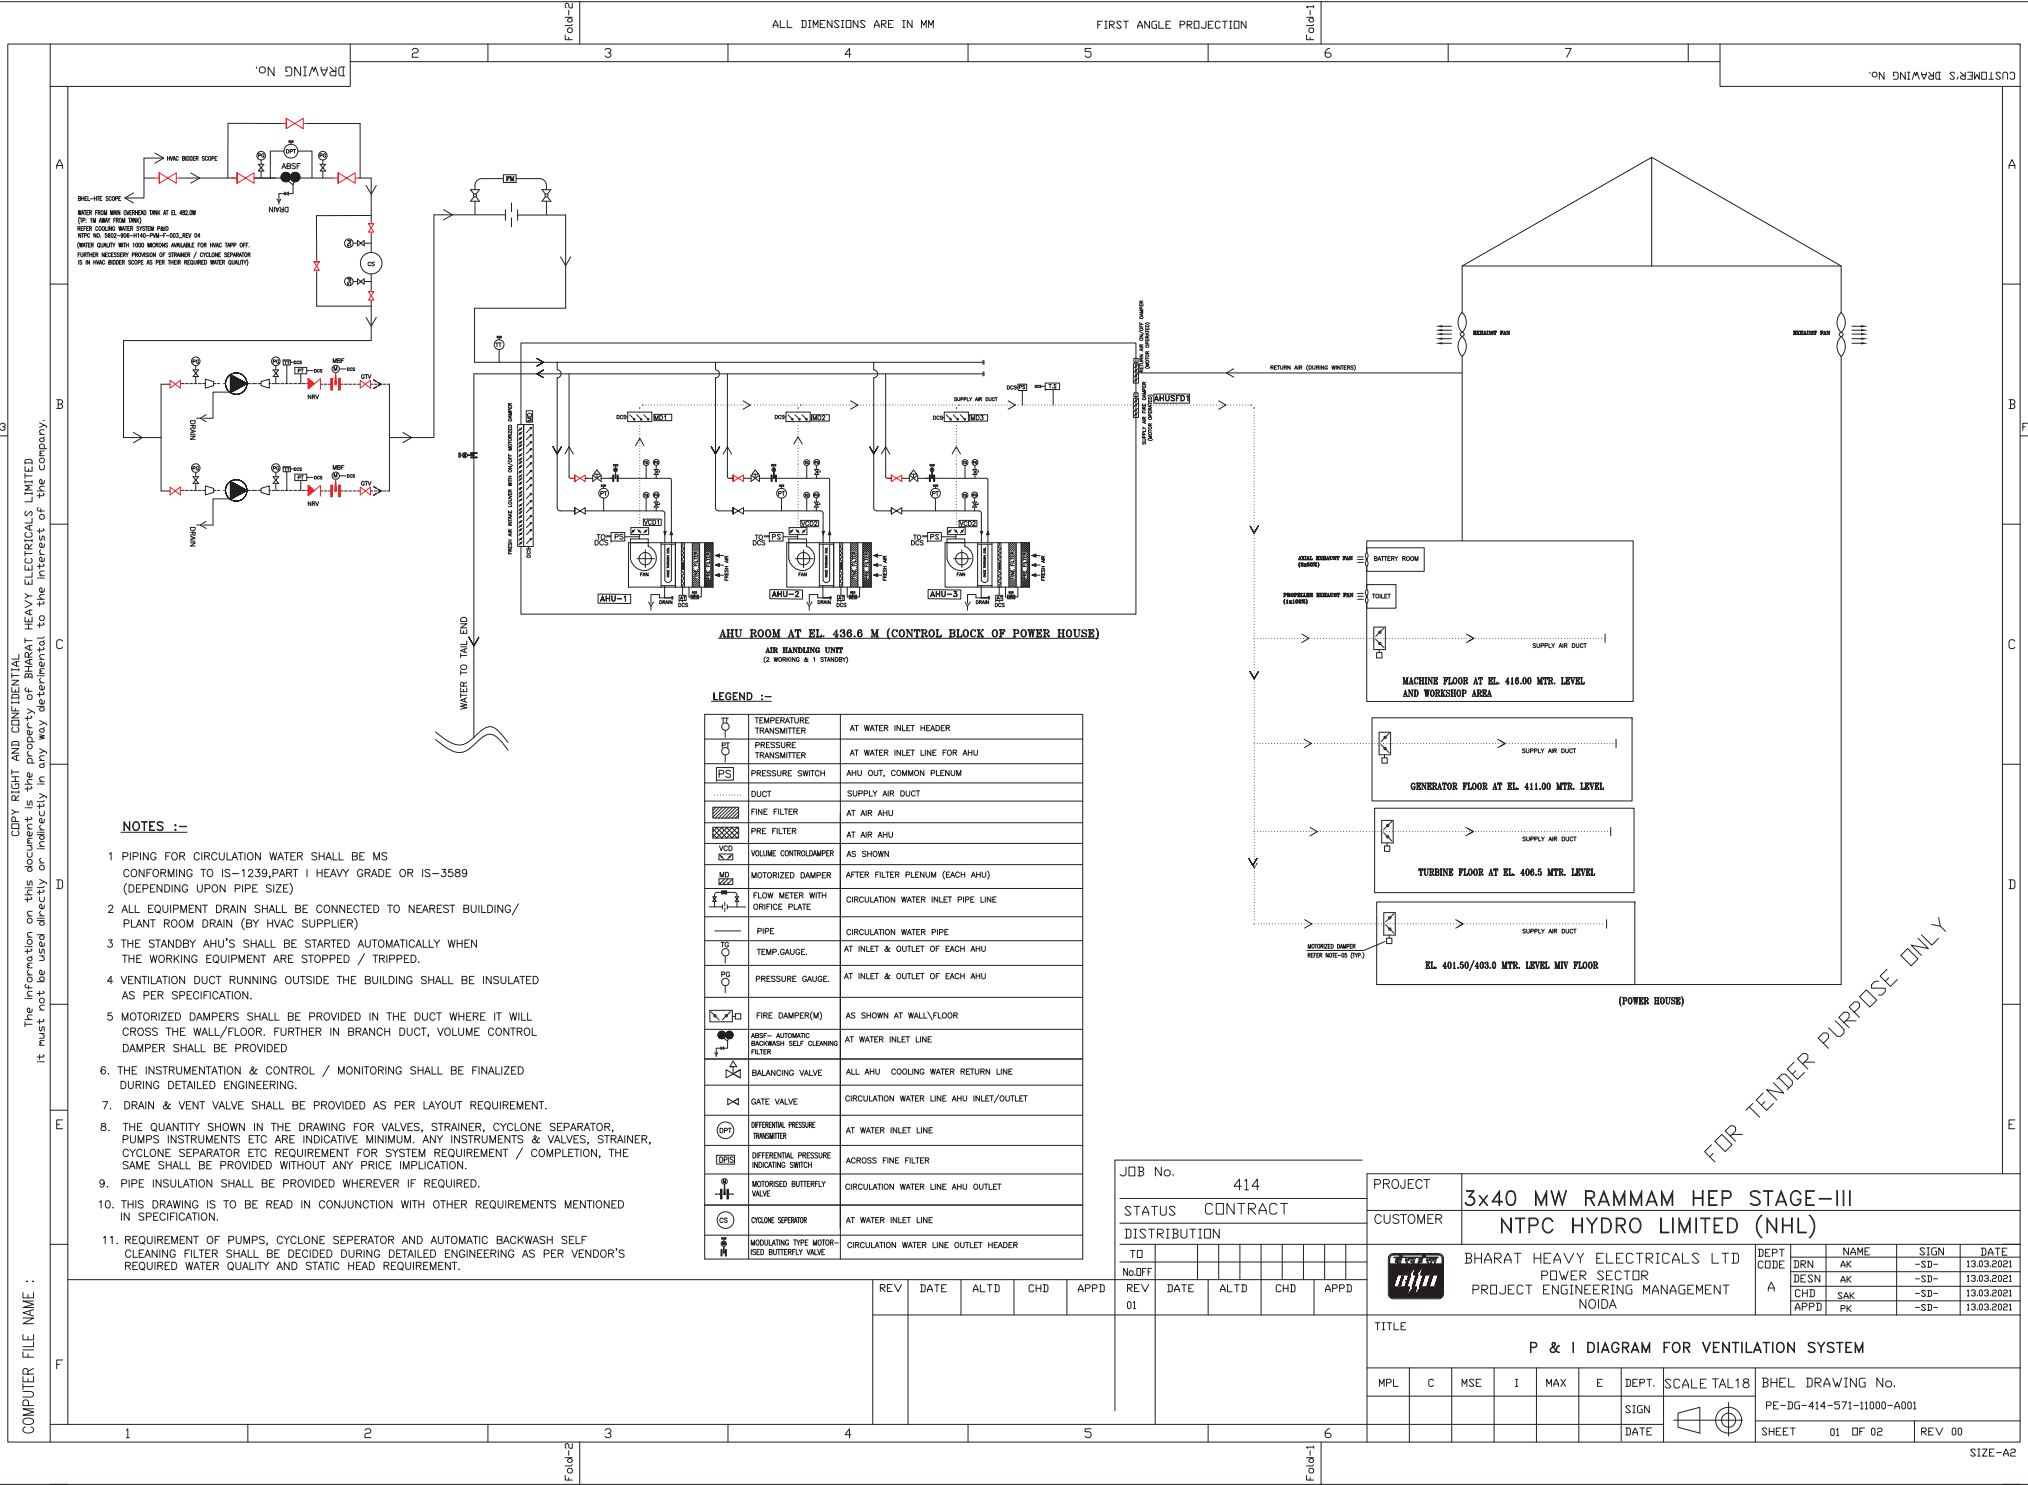

JOB No. 414		PROJECT		3x40 MW RAMMAM HEP STAGE-III	
STATUS CONTRACT		CUSTOMER		NTPC HYDRO LIMITED (NHL)	
DISTRIBUTION		BHARAT HEAVY ELECTRICALS LTD POWER SECTOR PROJECT ENGINEERING MANAGEMENT NOIDA		DEPT CODE A	
TO		TITLE		P & I DIAGRAM FOR VENTILATION SYSTEM	
No. OFF		MPL		C	
REV 01		MSE		I	
		MAX		E	
		DEPT.		SCALE TAIL 18	
		SIGN		BHEL DRAWING No.	
		DATE		PE-DG-414-571-11000-A001	
				SHEET 01 OF 02	
				REV 00	

FOR TENDER PURPOSE ONLY

COPY RIGHT AND CONFIDENTIAL
The Information on this document is the property of BHARAT HEAVY ELECTRICALS LIMITED
it must not be used directly or indirectly in any way detrimental to the interest of the company.


COMPUTER FILE NAME :

DRAWING No.

ALL DIMENSIONS ARE IN MM

FIRST ANGLE PROJECTION

CUSTOMER'S DRAWING No.

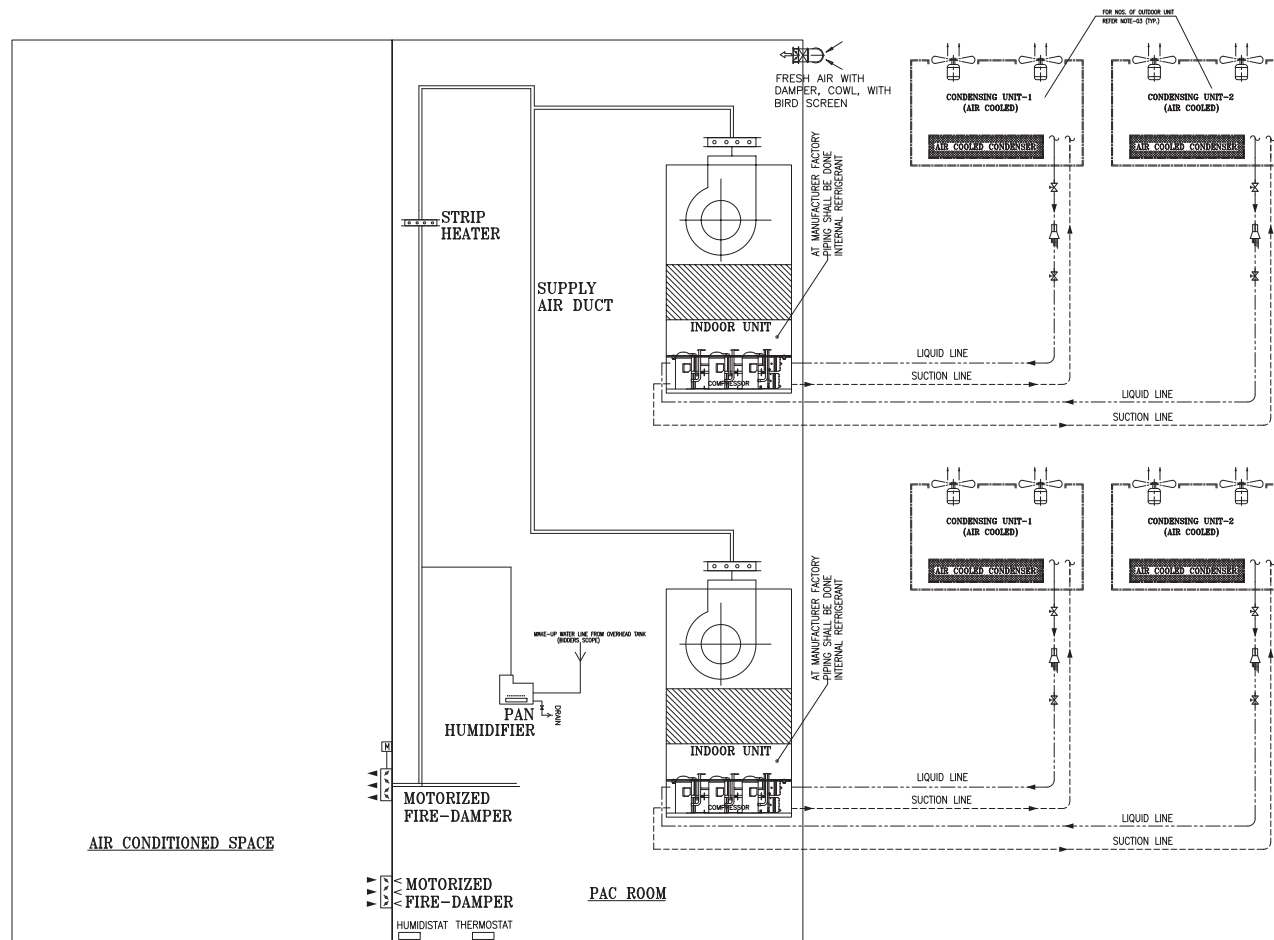

FOR TENDER PURPOSE ONLY

NOTES :- SCHEMATIC FOR AIR COOLED PACKAGED AIR CONDITIONERS (1W+1S) TYP.

1. THIS IS A TYPICAL P&ID FOR PAC AND IT MAY VARY AS PER OEM DESIGN.
2. ACTUAL QUANTITY OF PAC SHALL BE AS PER HEAT LOAD CALCULATION OF RESPECTIVE AC AREA.
3. THE NUMBER OF COMPRESSOR & OUTDOOR CONDENSING UNIT FOR EACH PAC SHALL BE AS PER OEM DESIGN.
4. AC DUCT SHALL BE INSULATED AS PER SPECIFICATION.
5. THE INSTRUMENTATION & CONTROL SHALL BE FINALIZED DURING DETAILED ENGINEERING.
6. THE QUANTITY SHOWN IN THE DRAWING FOR VALVES, INSTRUMENTS ARE INDICATIVE MINIMUM, ANY INSTRUMENTS & VALVES REQUIREMENT FOR SYSTEM REQUIREMENT / COMPLETION, THE SAME SHALL BE PROVIDED WITHOUT ANY PRICE IMPLICATION.
7. PIPE INSULATION SHALL BE PROVIDED WHEREVER IF REQUIRED.
8. THIS DRAWING IS TO BE READ IN CONJUNCTION WITH OTHER REQUIREMENTS MENTIONED IN SPECIFICATION.

JOB No.		414		PROJECT		3x40 MW RAMMAM HEP STAGE-III												
STATUS		CONTRACT		CUSTOMER		NTPC HYDRO LIMITED (NHL)												
DISTRIBUTION								 BHARAT HEAVY ELECTRICALS LTD POWER SECTOR PROJECT ENGINEERING MANAGEMENT NOIDA										
TD														DEPT CODE A	NAME	SIGN	DATE	
No OFF															DRN	YK	-SD-	13.03.2021
REV		DATE	ALTD	CHD	APPD										DESN	AK	-SD-	13.03.2021
								CHD	LJ	-SD-	13.03.2021							
								APPD	GB	-SD-	13.03.2021							
TITLE						P & I DIAGRAM FOR PACKAGE AIR CONDITIONING												
MPL		C	MSE	I	MAX	E	DEPT.	SCALE TAL18	BHEL DRAWING No.									
							SIGN		PE-DG-414-571-11000-A001									
							DATE		SHEET 02 OF 02									
									REV 00									

SIZE-A2



AFGANISTAN

PAKISTAN


ARABIAN SEA

CHINA

ARUNACHAL PRADESH

SIKKIM
BHUTAN
WEST BENGAL
BANGLADESH

BAY OF BENGAL

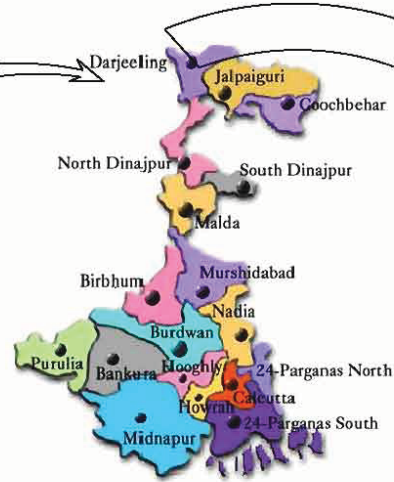


WEST BENGAL STATE



PROJECT SITE

FOR TENDER PURPOSE ONLY

एनटीपीसी हाइड्रो लि० NTPCHYDROLIMITED (A wholly owned subsidiary of NTPC)	
PROJECT: RAMMAM STAGE - III HYDROELECTRIC PROJECT [3X40MW]	
TITLE: GEOGRAPHICAL LOCATION OF PROJECT	
Drawn by	Checked by
Designed by	Approved by
NHL Drawing Number : 5602-002-P-E-C-A-01	
FORMAT : SCALE :	
KPCL Drawing Number : CCED/KPCL/CONSUL/AMMAM-III/01 REV G NOV-08	
KARNATAKA POWER CORPORATION LIMITED CONSULTANCY AND ENGINEERING SERVICES DIVISION	

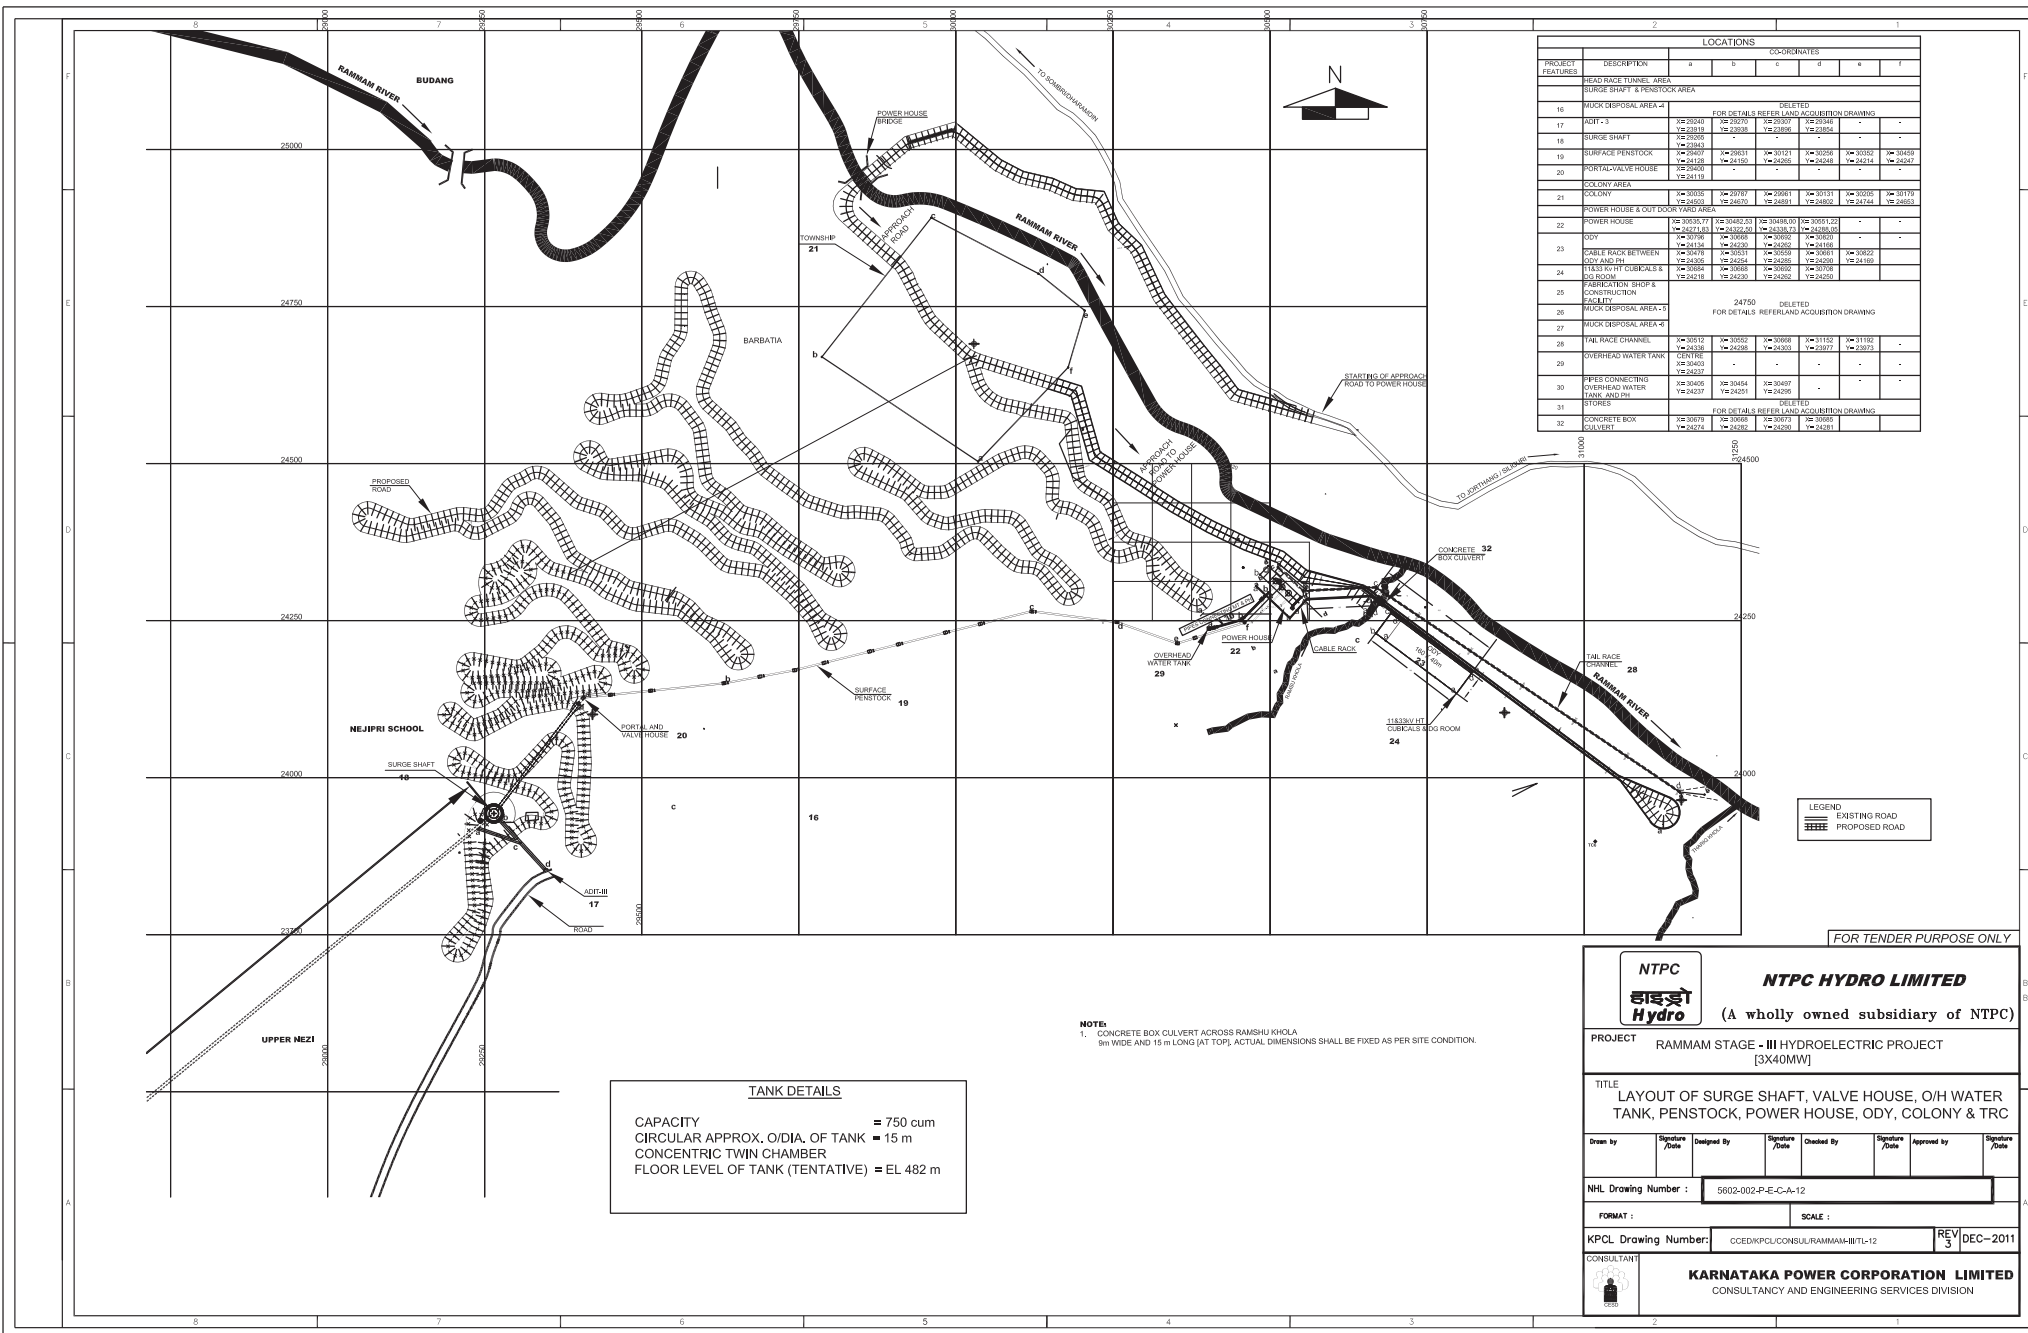

LOCATIONS		COORDINATES						
PROJECT FEATURES	DESCRIPTION	A	B	C	D	E	F	
HEAD RACE TUNNEL AREA								
SURGE SHAFT & PENSTOCK AREA								
16	MUCK DISPOSAL AREA-4	DELETED						
17	ADIT - 3	FOR DETAILS REFER LAND ACQUISITION DRAWINGS						
18	SURGE SHAFT	Y=24240	X=30740	Y=24240	X=30740	Y=24240	X=30740	
19	SURFACE PENSTOCK	Y=24240	X=30740	Y=24240	X=30740	Y=24240	X=30740	
20	PORTAL/VALVE HOUSE	Y=24240	X=30740	Y=24240	X=30740	Y=24240	X=30740	
21	COLONY AREA	Y=24240	X=30740	Y=24240	X=30740	Y=24240	X=30740	
22	POWER HOUSE & OUT DOOR YARD AREA	Y=24240	X=30740	Y=24240	X=30740	Y=24240	X=30740	
23	ODY	Y=24240	X=30740	Y=24240	X=30740	Y=24240	X=30740	
24	CABLE RACK BETWEEN ODY AND PH	Y=24240	X=30740	Y=24240	X=30740	Y=24240	X=30740	
25	TRUSS RIGID CURBICAL & SIG ROOM	Y=24240	X=30740	Y=24240	X=30740	Y=24240	X=30740	
26	PARAPET WALL & CONSTRUCTION FACILITY	Y=24240	X=30740	Y=24240	X=30740	Y=24240	X=30740	
27	MUCK DISPOSAL AREA-5	DELETED						
28	TAIL RACE CHANNEL	Y=24240	X=30740	Y=24240	X=30740	Y=24240	X=30740	
29	OVERHEAD WATER TANK	Y=24240	X=30740	Y=24240	X=30740	Y=24240	X=30740	
30	PIPS CONNECTING OVERHEAD WATER TANK AND PH	Y=24240	X=30740	Y=24240	X=30740	Y=24240	X=30740	
31	STORES	DELETED						
32	CONCRETE BOX CULVERT	Y=24240	X=30740	Y=24240	X=30740	Y=24240	X=30740	

NTPC

NTPC HYDRO LIMITED

(A wholly owned subsidiary of NTPC)

PROJECT: RAMMAM STAGE - III HYDROELECTRIC PROJECT [3X40MW]

TITLE: LAYOUT OF SURGE SHAFT, VALVE HOUSE, O/H WATER TANK, PENSTOCK, POWER HOUSE, ODY, COLONY & TRC


Drawn by	Signature	Checked By	Signature	Approved by	Signature
----------	-----------	------------	-----------	-------------	-----------

NHL Drawing Number : 5602-002-P-E-C-A-12

FORMAT : SCALE :

KPCL Drawing Number: CCED/KPCL/CONSUL/RAMMAM-MITL-12 REV 3 DEC-2011

CONSULTANT: **KARNATAKA POWER CORPORATION LIMITED**
CONSULTANCY AND ENGINEERING SERVICES DIVISION

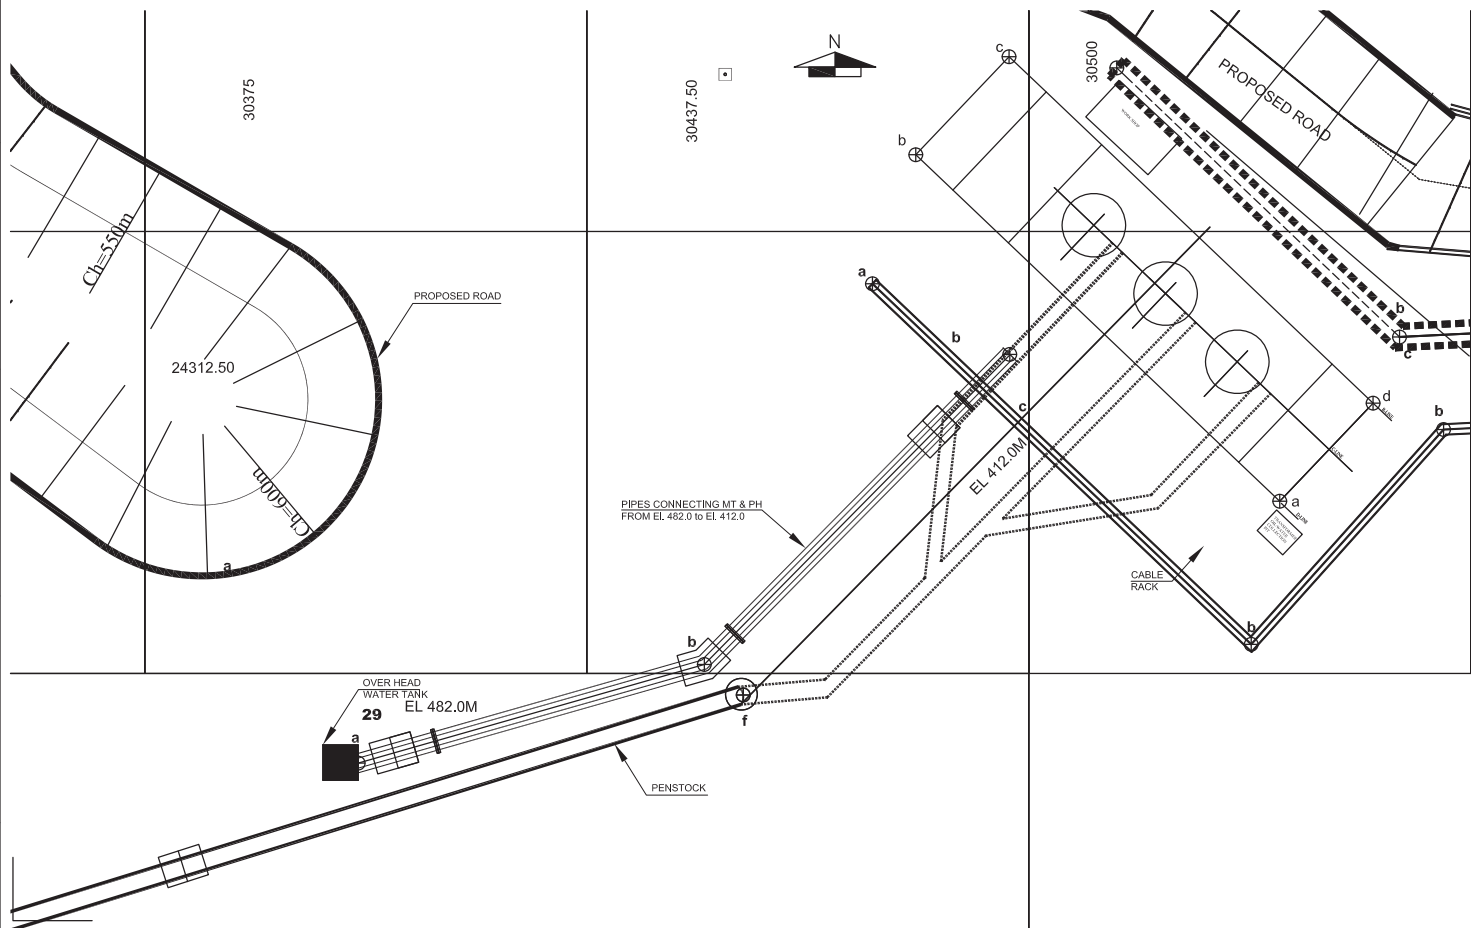

LEGEND

- EXISTING ROAD
- PROPOSED ROAD

FOR TENDER PURPOSE ONLY

		NTPC HYDRO LIMITED (A wholly owned subsidiary of NTPC)	
PROJECT		RAMMAM STAGE - III HYDROELECTRIC PROJECT [3X40MW]	
TITLE		LAYOUT OF OVERHEAD WATER TANK	
Drawn by	Signature /Date	Designed By	Signature /Date
Checked By	Signature /Date	Approved by	Signature /Date
NHL Drawing Number :		5602-002-P-E-C-A-13	
FORMAT :		SCALE :	
KPCL Drawing Number:		CCED/KPCL/CONSUL/AMMAM-III/TL-13	
CONSULTANT		REV 3 DEC-2011	
		KARNATAKA POWER CORPORATION LIMITED CONSULTANCY AND ENGINEERING SERVICES DIVISION	

This document is a property of NTPC LIMITED. No part of this document will be reproduced by any means without the written permission.

PROPOSED 132 KV SWITCH YARD

ROAD TO POWERHOUSE


NALA CROSSING

LAYOUT OF INTER CONNECTED CABLE TRENCH BETWEEN POWER HOUSE & 132 KV SWITCHYARD

NOTES:
1. ALL DIMENSIONS ARE IN MILLIMETRES AND ELEVATIONS ARE IN METRES.

FORMAT :	SCALE :
KPCL Drawing Number: CCED/KPCL/CONSUL/RAMMAM/HBEL	REV 2 DEC-2011

CONSULTANT: KARNATAKA POWER CORPORATION LIMITED
CONSULTANCY AND ENGINEERING SERVICES DIVISION

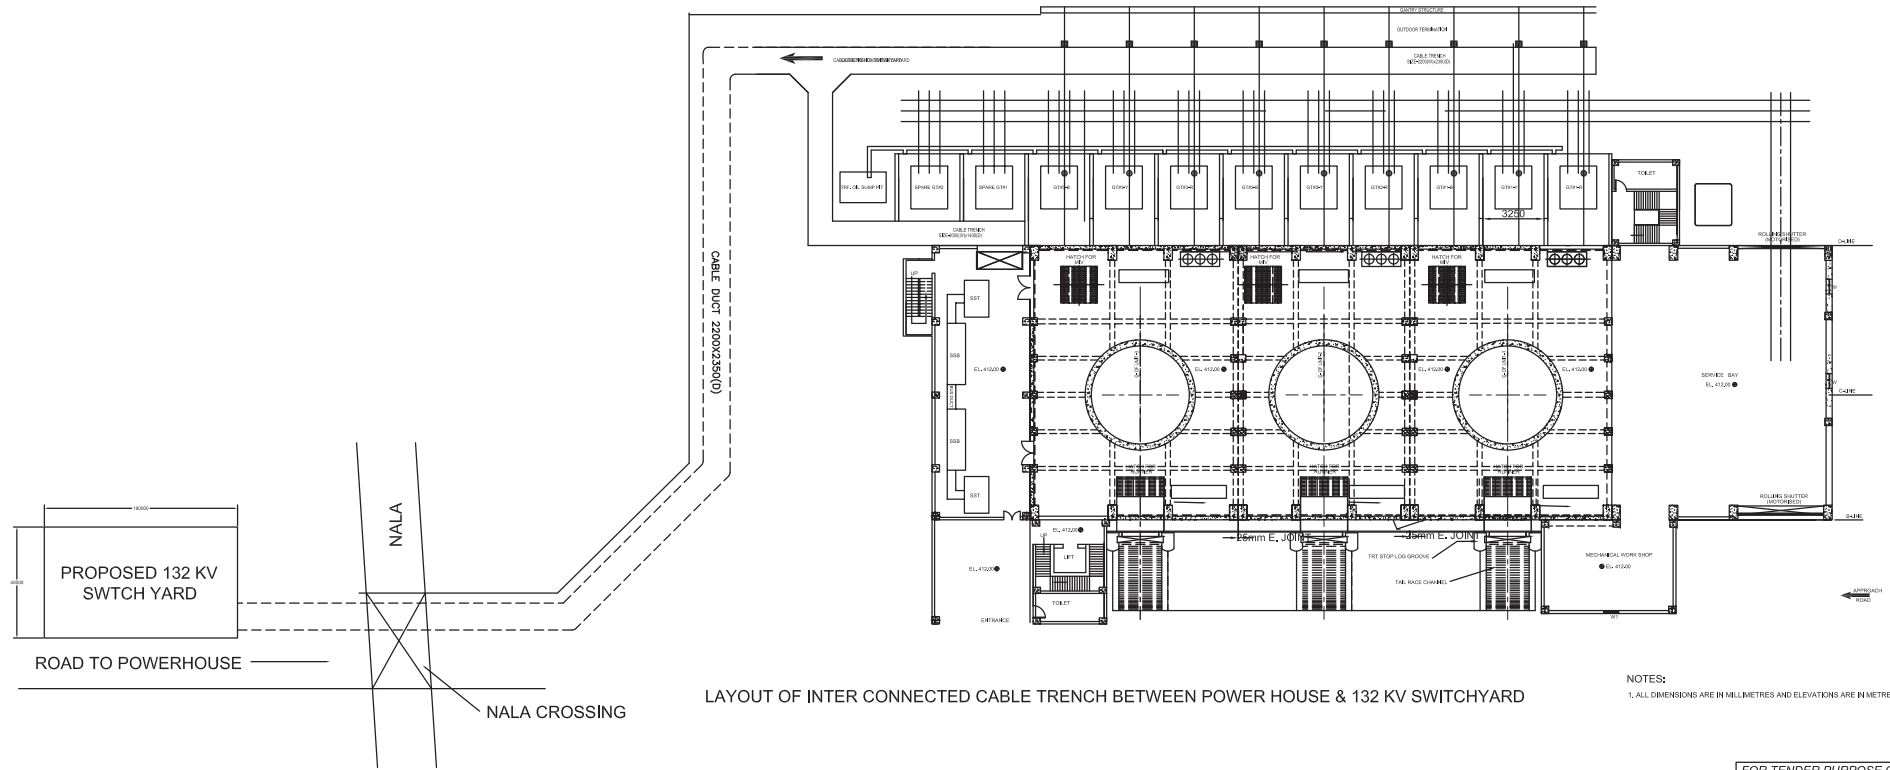


NOTES:

1. ALL DIMENSIONS ARE IN MILLIMETRES AND ELEVATIONS ARE IN METRES.

FOR TENDER PURPOSE ONLY

	NTPC HYDRO LIMITED <i>Hydroelectric Supply Division</i> (A wholly owned subsidiary of NTPC)						
PROJECT RAMMAM STAGE - II HYDROELECTRIC PROJECT [3X40MW]							
TITLE CABLE ROUTING BETWEEN POWERHOUSE & SWITCHYARD							
Drawn by	Signature /Date	Designed By	Signature /Date	Checked By	Signature /Date	Approved by	Signature /Date
NHL Drawing Number : 5002-002-P-E-E-A-127							
FORMAT :				SCALE :			
KPCL Drawing Number: CCE02KPCLCONSULRAMMAM-BEL				REV 2		DEC-2011	
CONSULTANT  KARNATAKA POWER CORPORATION LIMITED CONSULTANCY AND ENGINEERING SERVICES DIVISION							

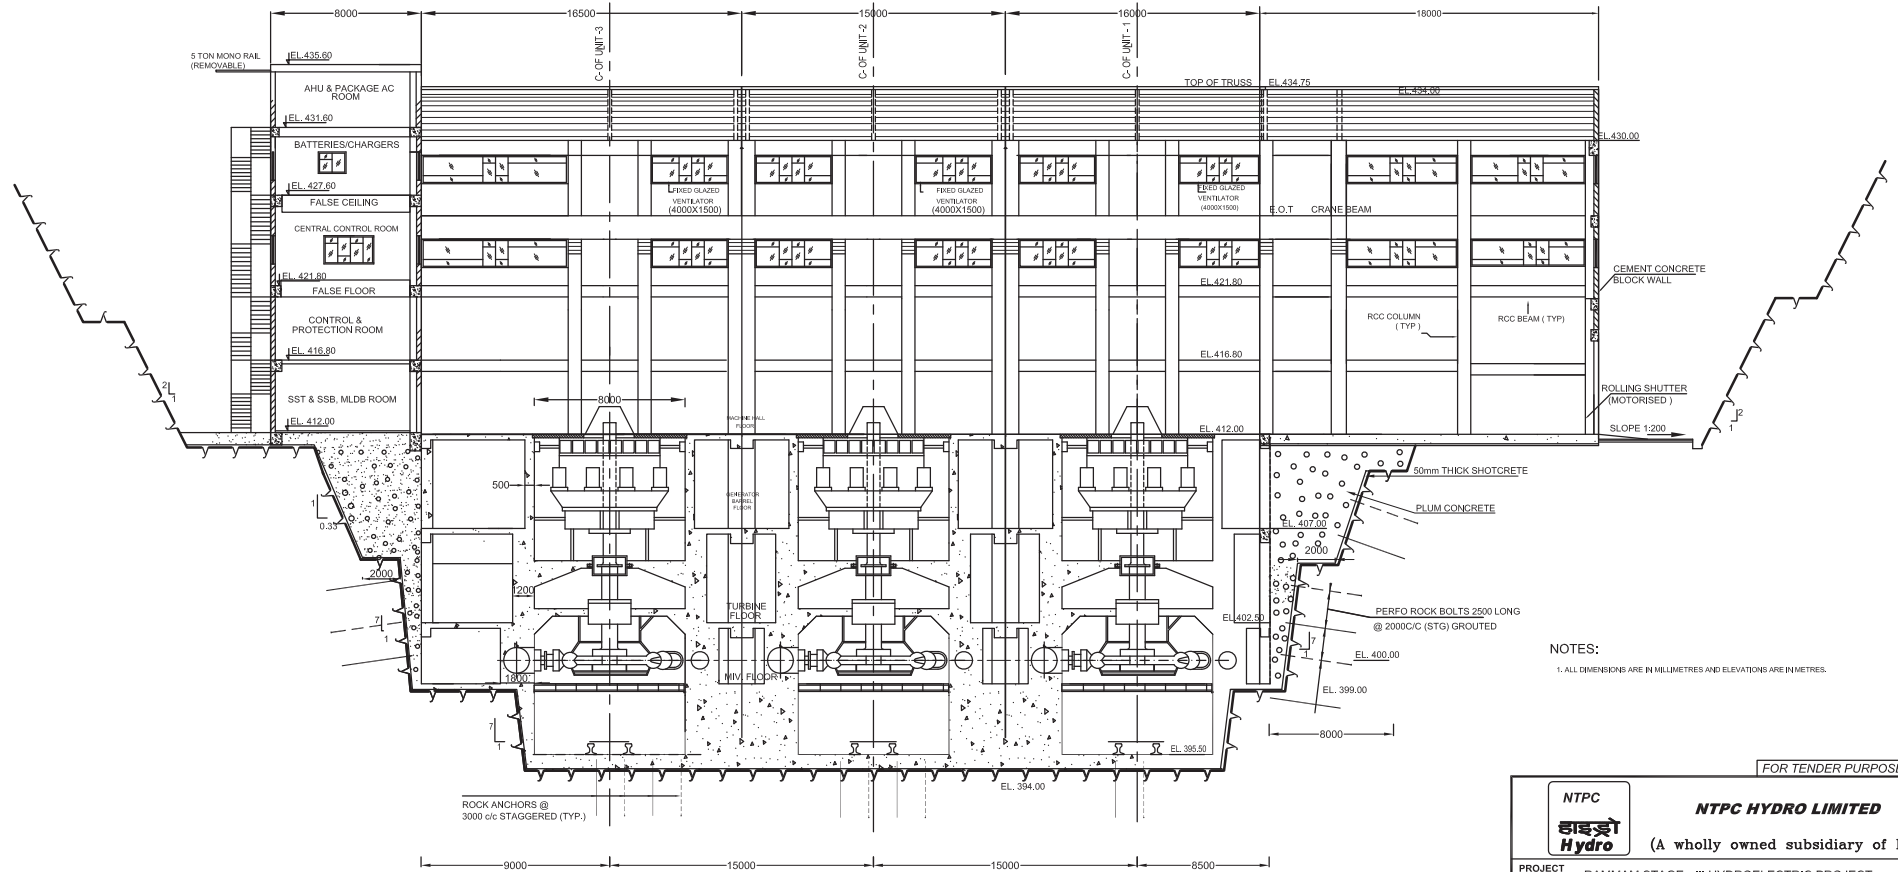


L-SECTION OF POWER HOUSE THROUGH Y-Y

NOTES:
1. ALL DIMENSIONS ARE IN MILLIMETRES AND ELEVATIONS ARE IN METRES.

FOR TENDER PURPOSE ONLY

		NTPC HYDRO LIMITED (A wholly owned subsidiary of NTPC)	
PROJECT: RAMMAM STAGE - III HYDROELECTRIC PROJECT [3x40MW]			
TITLE: L-SECTION OF POWER HOUSE			
Drawn by	Signature/Date	Designed By	Signature/Date
Checked By	Signature/Date	Approved by	Signature/Date
NHL Drawing Number : 5602-002-P-E-C-A-23			
FORMAT :		SCALE :	
KPCL Drawing Number: CCED/KPCL/CONSUL/AMMAH-BHTL-23		REV 2 DEC-2011	
CONSULTANT:		KARNATAKA POWER CORPORATION LIMITED LONGITUDINAL SECTION OF POWERHOUSE CONSULTANCY AND ENGINEERING SERVICES DIVISION	

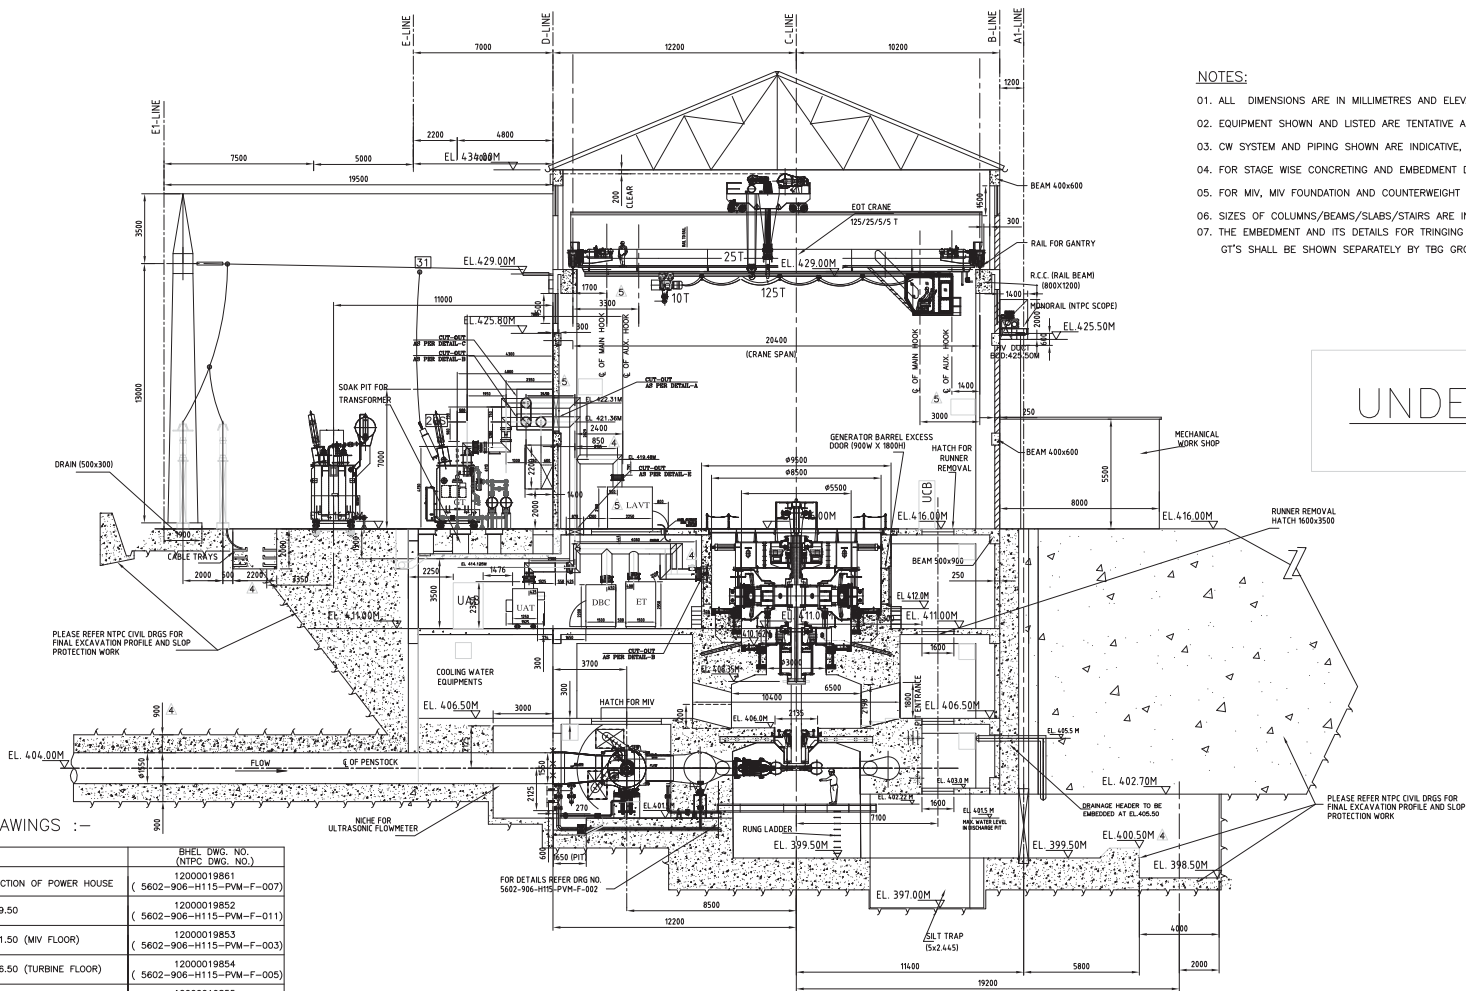

NOTES:

01. ALL DIMENSIONS ARE IN MILLIMETRES AND ELEVATIONS ARE IN METRES.
02. EQUIPMENT SHOWN AND LISTED ARE TENTATIVE AND SHALL BE FINALISED INCLUDING SIZES DURING DETAILED DESIGN.
03. CW SYSTEM AND PIPING SHOWN ARE INDICATIVE, REFER COOLING WATER AND HVAC DRAWINGS FOR COMPLETE DETAILS.
04. FOR STAGE WISE CONCRETING AND EMBEDMENT DETAILS REFER TURBINE DRAWINGS OF BHEL.
05. FOR MIV, MIV FOUNDATION AND COUNTERWEIGHT PIT DETAILS REFER TURBINE DRAWINGS OF BHEL.
06. SIZES OF COLUMNS/BEAMS/SLABS/STAIRS ARE INDICATIVE ONLY. FOR DETAILS REFER CIVIL CONSTRUCTION DRAWINGS.
07. THE EMBEDMENT AND ITS DETAILS FOR TRINGING OF THE ACSR CONDUCTOR FOR CONNECTING TAP OFF TO LA AND GT'S SHALL BE SHOWN SEPARATELY BY TBG GROUP.

UNDER REVISION-5

LINKED DRAWINGS :-

SL. No.	DESCRIPTION	BHEL DWG. NO. (NTPC DWG. NO.)
01	LONGITUDINAL SECTION OF POWER HOUSE	12000019861 (5602-906-H115-PVM-F-007)
02	PLAN AT EL. 399.50	12000019852 (5602-906-H115-PVM-F-011)
03	PLAN AT EL. 401.50 (MIV FLOOR)	12000019853 (5602-906-H115-PVM-F-003)
04	PLAN AT EL. 406.50 (TURBINE FLOOR)	12000019854 (5602-906-H115-PVM-F-005)
05	PLAN AT EL. 411.00 (GENERATOR FLOOR)	12000019855 (5602-906-H115-PVM-F-008)
06	PLAN AT EL. 416.00 (MACHINE HALL FLOOR)	12000019856 (5602-906-H115-PVM-F-009)
07	LAYOUT OF POWER HOUSE AUX. BLOCK	12000019158 (5602-906-H115-PVM-F-104)
08	FIRST STAGE PIPES AND EMBEDMENTS DRG	02010419801 (5602-906-H115-PVM-F-002)
09	CRANE CLEARANCE DIAGRAM	PE-DG-414-501-A001 (5602-003-H143-PVM-W-039)
10	GENERATOR FOUNDATION	02500087601 (5602-003-H231-PVE-V-084)
11	EMBEDMENTS & PIPES IN SECOND STAGE	02020819801 (5602-906-H115-PVM-F-004)
12	ARRGT. OF DEFLECTOR SERVOMOTOR	02160319801 (5602-906-H115-PVM-B-011)
13	GUIDE BEARING ARRANGEMENT	02060119801 (5602-906-H115-PVM-B-017)
14	SECTIONAL ARRANGEMENT	02500087617 (5602-003-H231-PVE-B-014)
15	LAYOUT OF IPB IMAIN, DELTA & TAP-OFF-RUN) FOR UNIT-A,2&3	0169141001 SHT 01

CROSS SECTION OF POWER HOUSE THROUGH WATER CONDUCTOR SYSTEM (UNIT-I)

REV.	DATE	ALTERED	TK
04	06.03.10	CHECKED	SS
03	02.08.16	CHECKED	SS
02	11.07.16	CHECKED	SS
01	28.02.16	CHECKED	SS
00		APPD.	RS
00		APPD.	RS
00		APPD.	RS
00		APPD.	RS


REVISED AS PER NTPC COMMENTS

REVISED AS PER NTPC COMMENTS & MOM DATED 02.08.16 TO 04.08.16


REVISED AS PER NTPC COMMENTS

REVISED AS PER NTPC COMMENTS


CUSTOMER:		एन टी पी सी NTPC		एन टी पी सी लिमिटेड NTPC LIMITED (A GOVERNMENT OF INDIA ENTERPRISE)	
PROJECT		RAMMAM STAGE - III HYDROELECTRIC PROJECT [3X40MW]			
BHEL		BHARAT HEAVY ELECTRICALS LTD. BHOPAL		DEPT NAME SIGN DATE NO. OF CODE DRN T.KHAN 20.09.15 VAR HPE CKD S.SAHU 20.09.15 415 APPD R.S 20.09.15 SUB-VENDOR DRG. NO. PO REF NO. OF ITEMS	
TITLE		STATION LAYOUT - ELEVATION		NTPC DRG. NO. 5602-906-H115-PVM-F-001 BHEL DRG. NO. 12000019851 SHEET NO. 01 NO. OF SHT. 01	
SUB-VENDOR NAME		WEIGHT (kg)		SCALE 1:125	

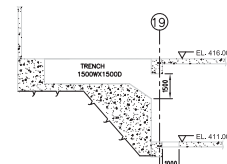


SECTION- PP

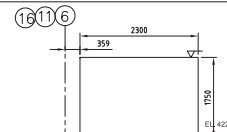


CUT-OUT DETAIL-A 4

 


CUT OUT DETAIL - B

 

CUT OUT DETAIL - C

 


CUT-OUT DETAIL-E

 

CUT OUT DETAILS

Technical drawing of a window assembly showing three views: a side elevation, a top-down view, and a cross-section. The side elevation shows a window with a width of 2700 and a height of 150. The top-down view shows a window with a width of 1500 and a height of 150. The cross-section shows a window with a width of 150 and a height of 150. The drawing is labeled 'DETAIL - A'.

DETAIL - A

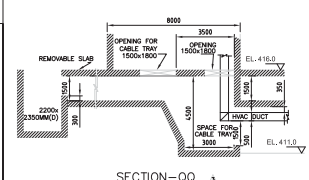

SECTION=00

01. ALL DIMENSIONS ARE IN MILLIMETRES AND ELEVATIONS ARE IN METRES.
02. CW SYSTEM AND PIPING SHOWN ARE INDICATIVE, REFER COOLING WATER AND HVAC DRAWINGS FOR COMPLETE DETAILS.
03. SIZES OF COLUMNS/BEAMS/SLABS/STAIRS ARE INDICATIVE ONLY. FOR DETAILS REFER CIVIL CONSTRUCTION DRAWINGS.
04. BUS DUCT ROUTING SHOWN IS INDICATIVE ONLY. FOR DETAILS REFER 'DELTA FORMATION OF IPBD' DRAWING.
05. POWERHOUSE FLOOR DRAIN, INTER FLOOR DRAIN AND STORM WATER DRAIN TO BE SUITABLY DESIGNED BY NTPC CIVIL.
06. DRAIN PIT 100X1000 TO BE SUITABLY DESIGNED BY NTPC CIVIL. SUITABLY SLOPE TO BE PROVIDED AS PER CIVIL PRACTICE

REFERENCE DRAWINGS :-

CW1,CW2,CW3 (750x500)	CUTOUT FOR COOLING WATER SYSTEM FOR TRANSFORMER
FF (500X500)	CUTOUT FOR FIRE FIGHTING SYSTEM
CL1,CL2,CL3 (500X500)	CUTOUT FOR CABLE TRAY
HV1,HV2,HV3,HV4	CUTOUT FOR HVAC SYSTEM
SP1,SP2 (500X500)	SPARE CUTOUT

CUSTOMER :		एन टी पी सी NTPC		स.न.टी.पी.सी. लिमिटेड									
				NTPC LIMITED									
				(A GOVERNMENT OF INDIA ENTERPRISE)									
PROJECT		RAMMAM STAGE - III HYDROELECTRIC PROJECT [3X40MW]											
भारत भारी भारत भारी		BHARAT HEAVY ELECTRICALS LTD. BHOPAL		DEPT. CODE HPE 415		NAME DRN T.KHAN CKD S.SAHU APPD R.S		SIGN 		DATE 3.3.16 3.3.16 3.3.16		NO. OF VRS.	
				SUB-VENDOR DRG. NO.		PO REF						NO. OF ITEMS	
TITLE		STATION LAYOUT PLAN AT EL.416.00 MACHINE HALL						NTPC DRG. NO. 5602-906-H115-PVM-F-009					
SUB-VENDOR NAME		WEIGHT (kg)		SCALE 1:200		BHEL DRG. NO. 12000019856						REV. 04	
						SHEET NO. 01		NO. OF SHT. 01					


REV.	DATE	ALTERED CHECKED APPD.	REV.	DATE	ALTERED CHECKED APPD.	TK SS RS	REV.	DATE	ALTERED CHECKED APPD.	TK SS RS	REV.	DATE	ALTERED CHECKED APPD.	TK SS RS	REV.	DATE	ALTERED CHECKED APPD.	TK SS RS
ZONE			ZONE	04 11.06.19			ZONE	03 22.03.18			ZONE	02 25.01.17			ZONE	01 26.08.16		
						REVISED AS PER NTPC COMMENTS												REVISED AS PER NTPC COMMENTS & MOM DATED 02.08.16 TO 04.08.16



01. ALL DIMENSIONS ARE IN MILLIMETRES AND ELEVATIONS ARE IN METRES.
02. EQUIPMENT SHOWN AND LISTED ARE TENTATIVE AND SHALL BE FINALISED INCLUDING SIZES DURING DETAILED DESIGN.
03. CW SYSTEM AND PIPING SHOWN ARE INDICATIVE, REFER COOLING WATER AND HVAC DRAWINGS FOR COMPLETE DETAILS.
04. SIZES OF COLUMNS/BEAMS/SLABS/STAIRS ARE INDICATIVE ONLY. FOR DETAILS REFER CIVIL CONSTRUCTION DRAWINGS.
05. POWERHOUSE FLOOR AND OVERHEAD DRAIN TO BE SUITABLY DESIGNED BY NTPC CIVIL.
06. CUTOFFS REQUIRED FOR INDIVIDUAL EQUIPMENTS ARE NOT SHOWN AND SHALL BE INCORPORATED LATER.
UAB SIZE HAS BEEN CONSIDERED ASSUMING DOUBLE FRONT PANEL.

SL NO.	DESCRIPTION	BHEL DWG. NO.	(NTPC DWG. NO.)
01	STATION LAYOUT – ELEVATION	12000019851	(5602–906–H115–PVM–F–001)
02	GENERATOR FOUNDATION	02500008601	(5602–003–H207–PVE–F–007)
03	LAYOUT OF COOLING WATER SYSTEM	02292019801	(5602–906–H140–PVM–F–004)
04	LAYOUT OF IPR	0169141001	5602–003–H207–PVE–F–001

S.No	DESCRIPTION	SIZE (mm)		LOCATED AT	WEIGHT (KGS)	QTY.	TOTAL QTY.	DRO. No.	REMARKS
		LENGTH	WIDTH*HEIGHT						
G01	FIELD SUPPRESSION CUBICLE	1150	1250 2295	EL 411.00	1500	1	3		EDN
G02	REGULATION CUBICLE	1951	1250 2295	EL 411.00	1000	1	3		EDN
G03	THRISTROR & TRUNKING CUBICLE	2723	1250 2995	EL 411.00	3500	1	3		EDN
G04	H.S. LUB UNIT COMPART	2000	800 800	EL 411.00	400	1	1		HGE BPL
G05	UNIT AUXILIARY BOARD	5600	1500 2300	EL 411.00	NA	1	3		HPE
G06	NG CUBICLE	2200	1600 2035	EL 411.00	NA	1	3		RFE
G07	AIR PRESSURIZATION EQUIPMENT	3500	1500 2200	EL 411.00	NA	—	2		RP
G08	MARSHALLING BOX	1500	200 1200	EL 411.00	100	1	3		HGE BPL
G09	NEEDLE CONTROL CABINET	1525	1500 2830	EL 411.00	1700	1	3		HTC BPL
G10	HMC FOR GOVERNOR	1125	800 2800	EL 411.00	1700	1	3		HTC BPL
G11	EXCITATION TRANSFORMER	3050	500 2700	EL 411.00	1000	1	3		EDN
G12	DYNAMIC BRAKING CUBICLE	2400	1500 2350	EL 411.00	2000	1	3		
G13	UNIT AUXILIARY TRANSFORMER	3300	1900 2500	EL 411.00	4800	1	3		
G14	NORMAL LIGHTING PANEL (WALL MOUNTED)	650	500 500	EL 411.00	NA	—	1		
G15	EMERGENCY LIGHTING PANEL (WALL MOUNTED)	650	500 500	EL 411.00	NA	—	1		
G16	LP COMPRESSOR	1500	1000 1100	EL 411.00	NA	—	2		HTC BPL
G17	LP AIR RECEIVER	ø1000 —	2500	EL 411.00	NA	—	2		HTC BPL
G18	AIR DRYER	750	750 1340	EL 411.00	NA	—	2		HPE GOV
G19	PRESSURE RECEIVER FOR AIR DRYER	ø350 —	1750	EL 411.00	NA	1	3		HTC BPL
G20	AUXILIARY & AUX TRANSFORMER	2476	1250 2370	EL 411.00	NA	—	3		EDN
G21	MCP FOR GENERATOR STATOR (WALL MOUNTED)	600	350 800	EL 411.00	NA	—	3		HPE BPL
G22	MCP FOR HP LUB OIL PUMP	600	350 800	EL 411.00	NA	—	1		HPE BPL

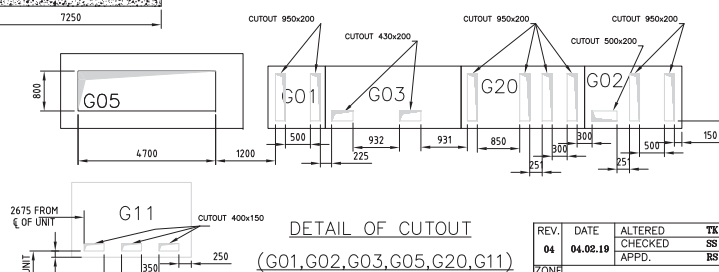

DETAIL OF CUTOUT

(G01,G02,G03,G05,G20,G11)

REV.	DATE	ALTERED	T KHAN
03	22.03.17	CHECKED	S SAHU
		APPD.	R SINGH
ZONE	REVISED AS PER NTPC COMMENTS.		

REVISD AS PER NTPC COMMENTS.

REV.	DATE	ALTERED	SS
02	18.01.17	CHECKED	RS
		APPD.	RS
ZONE	REVISED AS PER NTPC COMMENTS		

REVISED AS PER NTPC COMMENTS &
DISCUSSED IN TCM DATED 21-22 NOV'16

REV.	DATE	ALTERED	TK
04	04.02.19	CHECKED	SS
		APPD.	RS
ZONE			

UNDER REVISION

REV.	DATE	ALTERED	TK
01	26.08.16	CHECKED	SS
		APPD.	RS
ZONE	REVISED AS PER NTPC COMMENTS		

REVISED AS PER NTPC COMMENTS
& MOM DATED 02.08.16 TO 04.08.16

एन टी पी सी
NTPC

एन. टी. पी. सी. लिमिटेड
NTPC LIMITED
(A GOVERNMENT OF INDIA ENTERPRISE)

RAMMAM STAGE - III HYDROELECTRIC PROJECT [3X40MW]



	SUB-VENDOR NAME

WEIGH

SCALE 1:100



DEPT. CODE	NAME	SIGN	DATE	NO. OF VAR
HPE	DRN T.KHAN		-	
415	CKD S.SAHU		-	
	APPD R.S		-	
SUB-VENDOR DRG. NO.			PO REF	NO. OF ITEMS

NTPC DRG. NO.		
5602-906-H115-PVM-F-008		

0	BHEL DRG. NO.	RE
	13000010855	0

12000019833		04
SHEET NO.	01	NO. OF SHT. 01

#98610000Z1 ON 'DMD'

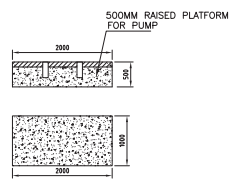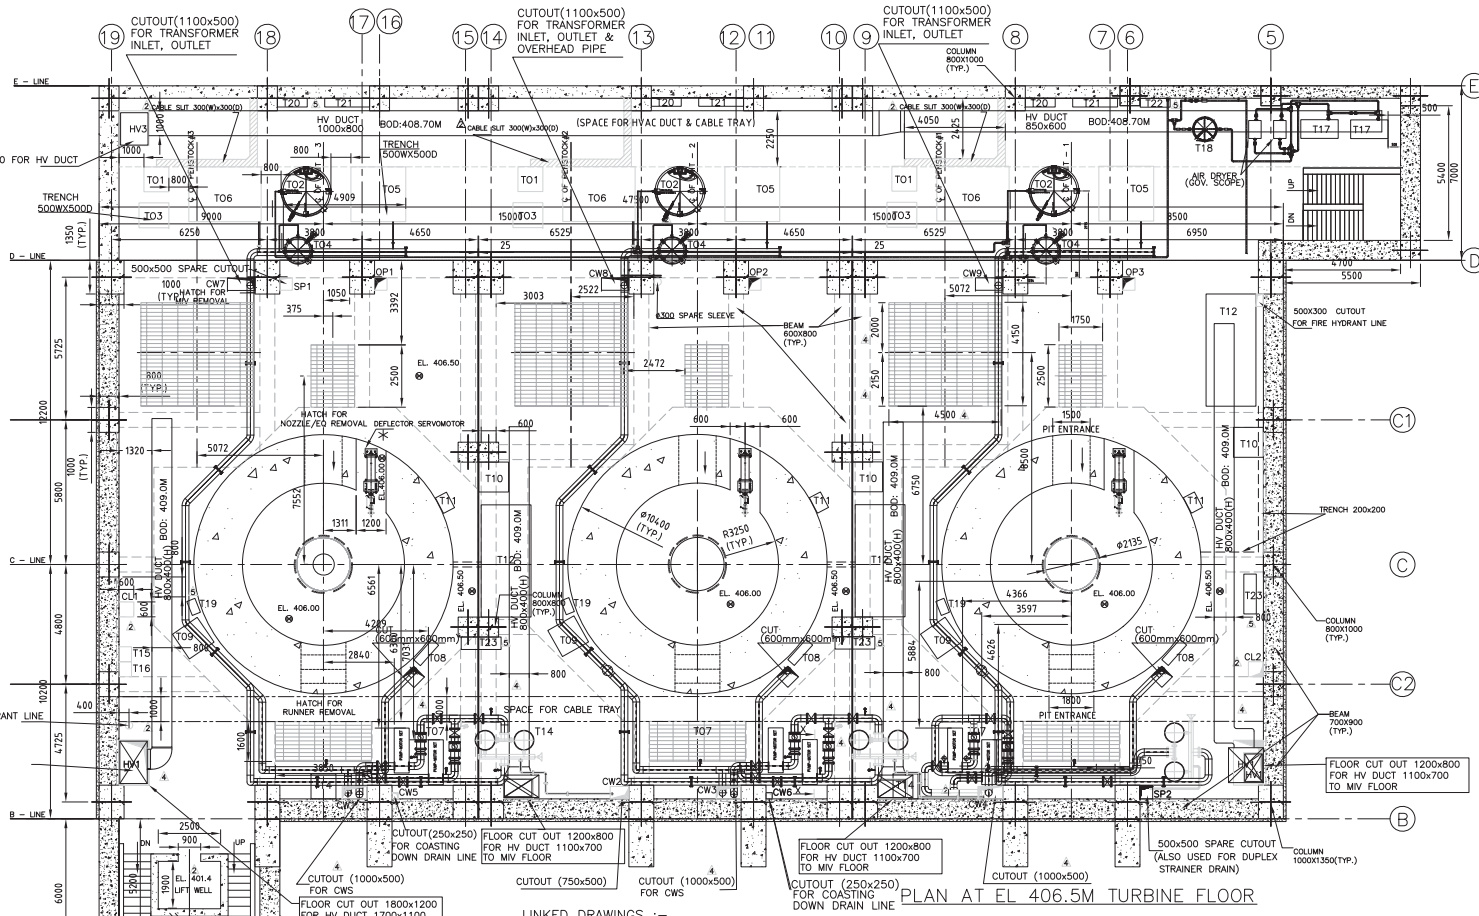SECTION-XX
(RAISED PLATFORM FOR SECONDARY PUMPS)

LIST OF EQUIPMENTS

S.No	DESCRIPTION	SIZE (mm)	LOCATED AT	WEIGHT (Kg)	QTY.	TOTAL QTY.	DRG. No.	REMARKS
T01	ELECTRICAL CONTROL & INDICATION PANEL FOR MIV	1000x1000x2400	EL.406.5	400	1	3	HPE GOV	
T02	PRESSURE RECEIVER FOR MIV	2000x3200	EL.406.5	4500	1	3	HPE GOV	
T03	HYDRAULIC CONTROL PANEL FOR MIV	1200x1000x2500	EL.406.5	1000	1	3	HPE GOV	
T04	PRESSURE RECEIVER FOR GOVERNOR	11200x3000	EL.406.5	3500	1	3	HPE GOV	
T05	PP SET FOR TURBINE/ GOVERNOR	2200x2200x2300	EL.406.5	3200	1	3	HPE GOV	
T06	PP SET FOR MIV	2900x2200x2325	EL.406.5	4500	1	3	HPE GOV	
T07	SEC COOLING WATER PUMPS	2100x800x1000	EL.406.5	2500	2	6	HTE BPL	
T08	BRAKE JACK CONTROL PANEL	1100x350x1200	EL.406.5	350	1	3	HGE BPL	
T09	BRAKE DUST COLLECTOR	1200x1200x2500	EL.406.5	500	1	3	HGE BPL	
T10	MOTORISED POWER PACK (PORTABLE)	1200x1200x1800	EL.406.5	300	1	3	HGE BPL	
T11	CO2 FIRE FIGHTING SYSTEM PANEL	500x700x2300	EL.406.5	1000	1	3	HGE BPL	
T12	CO2 CYLINDER BANK	4500x2000x2500	EL.406.5	-	-	3	HGE BPL	
T13	HEAT EXCHANGER	1500x750x1500	EL.406.5	-	-	3	HTE BPL	
T14	DUPLEX STRAINER	1500x2500x2500	EL.406.5	-	-	3	HTE BPL	
T15	NORMAL LIGHTING PANEL (WALL MOUNTED)	650x500x500	EL.406.5	NA	-	1	PEM BHEL	
T16	EMERGENCY LIGHTING PANEL (WALL MOUNTED)	650x500x500	EL.406.5	NA	-	1	PEM BHEL	
T17	HP COMPRESSOR	1500x750x2000	EL.406.5	-	-	2	HTE BPL	
T18	HP RECEIVER	1500x750x2000	EL.406.5	-	-	1	HTE BPL	
T19	MCP FOR BRAKE DUST COLLECTOR (WALL MOUNTED)	600x350x800	EL.406.5	-	-	3	HPE BPL	
T20	MCP FOR MIV CPU (WALL MOUNTED)	1200x350x1200	EL.406.5	-	-	3	HPE BPL	
T21	MCP FOR TURBINE OPU (WALL MOUNTED)	1800x350x1000	EL.406.5	-	-	3	HPE BPL	
T22	MCP FOR THE COMPRESSOR (WALL MOUNTED)	1200x350x1000	EL.406.5	-	-	1	HPE BPL	
T23	MCP FOR SECONDARY COOLING PUMP	2x800x500x2400	EL.406.5	-	-	3	HPE BPL	

LINKED DRAWINGS :-

SL. No.	DESCRIPTION	BHEL DWG. NO.	(NTPC DWG. NO.)
01	STATION LAYOUT - ELEVATION	12000019851	(5602-906-H115-PVM-F-001)
02	EMBEDMENTS & PIPES IN SECOND STAGE	02020819801	(5602-906-H115-PVM-F-004)
03	LAYOUT OF COOLING WATER SYSTEM	02292019801	(5602-406-H140-PVM-F-004)
04	ARRANGEMENT OF DEFLECTOR MECHANISM	02030719801	(5602-906-H115-PVM-B-010)
05	OIL PIPE LINES	0 21018 19801	(5602-906-H115-PVM-B-023)

NOTES:

- ALL DIMENSIONS ARE IN MILLIMETRES AND ELEVATIONS ARE IN METRES.
- CW SYSTEM AND PIPING SHOWN ARE INDICATIVE, REFER COOLING WATER AND HVAC DRAWINGS FOR COMPLETE DETAILS.
- SIZES OF COLUMNS/BEAMS/SLABS/STAIRS ARE INDICATIVE ONLY. FOR DETAILS REFER CIVIL CONSTRUCTION DRAWINGS.
- POWERHOUSE FLOOR AND OVERALL DRAIN TO BE SUITABLY DESIGNED BY NTPC CIVIL.
- FOR ARRGT. OF DEFLECTOR SERVOMOTOR PLEASE REFER DRG NO. 02160319801 (NTPC DRG. NO. 5602-906-H115-PVM-B-011)
- BHEL SHALL PROVIDE GRATING & CHEQUERED PLATE FOR OPENING/TRENCHES. SINGLE/DOUBLE EDGE PROTECTION WHEREVER REQUIRED SHALL BE PROVIDED BY NTPC CIVIL.

REV.	DATE	ALTERED	TK
03	25.01.17	CHECKED	SS
		APPD.	RS

REVISED AS PER NTPC COMMENTS

REV.	DATE	ALTERED	SS
02	28.11.16	CHECKED	RS
		APPD.	RS

REVISED AS PER NTPC COMMENTS & DISCUSSED IN TCM DATED 21-22 NOV'16

REV.	DATE	ALTERED	TK
04	18.03.19	CHECKED	SS
		APPD.	RS

ZONE A

REVISED AS PER LATEST CWS DRAWING

REVISED AS PER NTPC COMMENTS

REVISED AS PER NTPC COMMENTS & MOM DATED 02.06.16 TO 04.06.16

4	CW1 (1000x500)	- SECONDARY WATER INLET TO SECONDARY PUMP AND DUPLEX STRAINER INLET - SECONDARY WATER FOR GENERATOR (FOR UNIT-1)
4	CW2 (750x500)	- RETURN LINE OF DUPLEX STRAINER & FOR OVERHEAD TANK
4	CW3 (1000x500)	- SECONDARY WATER INLET TO SECONDARY PUMP AND DUPLEX STRAINER INLET - SECONDARY WATER FOR GENERATOR (FOR UNIT-2)
4	CW4 (1000x500)	- SECONDARY WATER INLET TO SECONDARY PUMP AND DUPLEX STRAINER INLET - SECONDARY WATER FOR GENERATOR (FOR UNIT-3)
	CL1, CL2 (600x600)	CUTOUT FOR CABLE TRAY
	HV1, HV2 (1800x1200)	CUTOUT FOR HVAC SYSTEM
	SP1, SP2 (500x500)	SPARE CUTOUT & FOR DUPLEX STRAINER DRAIN (SP2)
	CW5, CW6 (250x250)	CUTOUT FOR COASTING DOWN DRAIN LINE
	OP1, OP2, OP3 (500x500)	CUTOUT FOR OIL PIPE LINE
4	CW7, CW8, CW9 (1100x500)	CUTOUT FOR OIL PIPE LINE

CUSTOMER:

एन टी पी सी
NTPCएन.टी.पी.सी. लिमिटेड
NTPC LIMITED
(A GOVERNMENT OF INDIA ENTERPRISE)

PROJECT

RAMMAM STAGE - III HYDROELECTRIC PROJECT (3X40MW)

BHARAT HEAVY ELECTRICALS LTD.
BHOPAL

TITLE

STATION LAYOUT PLAN AT EL.406.5M TURBINE FLOOR

SUB-VENDOR NAME

WEIGHT (kg)

SCALE 1:100

DEPT	NAME	SIGN	DATE	NO. OF VAR
CODE	DRN T.KHAN		20.09.15	
HPE	CKD S.SAHU		20.09.15	
415	APPD R.S		20.09.15	

SUB-VENDOR DRG. NO.

PO REF

NO. OF ITEMS

NTPC DRG. NO.

5602-906-H115-PVM-F-005

BHEL DRG. NO.


12000019854

SHEET NO. 01 NO. OF SHT. 01

REV.

A1 SIZE

CS8610000Z1 ON 'DWG'

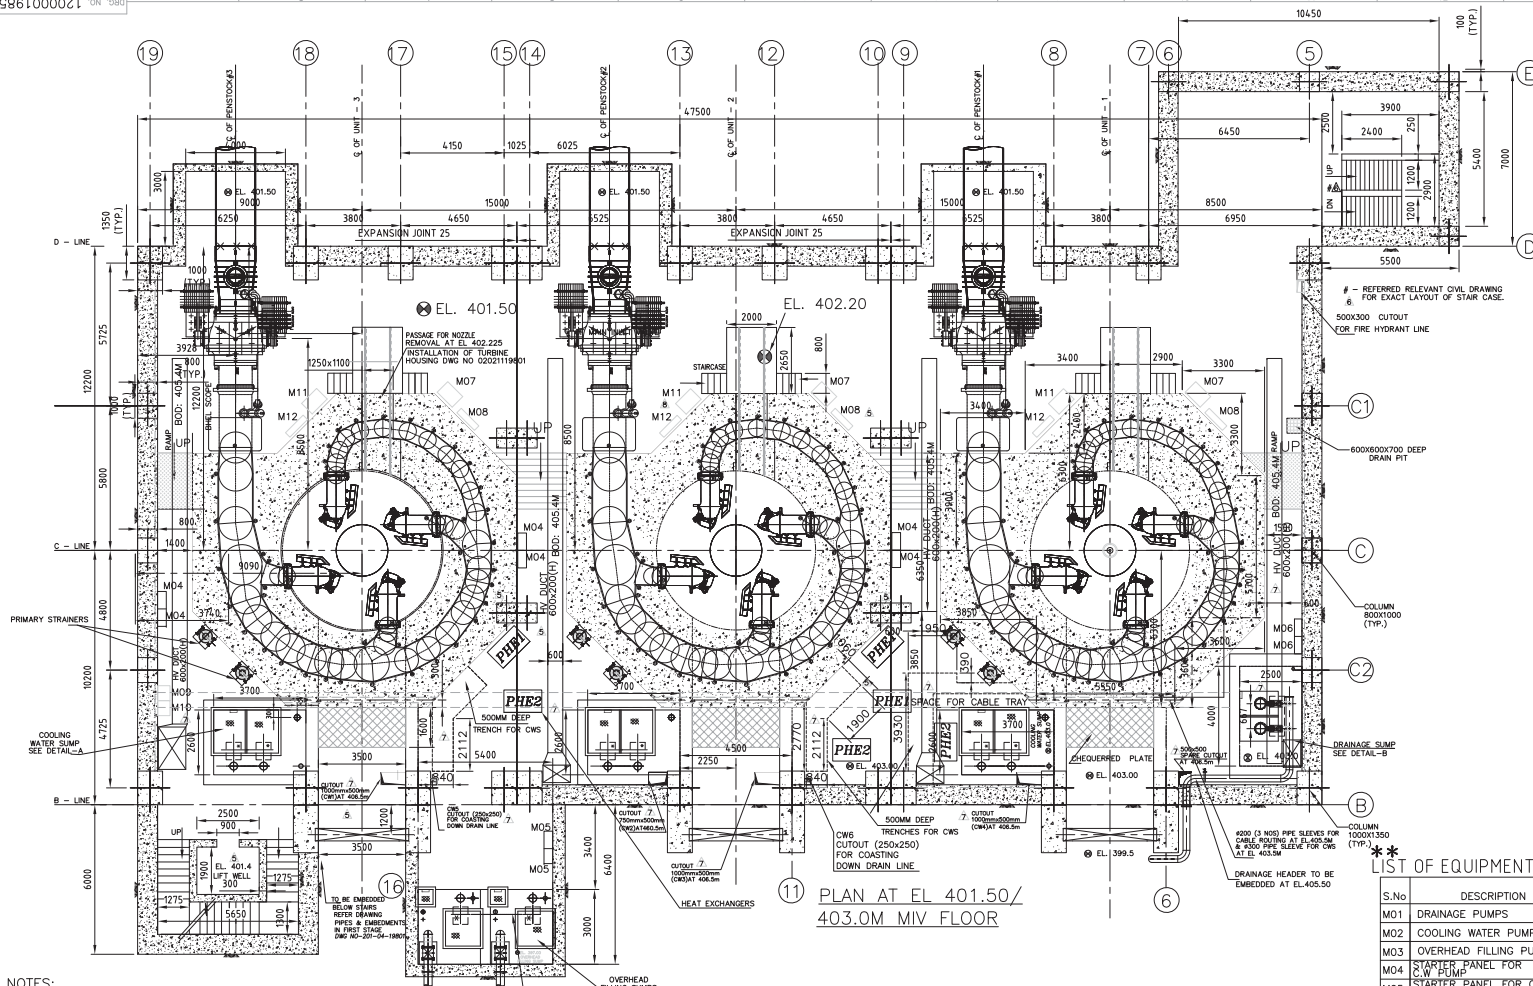PLAN AT EL. 401.50/
403.0M MIV FLOOR

NOTES:

- ALL DIMENSIONS ARE IN MILLIMETRES AND ELEVATIONS ARE IN METRES.
- EQUIPMENT SHOWN AND LISTED ARE TENTATIVE AND SHALL BE FINALISED INCLUDING SIZES DURING DETAILED DESIGN.
- REFER COOLING WATER AND HVAC DRAWINGS FOR COMPLETE DETAILS.
- FOR STAGE WISE CONCRETING AND EMBEDMENT DETAILS REFER TURBINE DRAWINGS OF BHEL.
- FOR MIV, MIV FOUNDATION AND COUNTERWEIGHT PIT DETAILS REFER TURBINE DRAWINGS OF BHEL.
- SIZES OF COLUMNS/BEAMS/SLABS/STAIRS ARE INDICATIVE ONLY. FOR DETAILS REFER CIVIL CONSTRUCTION DRAWINGS.
- ** SHALL BE SHOWN AFTER FINALIZATION OF CW DRG "LAYOUT OF COOLING WATER SYSTEM" (5602-406-H140-PVM-F-004).
- THIS DRAWING IS INTENDED FOR SHOWING LAYOUT & CIVIL REQUIREMENTS OF FLOOR ONLY. FOR CIVIL DETAILS/EMBEDMENTS INSIDE BARREL/HOUSING RESPECTIVE SYSTEM DRAWING AS GIVEN IN TABLE OF REFERENCE DRAWING TO BE FOLLOWED.
- POWERHOUSE FLOOR AND OVERHEAD DRAIN TO BE SUITABLY DESIGNED BY NTPC CIVIL.

LINKED DRAWINGS :-

SL. No.	DESCRIPTION	BHEL DWG. NO.	(NTPC DWG. NO.)
01	STATION LAYOUT - ELEVATION	12000019851	(5602-906-H115-PVM-F-001)
02	PLAN AT EL. 399.50	12000019852	(5602-906-H115-PVM-F-011)
03	FIRST STAGE PIPES AND EMBEDMENTS DRG.	02010419801	(5602-906-H115-PVM-F-002)
04	EMBEDMENTS & PIPES IN SECOND STAGE	02020819801	(5602-906-H115-PVM-F-004)
05	POWER HOUSE DRAINAGE AND DEWATERING SUMP CONCRETE	(5602-305(R2)-POC-C-135)	
06	LAYOUT OF COOLING WATER SYSTEM	02292019801	(5602-406-H140-PVM-F-004)

REV.	DATE	ALTERED	TK	SS	REV.	DATE	ALTERED	TK	SS	REV.	DATE	ALTERED	TK	SS
06	08.11.16	CHECKED	SS	APPD.	05	10.09.16	CHECKED	SS	APPD.	04	02.06.16	CHECKED	SS	APPD.
ZONE	REVISED AS PER NTPC COMMENTS				ZONE	REVISED AS PER NTPC COMMENTS				ZONE	REVISED AS PER NTPC COMMENTS & MOM DATED 02.06.16 TO 04.06.16			

REV.	DATE	ALTERED	TK	SS
03	18.06.16	CHECKED	SS	APPD.
ZONE	REVISED AS PER NTPC COMMENTS			

REV.	DATE	ALTERED	TK	SS
02		CHECKED	SS	APPD.
ZONE	REVISED AS PER NTPC COMMENTS			

REV.	DATE	ALTERED	TK	SS
07	06.03.19	CHECKED	SS	APPD.
ZONE	REVISED AS PER LATEST CWS DRAWING			

REV.	DATE	ALTERED	TK	SS
01	28.02.16	CHECKED	SS	APPD.
ZONE	REVISED AS PER NTPC COMMENTS			

LIST OF EQUIPMENTS (TENTATIVE) NA - NOT AVAILABLE

S.No.	DESCRIPTION	SIZE (mm)	LOCATED AT	WEIGHT (KgS.)	QTY./TOTAL QTY.	DRG. No.	REMARKS
M01	DRAINAGE PUMPS	-	EL. 396.0	NA	2(1M+1S)		HPE BPL
M02	COOLING WATER PUMPS	-	EL. 397.0	NA	2	6(3M+3S)	HTE BPL
M03	OVERHEAD FILLING PUMPS	-	EL. 397.0	NA	2(1M+1S)		HTE BPL
M04	STARTER PANEL FOR 2XW PUMP	2X700	EL. 403.0	NA	2	6	HPE BPL
M05	STARTER PANEL FOR OVER HEAD TANK FILLING PUMP	2X700	EL. 403.0	NA	2		HPE BPL
M06	DRAINAGE PUMP	2X600	EL. 403.0	NA	2		HPE BPL
M07	OIL LEAKAGE UNIT FOR MIV	850	EL. 403.0	NA	1	3	HPE BPL
M08	MCP FOR OIL LEAKAGE UNIT FOR MIV (WALL MOUNTED)	1000	EL. 403.0	NA	1	3	HPE BPL
M09	NORMAL LIGHTING PANEL (WALL MOUNTED)	650	EL. 403.0	NA	1		
M10	EMERGENCY LIGHTING PANEL (WALL MOUNTED)	650	EL. 403.0	NA	1		
M11	OIL LEAKAGE UNIT FOR TURBINE	850	EL. 403.0	NA	1	3	HPE BPL
M12	MCP FOR OIL LEAKAGE UNIT FOR TURBINE (WALL MOUNTED)	1000	EL. 403.0	NA	1	3	HPE BPL

CUSTOMER:

एन टी पी सी
NTPCएन.टी.पी.सी. लिमिटेड
NTPC LIMITED
(A GOVERNMENT OF INDIA ENTERPRISE)

PROJECT

RAMMAM STAGE - III HYDROELECTRIC PROJECT [3X40MW]

BHARAT HEAVY ELECTRICALS LTD.
BHOPAL

TITLE

STATION LAYOUT PLAN AT EL.401.50/403.00M

DEPT.	NAME	SIGN.	DATE	NO. OF VAR.
CODE	DRN. T.KHAN		20.09.15	
HPE	[CKD] S.SAHU		20.09.15	
415	[APPD] R.S.		20.09.15	

NTPC DRG. NO.
5602-906-H115-PVM-F-003

SUB-VENDOR NAME

WEIGHT
(kg)


SCALE 1:100

BHEL DRG. NO.
12000019853


SHEET NO. 01 NO. OF SHT. 01

A1 SIZE


2561000019852

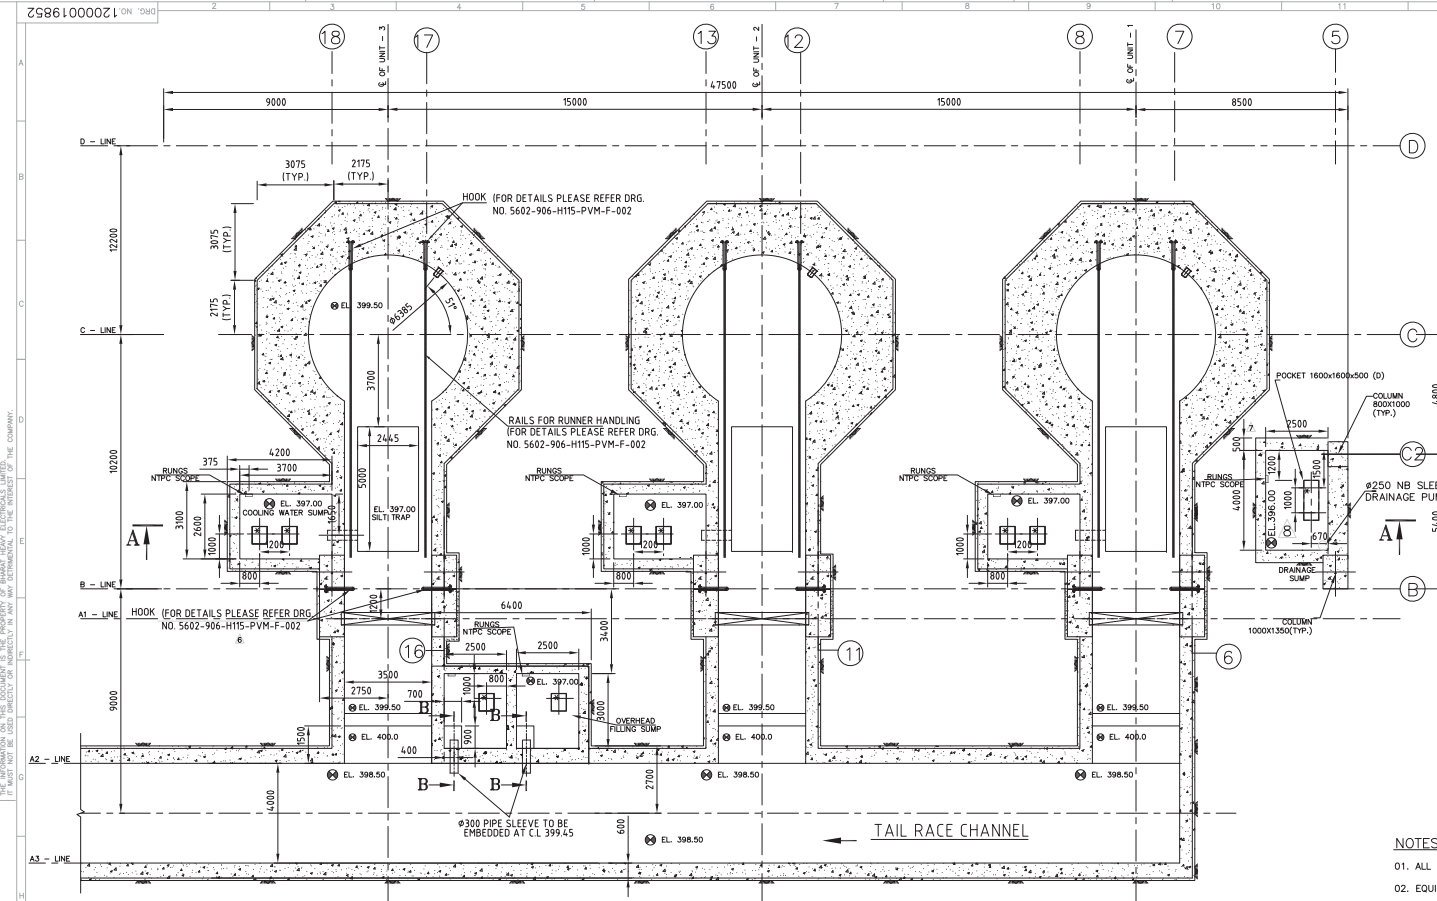

PLAN AT EL 399.50

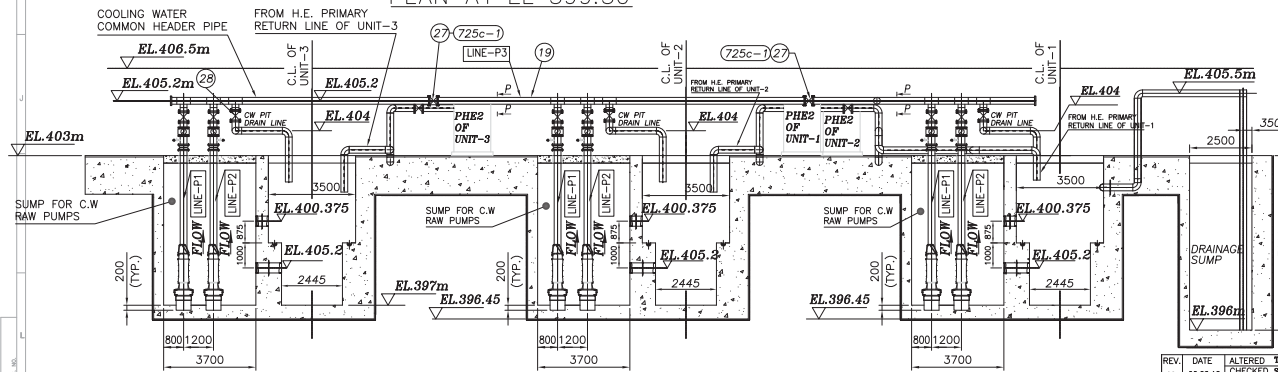

SECTION-AA

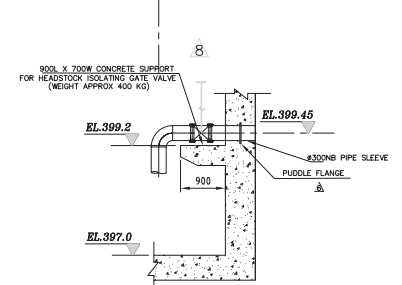

SECTION-BB

REFERENCE DRAWINGS

SL. No.	DESCRIPTION	BHEL DWG. NO. (NTPC DWG. NO.)
01	FIRST STAGE PIPES AND EMBEDMENTS DRG.	02010419801 (5602-906-H115-PVM-F-002)
02	DRAINAGE SYSTEM	12110119853 (5602-003-H171-PVM-F-003)
03	POWER HOUSE DRAINAGE AND DEWATERING SUMP CONCRETE	(5602-305(R2)-POC-C-135)
04	INSTALLATION OF LOWER PIT LINER	-
05	COOLING WATER SYSTEM	0-229-20-19801 (5602-906-H140-PVM-F-004)

* 200MM DEEP POCKET TO BE LEFT AND DOWELS TO BE LEFT PROTRUDING FOR MAKING FOUNDATION OF PUMPS DURING SECONDARY CONCRETING



NOTES:

- ALL DIMENSIONS ARE IN MILLIMETRES AND ELEVATIONS ARE IN METRES.
- EQUIPMENT SHOWN AND LISTED ARE TENTATIVE AND SHALL BE FINALISED DURING DETAILED DESIGN.
- CW SYSTEM AND PIPING SHOWN ARE INDICATIVE, REFER COOLING WATER AND HVAC DRAWINGS FOR COMPLETE DETAILS.
- FOR STAGE WISE CONCRETING AND EMBEDMENT DETAILS REFER TURBINE DRAWINGS OF BHEL.
- FOR MV, MV FOUNDATION AND COUNTERWEIGHT PIT DETAILS REFER TURBINE DRAWINGS OF BHEL.
- SIZES OF COLUMNS/BEAMS/SLABS/STAIRS ARE INDICATIVE ONLY. FOR DETAILS REFER CIVIL CONSTRUCTION DRAWINGS.
- THIS DRAWING IS INTENDED FOR SHOWING LAYOUT & CIVIL REQUIREMENTS OF FLOOR ONLY. FOR CIVIL DETAILS/EMBEDMENTS INSIDE BARREL/HOUSING RESPECTIVE SYSTEM DRAWING AS GIVEN IN TABLE OF REFERENCE DRAWING TO BE FOLLOWED.
- POWERHOUSE FLOOR AND OVERALL DRAIN TO BE SUITABLY DESIGNED BY NTPC CIVIL.
- REFER RELEVANT HM DRAWING FOR DETAIL OF DRAFT TUBE GATE EMBEDMENT.
- REFER SEPARATE RELEVANT DRAWING FOR FOUNDATION DETAILS.
- FOR EMBEDMENT OF LOWER PIT REFER RESPECTIVE DRAWING OF LOWER PIT LINER

CUSTOMER:

एन टी पी सी
NTPCएन टी पी सी लिमिटेड
NTPC LIMITED
(A GOVERNMENT OF INDIA ENTERPRISE)

PROJECT

RAMMAM STAGE - III HYDROELECTRIC PROJECT [3X40MW]

BHARAT HEAVY ELECTRICALS LTD.
BHOPAL

DEPT	NAME	SIGN	DATE	NO. OF
CODE	DRN T.KHAN		20.09.15	VAR
HPE	CKD S.SAHU		20.09.15	
415	APPR.R.S		20.09.15	
SUB-VENDOR DRG. NO.			PO REF	NO. OF
				ITEMS

TITLE

STATION LAYOUT PLAN AT EL.399.50M

SUB-VENDOR NAME

WEIGHT
(kg)

SCALE 1:100

NTPC DRG. NO.
5602-906-H115-PVM-F-011BHEL DRG. NO.
12000019852


SHEET NO. 01 NO. OF SH. 08

REV.	DATE	ALTERED	TK	REV.	DATE	ALTERED	TK	REV.	DATE	ALTERED	TK	REV.	DATE	ALTERED	TK
06	10.09.16	CHECKED	SS	05	02.08.16	CHECKED	SS	04	18.06.16	ALTERED	SS	03	18.06.16	CHECKED	SS
ZONE REVISAS PER NTPC COMMENTS				ZONE REVISAS PER NTPC COMMENTS				ZONE REVISAS PER NTPC COMMENTS				ZONE REVISAS PER NTPC COMMENTS			
REVISAS PER NTPC COMMENTS				REVISAS PER NTPC COMMENTS				REVISAS PER NTPC COMMENTS				REVISAS PER NTPC COMMENTS			


FIRST ANGLE PROJECTION

(ALL DIMENSIONS ARE IN mm)

DRG. NO. 12000019857

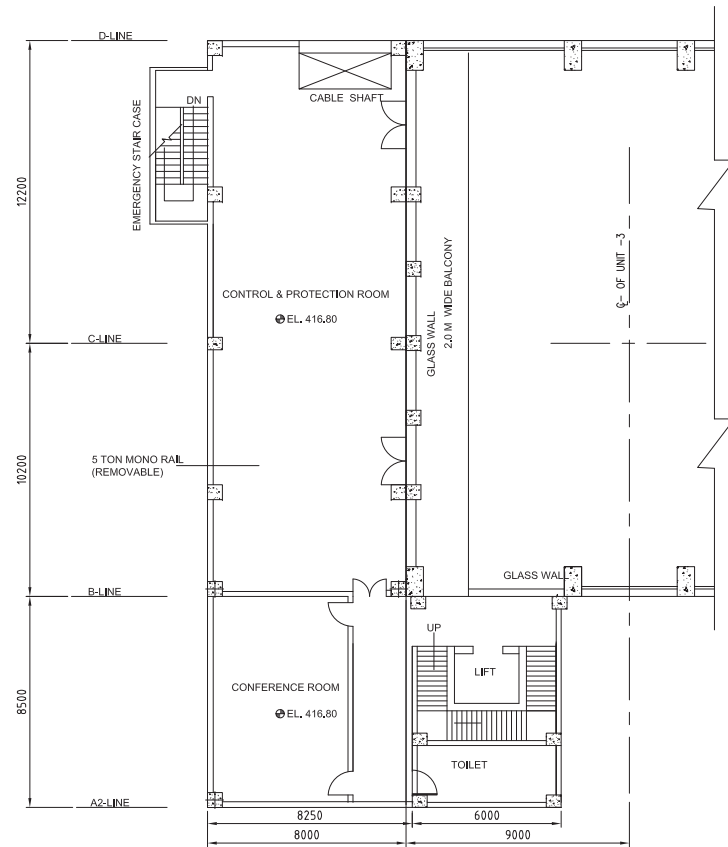

AUXILIARY FLOOR
PLAN AT EL. 416.80

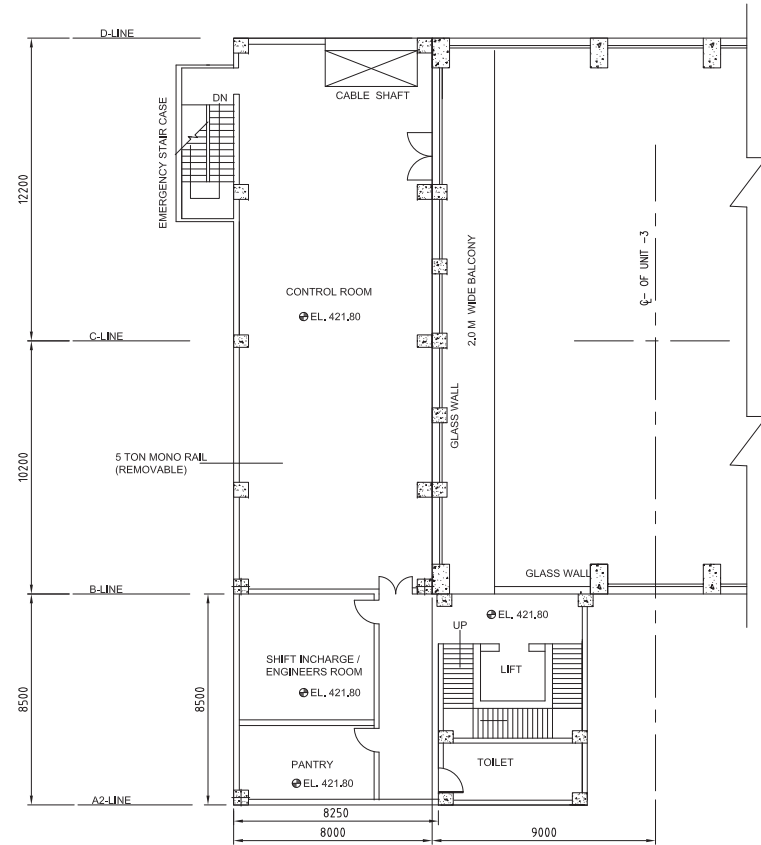


AUXILIARY FLOOR
PLAN AT EL. 421.80

CUSTOMER:		एन टी सी NTPC		एन.टी.पी.सी. लिमिटेड NTPC LIMITED (A GOVERNMENT OF INDIA ENTERPRISE)																															
PROJECT		RAMMAM STAGE - III HYDROELECTRIC PROJECT [3X40MW]																																	
		BHARAT HEAVY ELECTRICALS LTD. BHOPAL		<table border="1"><tr><td>DEPT.</td><td>NAME</td><td>SIGN</td><td>DATE</td><td>NO. OF</td></tr><tr><td>DRN</td><td>T.KHAN</td><td></td><td>12.06.18</td><td>VAR</td></tr><tr><td>HPE</td><td>CKD S.SAHU</td><td></td><td>12.06.18</td><td></td></tr><tr><td>415</td><td>APPD.R.SINGH</td><td></td><td>12.06.18</td><td></td></tr><tr><td colspan="3">SUB-VENDOR DRG. NO.</td><td>PO REF</td><td>NO. OF</td></tr><tr><td colspan="3"></td><td></td><td>ITEMS</td></tr></table>		DEPT.	NAME	SIGN	DATE	NO. OF	DRN	T.KHAN		12.06.18	VAR	HPE	CKD S.SAHU		12.06.18		415	APPD.R.SINGH		12.06.18		SUB-VENDOR DRG. NO.			PO REF	NO. OF					ITEMS
DEPT.	NAME	SIGN	DATE	NO. OF																															
DRN	T.KHAN		12.06.18	VAR																															
HPE	CKD S.SAHU		12.06.18																																
415	APPD.R.SINGH		12.06.18																																
SUB-VENDOR DRG. NO.			PO REF	NO. OF																															
				ITEMS																															
TITLE		LAYOUT OF POWER HOUSE AUX. BLOCK AT EL. 416.80 & 421.80																																	
SUB-VENDOR NAME		WEIGHT (kg)		SCALE 1:100																															
				BHEL DRG. NO. 5602-906-H115-PVM-F-102																															
				REV. 00																															
				SHEET NO. 01 NO. OF SHT. 01																															


A1 SIZE

1	2	3	466
---	---	---	---	---	---	---	---	---	----	----	-----	-----	
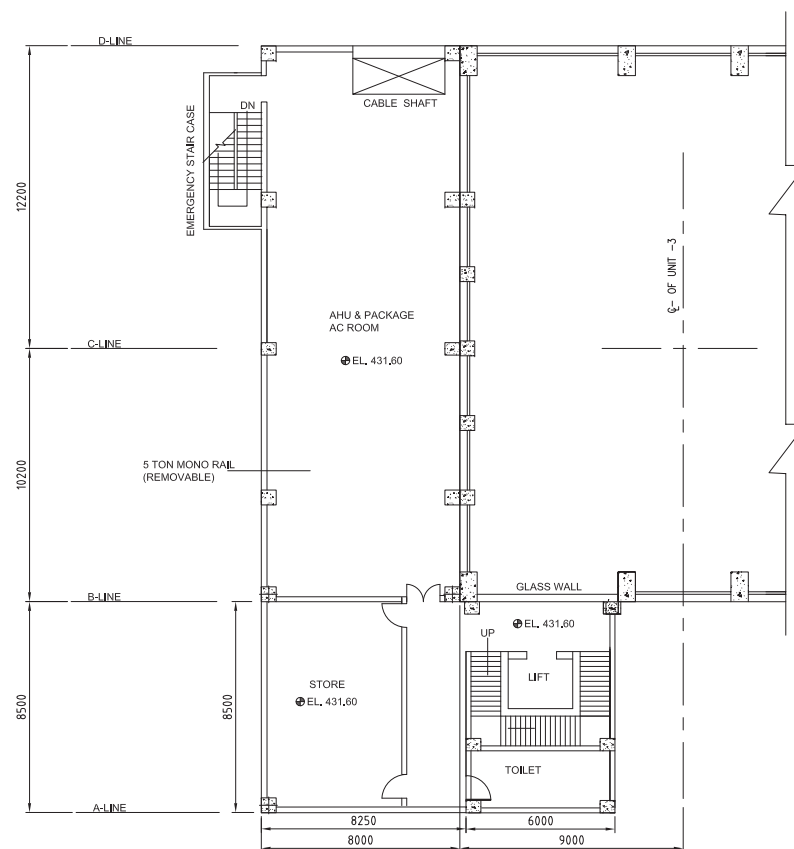


AUXILARY FLOOR
PLAN AT EL. 431.60


CUSTOMER :		 एन टी सी लिमिटेड NTPC (A GOVERNMENT OF INDIA ENTERPRISE)	
PROJECT			
RAMMAM STAGE - III HYDROELECTRIC PROJECT [3X40MW]			
	BHARAT HEAVY ELECTRICALS LTD. BHOPAL	DEPT. CODE DRN T.KHAN CKD S.SAHU APPDR SINGH	NAME SIGN DATE 12.06.18 12.06.18 12.06.18
TITLE		SUB-VENDOR DRG. NO.	PO REF
LAYOUT OF POWER HOUSE AUX. BLOCK AT EL. 427.60 & 431.60		NTPC DRG. NO.	NO. OF ITEMS
SUB-VENDOR NAME		WEIGHT (kg)	SCALE 1:100
		BHEL DRG. NO.	REV.
		12000019858	00
SHEET NO.		01	NO. OF SHEET.
			01

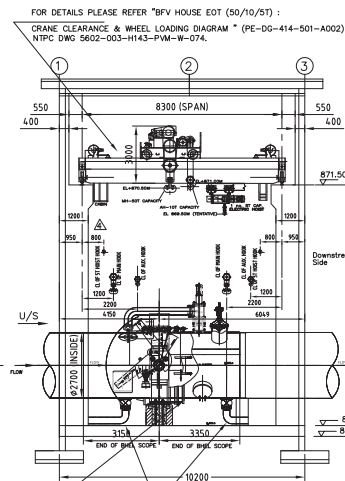

SECTION-AA

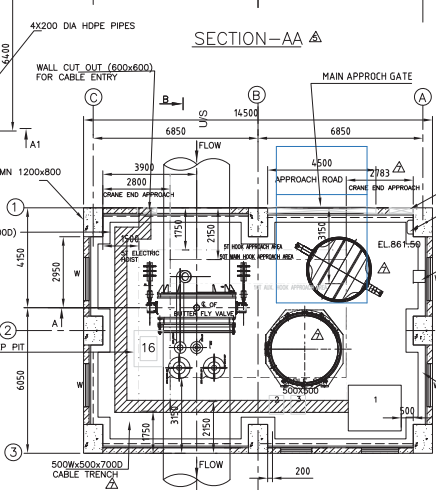

SECTION-BE

 

BF VALVE HOUSE

NOTE:—

- | | | | |
|--|------------|------------------|-----------------------------|
| 1. CUSTOMER'S DRAWING REFERENCE NO. 5602--305(82)--POH-A--028. | | | |
| 2. CIVIL DETAILS TO BE FINALIZED BY NTPC. | | | |
| 3. FOR EMERGENCY & SAFETY OPERATION OF BF VALVE HOUSE, A PATHWAY
ADDITIONAL TO EXISTING MOTORWAY OVERCONNECTING ROAD TO CONTROL BLOCK AND BVC
SHALL BE PROVIDED BETWEEN BUTTERFLY VALVE HOUSE & CONTROL BLOCK BUILDING.
(DETAILS TO BE FINALIZED BY NTPC) | | | |
| 4. FOUNDATION FOR CABLE TRESTLE TO BE PROVIDED BETWEEN VALVE HOUSE AND CONTROL BUILDING
FOR ROUTING OF CABLES. (NTPC SCOPE) | | | |
| 5. SUITABLE DRAINAGE TRENCH IN BFV HOUSE & DRAINAGE FROM DRAIN PIT MAY BE PLANNED BY NTPC | | | |
| 6. SUITABLE TRENCH/PROTECTION SHALL BE PROVIDED BY NTPC IN THE
APPROACH ROAD FOR PREVENTING INGRESS OF RAIN WATER IN THE
VALVE HOUSE | REV.
07 | DATE
25.10.19 | ALTER
CHECK
APPD. |
| 7. SUITABLE BASE FRAME FOR ITEM NO(2) & (3) SHALL BE PROVIDED
BY BHEL FOR FACILITATING BOTTOM CABLE ENTRY. | ZONE
A | | DRAWING REV
NTPC COMMENT |

SL NO.	DESCRIPTION	QTY	DIMENSION IN mm			WEIGHT	DIV.	LOCATION	A
			LENGTH	WIDTH	HEIGHT				
1	HYDRAULIC POWER PACK	1	2200	1900	2500	NA	HPE(GOV)	EL.861.50	
2	HYDRAULIC CONTROL PANEL (FOR B.F. VALVE)	1	1000	800	2250	NA	HPE(GOV)	EL.861.50	
3	ELECTRICAL CONTROL PANEL (FOR B.F. VALVE)	1	1000	800	2300	NA	HPE(GOV)	EL.861.50	
4	415V AC DISTRIBUTION BOARD	1	7500	800	2300	2000	HPE	EL.869.20	
5	250 KVA OIL TYPE TRANSFORMER	2	1500	1000	1600	NA	HPE	EL.869.20	
6	24V DC BATTERY BANK	1	2500	800	1500	NA	EDN	EL.872.70	
7	LIGHTING DISTRIBUTION BOARD	1	1800	900	2350	NA	EDN	EL.869.20	
8	24V DC BATTERY CHARGER	1	2000	1000	2100	NA	EDN	EL.872.70	
9	24V DCDB	1	1000	1000	2100	NA	EDN	EL.872.70	
10	BFV LCB	1	2302	800	2415	2250	EDN	EL.869.20	
11	220V DC BATTERY BANK	2	1825	500	1650	NA	HPE	EL.872.70	
12	220 DC BATTERY CHARGER	1	1600	800	1500	NA	HPE	EL.872.70	
13	220V DCDB	1	1800	500	2200	NA	HPE	EL.872.70	
14	BHMS	1	500	300	500	NA	-	EL.872.70	
15	VENTILATION PANEL	1	1000	800	2300	NA	-	EL.869.20	
16	OIL LEAKAGE UNIT (PORTABLE)	1	1000	700	1000	NA	HTE	EL.861.50	
17	ULTRASONIC FLOW METER PANEL	1	800	300	800	NA	HPE(GOV)	EL.861.50	

NA- NOT AVAILABLE





BF VALVE HOUSE

SL.NO	DESCRIPTION	NTPC DRAWING NO.
01	BFV HOUSE EOT CRANE CLEARANCE & WHEEL LOADING DIAGRAM	5602-003-H143-PVM-W-07
02	DETAIL OF VALVE HOUSE	5602-305 [R2]-PHO-A-028
03	ARRANGEMENT OF DIA 2700 B.F. VALVE	5602-003-H199-PVM-B-003
04	ARRANGEMENT OF VENTILATION SYSTEM OF VALVE HOUSE	5602-003-H145-PVM-F-038
05	TOOLS, TACKLES & ERECTION DEVICES FOR B.F. VALVE	5602-003-H199-PVM-B-008

[illegible]


CUSTOMER :		 एन.टी.पी.सी. लिमिटेड NTPC LIMITED (A GOVERNMENT OF INDIA ENTERPRISE)	
PROJECT		RAMMAM STAGE – III HYDROELECTRIC PROJECT [3X40MW]	
	BHARAT HEAVY ELECTRICALS LTD. BHOPAL	DEPT. CODE DRN T.KHAN CKD S.SAHU APPR'S SUB-VENDOR DRG. NO.	NAME SIGN DATE 21.04.16 21.04.16 21.04.16 PO REF
TITLE		NO. OF ITEMS	
LAYOUT AND CROSS SECTION OF B.F. VALVE HOUSE		NTPC DRG. NO. 5602-906-H115-PVM-F-006	
SUB-VENDOR NAME	WEIGHT (kg)	SCALE 1:75	REV.
			BHEL DRG. NO. 12000019862 SHEET NO. 01 NO. OF SHT. 01

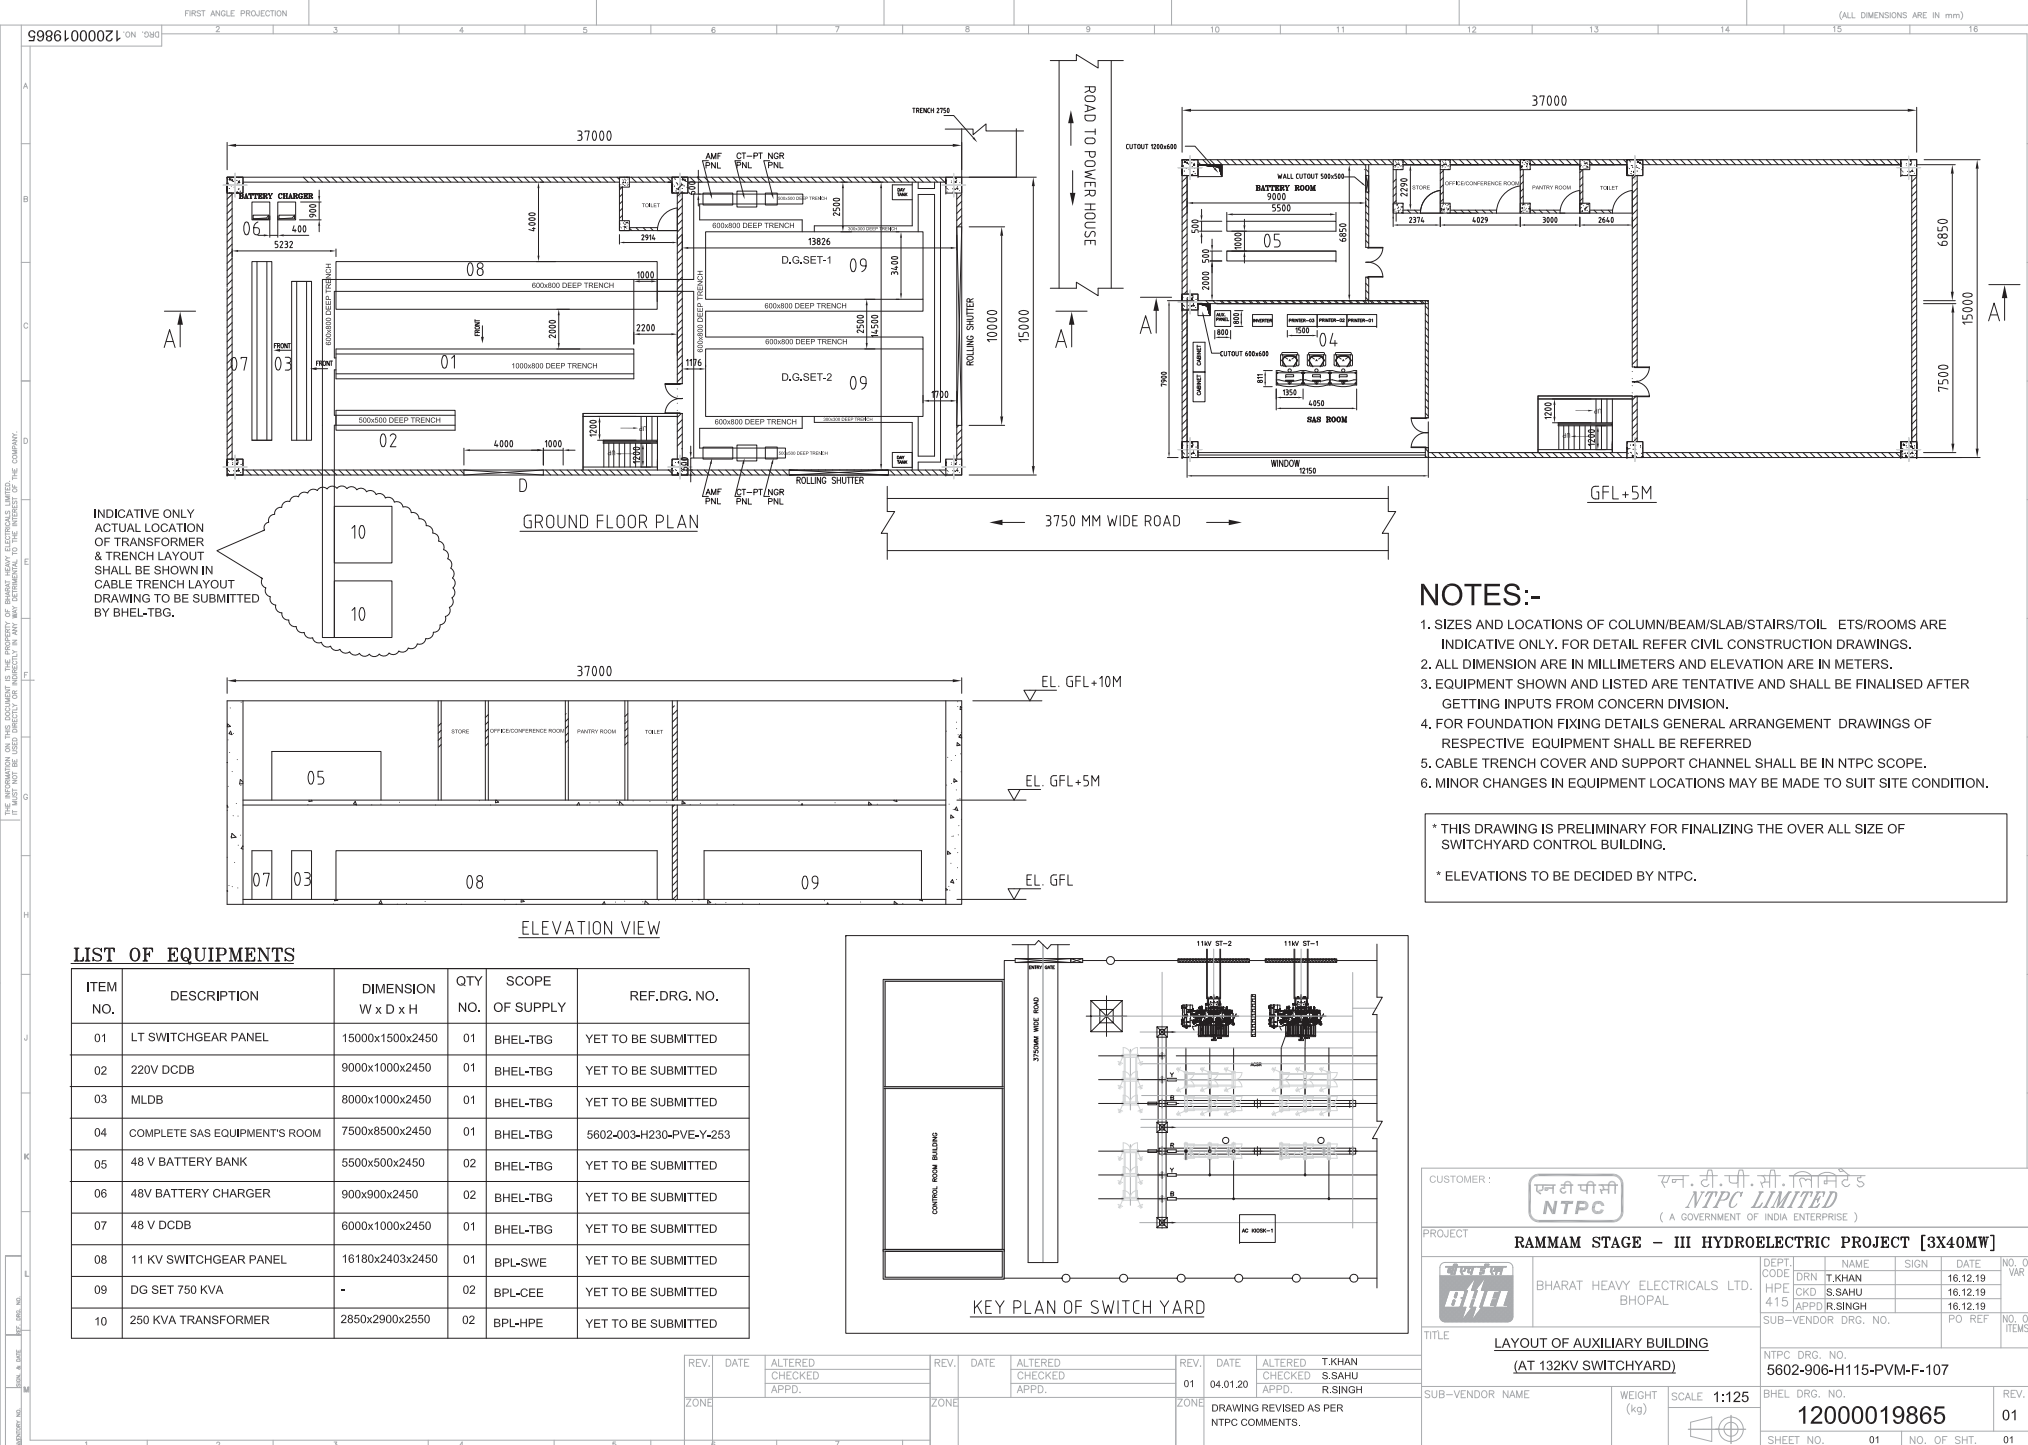

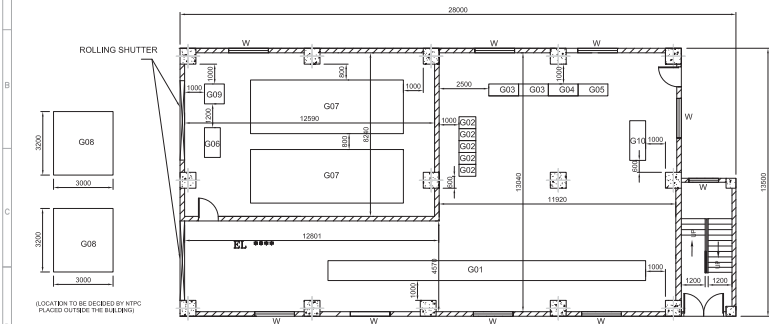


EQUIPMENT'S PLACED AT EL.-'X'(GROUND FLOOR)
(TENTATIVE)

ITEM NO.	DESCRIPTION	DIMENSION W x D x H	QTY	WEIGHT (KG)	SCOPE OF SUPPLY
G01	LT BOARD	1600x1000x400	01		BHEL+HPE
G02	SPELLWAY BOARD	800x800x220	08		BHEL+HPE
G03	INTAKE BOARD	1600x300x220	02		BHEL+HPE
G04	S&T FLUSHING BOARD	1600x300x220	01		BHEL+HPE
G05	DESLTING BOARD	1600x300x220	01		BHEL+HPE
G06	DO SET LOCAL AMP PANEL	1600x800x220	01		BHEL+CEE
G07	FIXED DO SET (33KVIA)	750x2500x200	02		BHEL+CEE
G08	OIL FILLED TRANSFORMER (1250KVA)	3200x3000x3000	02		BHEL+HPE
G09	DO SET DAY TANK	1000x1000x1000	01		BHEL+CEE
G10	MCC FOR VENTILATION	2000x800x100	01		BHEL+PEM
G11					
G12					

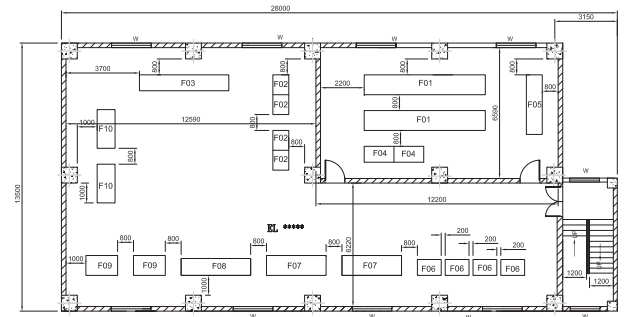

FIRST FLOOR PLAN
AT EL.-'X+4.5M''

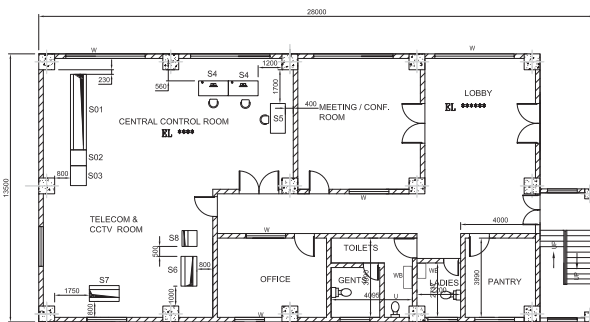

EQUIPMENT'S PLACED AT EL.-'X+9M'(SECOND FLOOR)
(TENTATIVE)

ITEM NO.	DESCRIPTION	DIMENSION W x D x H	QTY	WEIGHT (KG)	SCOPE OF SUPPLY
S01	SPELLWAY INTAKE FLUSHING SPES&LOCAL CONTROL PANEL	380x800x2415	01		EDM
S02	LOCAL H&M PANEL	800x800x2415	01		EDM
S03	ALARM AND INTERLOCK PANEL	1000x800x2415	01		EDM
S04	PC TABLE	1000x750x735	02		EDM
S05	PRINTER TABLE	800x600x740	01		EDM
S06	WATER LEVEL MEASUREMENT PANEL	1600x800x1500	01		BHOPAL
S07	MDM	1600x800x1500	01		BHOPAL
S08	CCTV PANEL	800x760x2100	01		BHEL+HPE
S09					

EQUIPMENT'S PLACED AT EL.-'X+4.5M'(FIRST FLOOR)
(TENTATIVE)

ITEM NO.	DESCRIPTION	DIMENSION W x D x H	QTY	WEIGHT (KG)	SCOPE OF SUPPLY
F01	220V DC BATTERY BANK	6100x1000x1500	02		BHEL+HPE
F02	220V DC BATTERY CHARGER	1000x800x2000	04		BHEL+HPE
F03	220V DCDB	4000x800x2000	01		BHEL+HPE
F04	24V BATTERY BANK	1000x800x1500	02		EDM
F05	UPS BATTERY BANK	3000x800x1500	01		EDM
F06	24V BATTERY CHARGER	1200x800x2000	04		EDM
F07	24V DCDB	3000x1000x2300	02		EDM
F08	UPS AND ALU. PANEL	3500x800x2100	01		EDM
F09	UPS ACDB	1600x1000x2000	02		EDM
F10	ELDR	1900x800x2200	02		BHEL+PEM
F11					
F12					
F13					

SECOND FLOOR PLAN
AT EL.-'X+9M''

ELEVATION OF BARRAGE CONTROL BUILDING (X) TO BE DECIDED BY NTPC

CUSTOMER: **एन टी सी NTPC** **एन.टी.पी.सी. लिमिटेड NTPC LIMITED**
(A GOVERNMENT OF INDIA ENTERPRISE)

PROJECT: **RAMMAM STAGE - III HYDROELECTRIC PROJECT [3X40MW]**

DEPT. CODE: **BHARAT HEAVY ELECTRICALS LTD. BHOPAL**

NAME: **T.KHAN** SIGN: **S.SAHU** DATE: **10.07.18**

HPE: **415** APPD: **R.SINGH** SUB-VENDOR DRG. NO. PO REF. NO. OF ITEMS

TITLE: **LAYOUT OF EQUIPMENTS IN BARRAGE CONTROL BUILDING**


SUB-VENDOR NAME: **BHEL DRG. NO. 5602-906-H115-PVM-F-101**

SCALE: **1:125** WEIGHT (kg): **1200019859** REV. **00**

SHEET NO. **01** NO. OF SHT. **01**

REV.	DATE	ALTERED CHECKED APPD.	REV.	DATE	ALTERED CHECKED APPD.	REV.	DATE	ALTERED CHECKED APPD.
ZONE			ZONE			ZONE		

DRG. NO. 3200019864

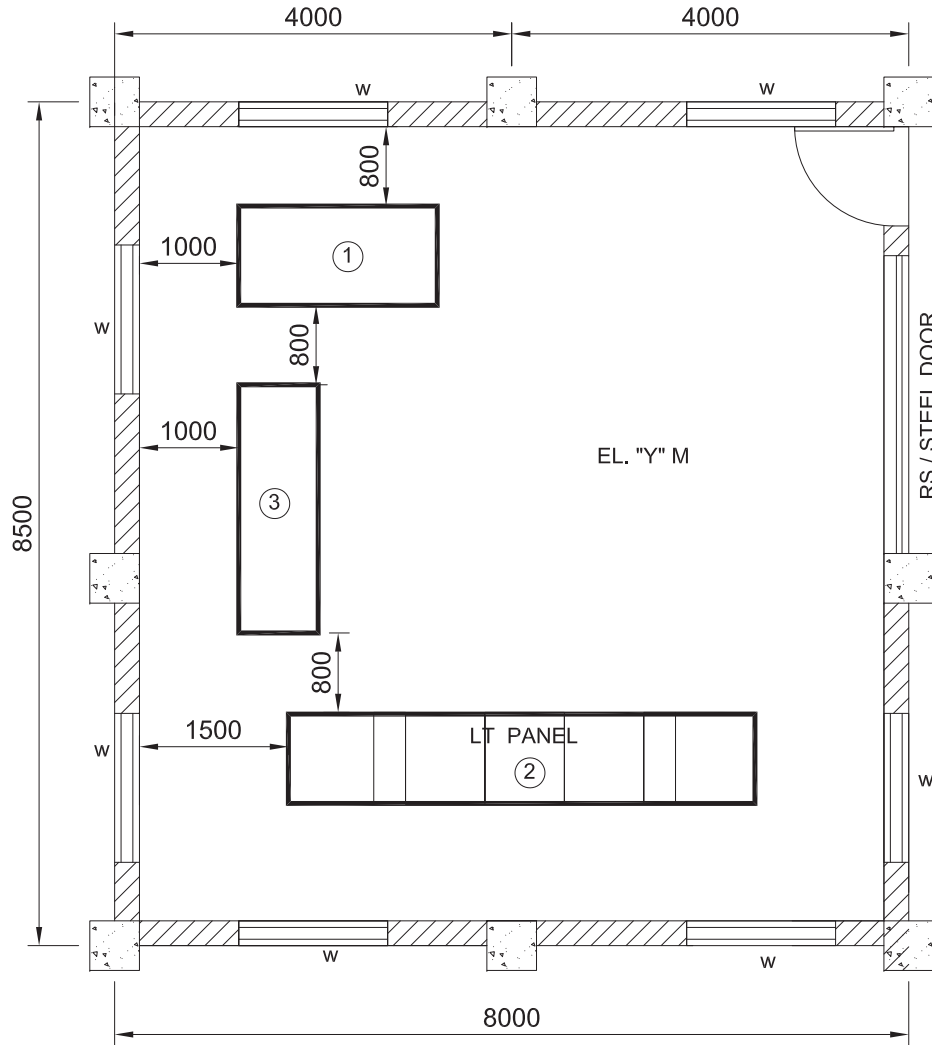

PLAN AT EL.-"Y"

ELEVATION OF SURGE SHAFT AREA (Y) TO BE DECIDED BY NTPC


EQUIPMENT'S PLACED AT EL.-"Y" (TENTATIVE)

ITEM NO.	DESCRIPTION	DIMENSION W x D x H	QTY NO.	WEIGHT (KG)	SCOPE OF SUPPLY
1	MLDB-1	2000 x 1000 x 1800	1		BHEL
2	LT SWITCHGEAR PANEL	4700x 1210x 2530	1		BHEL
3	SURGE SHAFT SUPPLY PANEL (HM PACKAGE)	2500 x 800 x 2000	1		NTPC

NOTES:-

- SIZES AND LOCATIONS OF COLUMN/BEAM/SLAB/STAIRS/TOILETS/ROOMS ARE INDICATIVE ONLY. FOR DETAIL REFER CIVIL CONSTRUCTION DRAWINGS.
- ALL DIMENSION ARE IN MILLIMETERS AND ELEVATION ARE IN METERS.
- EQUIPMENT SHOWN AND LISTED ARE TENTATIVE AND SHALL BE FINALISED AFTER GETTING INPUTS FROM CONCERN DIVISION.
- FOR FOUNDATION FIXING DETAILS GENERAL ARRANGEMENT DRAWINGS OF RESPECTIVE EQUIPMENT SHALL BE REFERRED
- CABLE TRENCH COVER AND SUPPORT CHANNEL SHALL BE IN NTPC SCOPE.
- MINOR CHANGES IN EQUIPMENT LOCATIONS MAY BE MADE TO SUIT SITE CONDITION.
- CLEAR HEIGHT OF THE ROOM FROM BOTTOM OF BEAM SHALL BE 4500mm.

CUSTOMER :		एन टी पी सी NTPC		एन.टी.पी.सी. लिमिटेड NTPC LIMITED (A GOVERNMENT OF INDIA ENTERPRISE)	
PROJECT RAMMAM STAGE - III HYDROELECTRIC PROJECT [3X40MW]					
DEPT. CODE		NAME		SIGN	
HPE		T.KHAN		DATE	
415		S.SAHU		12.07.18	
APPD.		R.SINGH		12.07.18	
SUB-VENDOR DRG. NO.				PO REF	
TITLE		NO. OF ITEMS			
EQUIPMENT LAYOUT FOR SURGE SHAFT AREA					
SUB-VENDOR NAME		WEIGHT (kg)		SCALE 1:25	
NTPC DRG. NO.		BHEL DRG. NO.		REV.	
5602-906-H115-PVM-F-106		3200019864		00	
SHEET NO.		NO. OF SHT.		01	

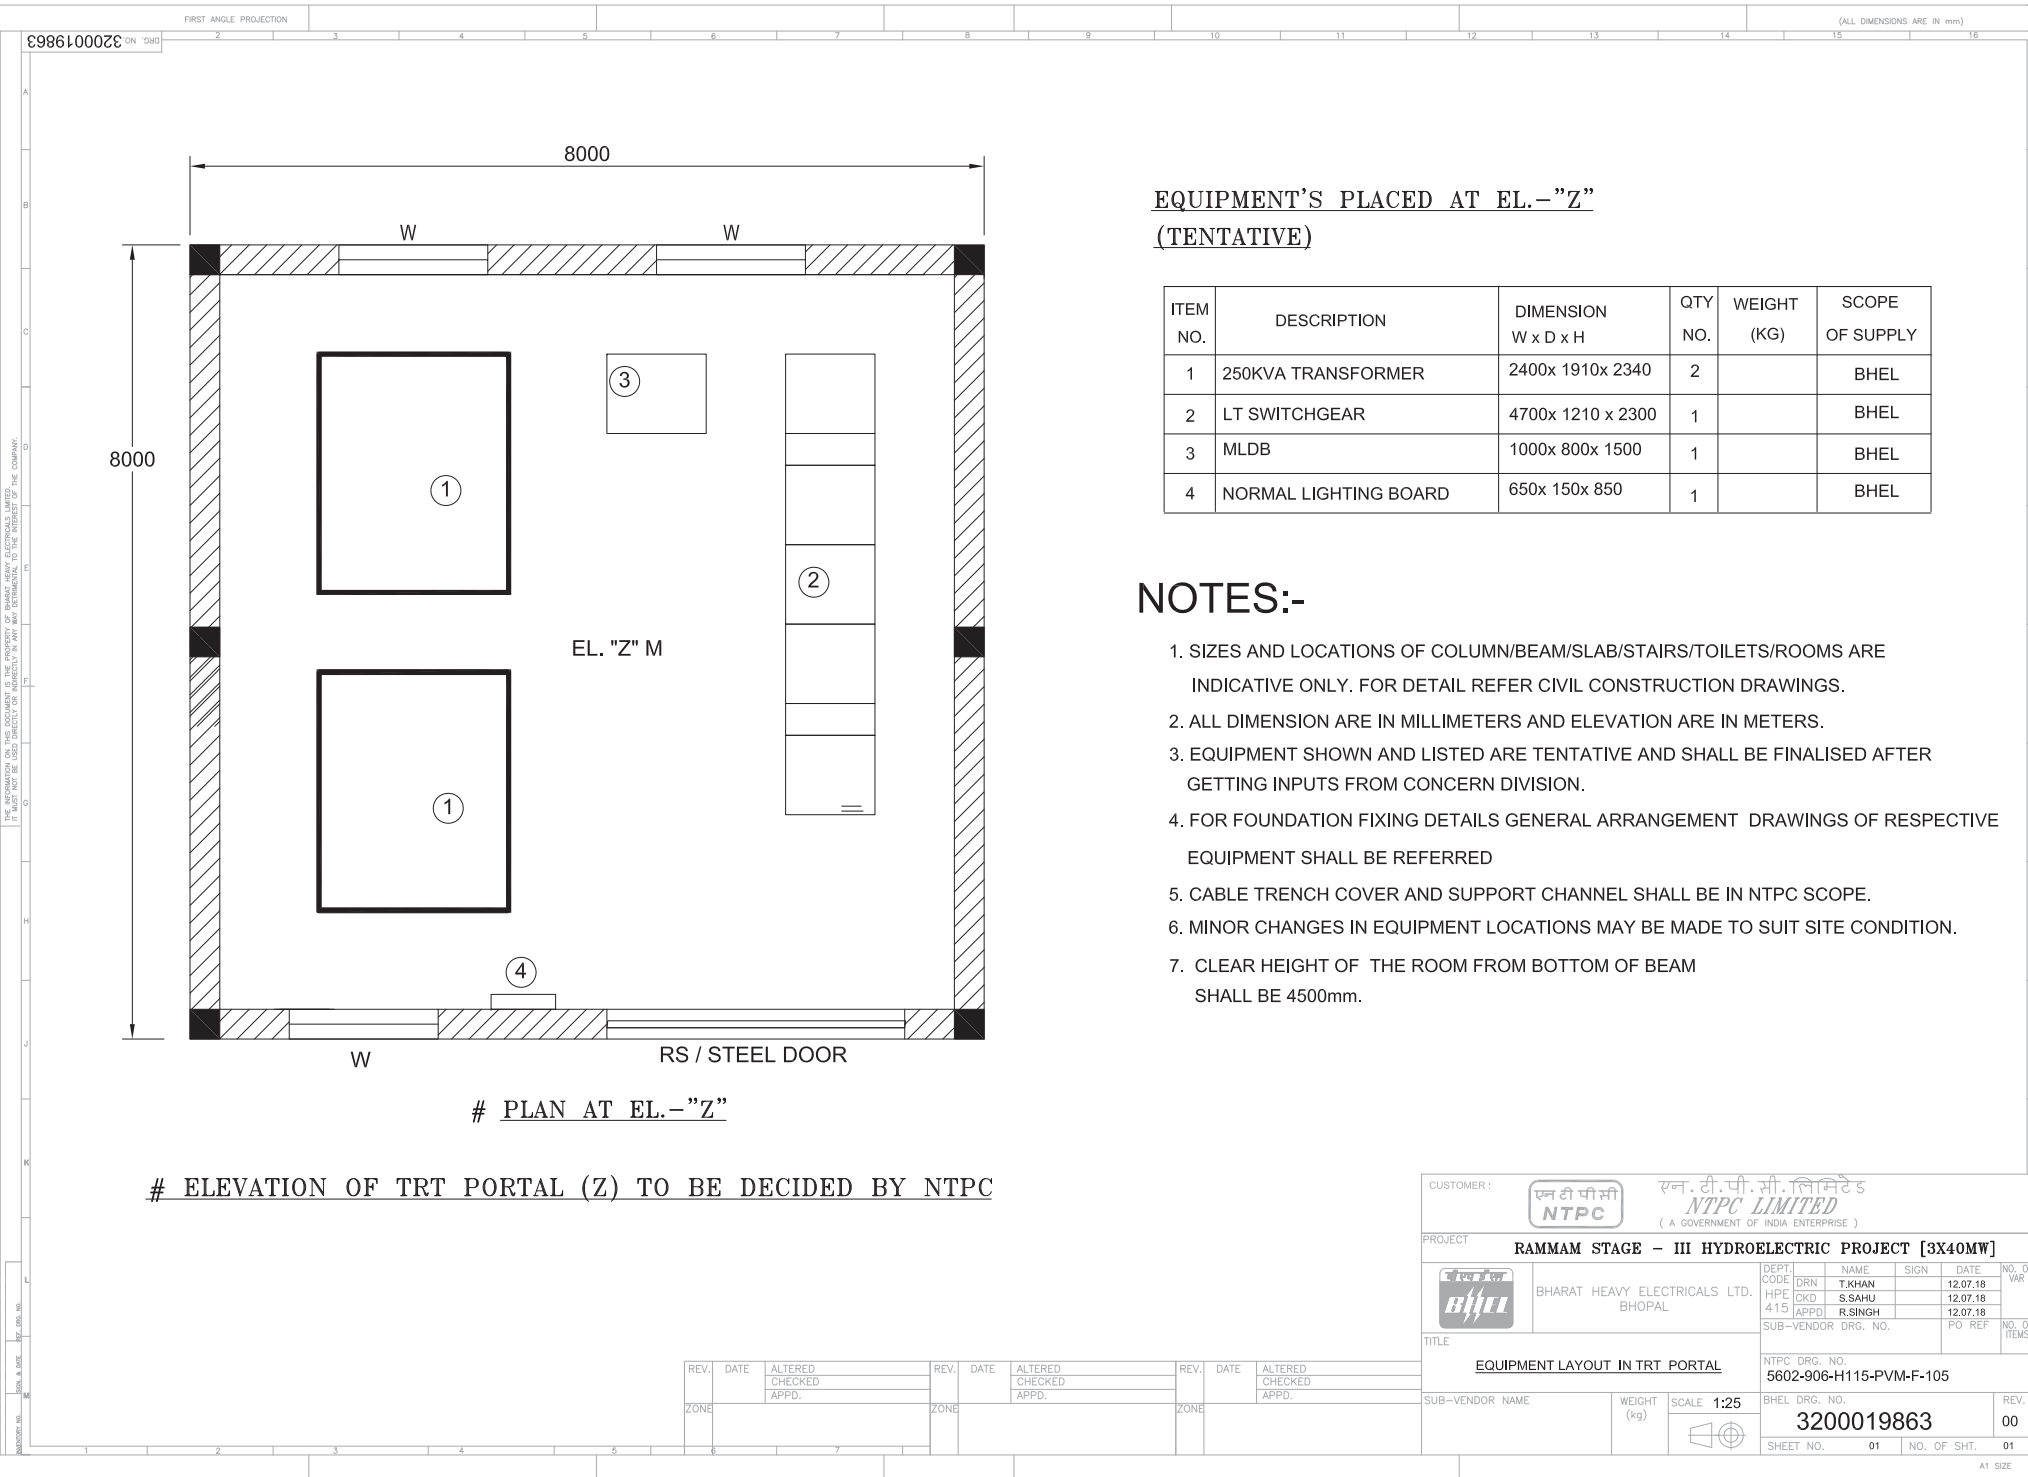


EQUIPMENT'S PLACED AT EL.-"Z"


(TENTATIVE)

ITEM NO.	DESCRIPTION	DIMENSION W x D x H	QTY NO.	WEIGHT (KG)	SCOPE OF SUPPLY
1	250KVA TRANSFORMER	2400x 1910x 2340	2		BHEL
2	LT SWITCHGEAR	4700x 1210 x 2300	1		BHEL
3	MLDB	1000x 800x 1500	1		BHEL
4	NORMAL LIGHTING BOARD	650x 150x 850	1		BHEL

NOTES:-

- SIZES AND LOCATIONS OF COLUMN/BEAM/SLAB/STAIRS/TOILETS/ROOMS ARE INDICATIVE ONLY. FOR DETAIL REFER CIVIL CONSTRUCTION DRAWINGS.
- ALL DIMENSION ARE IN MILLIMETERS AND ELEVATION ARE IN METERS.
- EQUIPMENT SHOWN AND LISTED ARE TENTATIVE AND SHALL BE FINALISED AFTER GETTING INPUTS FROM CONCERN DIVISION.
- FOR FOUNDATION FIXING DETAILS GENERAL ARRANGEMENT DRAWINGS OF RESPECTIVE EQUIPMENT SHALL BE REFERRED
- CABLE TRENCH COVER AND SUPPORT CHANNEL SHALL BE IN NTPC SCOPE.
- MINOR CHANGES IN EQUIPMENT LOCATIONS MAY BE MADE TO SUIT SITE CONDITION.
- CLEAR HEIGHT OF THE ROOM FROM BOTTOM OF BEAM SHALL BE 4500mm.

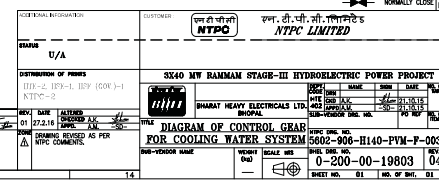

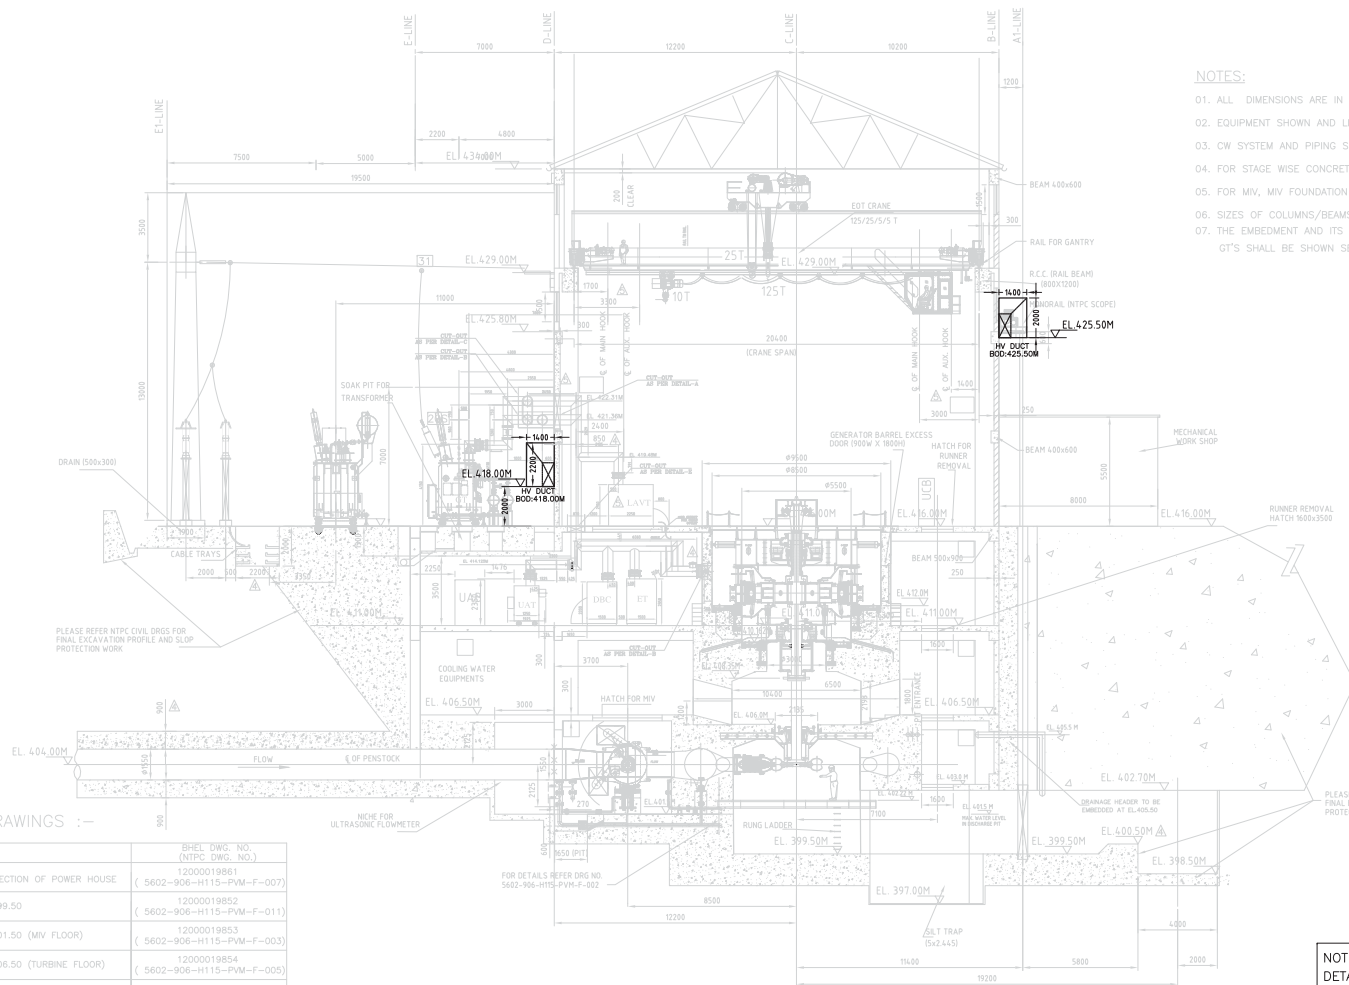

NOTES:

01. ALL DIMENSIONS ARE IN MILLIMETRES AND ELEVATIONS ARE IN METRES.
02. EQUIPMENT SHOWN AND LISTED ARE TENTATIVE AND SHALL BE FINALISED INCLUDING SIZES DURING DETAILED DESIGN.
03. CW SYSTEM AND PIPING SHOWN ARE INDICATIVE, REFER COOLING WATER AND HVAC DRAWINGS FOR COMPLETE DETAILS.
04. FOR STAGE WISE CONCRETING AND EMBEDMENT DETAILS REFER TURBINE DRAWINGS OF BHEL.
05. FOR MV, MV FOUNDATION AND COUNTERWEIGHT PIT DETAILS REFER TURBINE DRAWINGS OF BHEL.
06. SIZES OF COLUMNS/BEAMS/SLABS/STAIRS ARE INDICATIVE ONLY. FOR DETAILS REFER CIVIL CONSTRUCTION DRAWINGS.
07. THE EMBEDMENT AND ITS DETAILS FOR TRINGING OF THE ACSR CONDUCTOR FOR CONNECTING TAP OFF TO LA AND GT'S SHALL BE SHOWN SEPARATELY BY TBG GROUP.

LINKED DRAWINGS :-


SL NO.	DESCRIPTION	BHEL DWG NO. (NTPC DWG. NO.)
01	LONGITUDINAL SECTION OF POWER HOUSE	12000019861 (5602-906-H115-PVM-F-007)
02	PLAN AT EL. 399.50	12000019852 (5602-906-H115-PVM-F-011)
03	PLAN AT EL. 401.50 (MV FLOOR)	12000019853 (5602-906-H115-PVM-F-003)
04	PLAN AT EL. 406.50 (TURBINE FLOOR)	12000019854 (5602-906-H115-PVM-F-005)
05	PLAN AT EL. 411.00 (GENERATOR FLOOR)	12000019855 (5602-906-H115-PVM-F-008)
06	PLAN AT EL. 416.00 (MACHINE HALL FLOOR)	12000019856 (5602-906-H115-PVM-F-009)
07	LAYOUT OF POWER HOUSE AUX. BLOCK	12000019158 (5602-906-H115-PVM-F-104)
08	FIRST STAGE PIPES AND EMBEDMENTS DRG.	02010419801 (5602-906-H115-PVM-F-002)
09	CRANE CLEARANCE DIAGRAM	RE-10-414-501-A001 (5602-003-H143-PVM-W-039)
10	GENERATOR FOUNDATION	02500087601 (5602-003-H231-PVE-V-084)
11	EMBEDMENTS & PIPES IN SECOND STAGE	02020819801 (5602-906-H115-PVM-F-004)
12	ARRGT. OF DEFLECTOR SERVO MOTOR	02160319801 (5602-906-H115-PVM-B-011)
13	GUIDE BEARING ARRANGEMENT	02060119801 (5602-906-H115-PVM-B-017)
14	SECTIONAL ARRANGEMENT	02500087617 (5602-003-H231-PVE-B-014)
15	LAYOUT OF IPB MAIN, DELTA & TAP-OFF-RUN) FOR UNIT-A2&3	0169141001 SHT 01

CROSS SECTION OF POWER HOUSE
THROUGH WATER CONDUCTOR SYSTEM (UNIT-I)


NOTE: THIS VENTILATION DUCT LAYOUT IS INDICATIVE AND DETAILED DRAWING SHALL BE PREPARED AFTER FINALIZATION OF HVAC SUPPLIER.

CUSTOMER:		एन टी सी NTPC		एन. टी. पी. सी. लिमिटेड NTPC LIMITED (A GOVERNMENT OF INDIA ENTERPRISE)	
PROJECT		RAMMAM STAGE - III HYDROELECTRIC PROJECT [3X40MW]			
BHEL		BHARAT HEAVY ELECTRICALS LTD. BHOPAL		DEPT: DRN T.KHAN HPE: CKD S.SAHU 415 APPD: R.S. SUB-VENDOR DRG. NO. PO REF NO. OF ITEMS	
TITLE		STATION LAYOUT - ELEVATION			
SUB-VENDOR NAME		WEIGHT (kg)		SCALE 1:125	
				NTPC DRG. NO. 5602-906-H115-PVM-F-001 BHEL DRG. NO. 12000019851 SHEET NO. 01 NO. OF SHT. 01	


SHEET NO. 12000019857

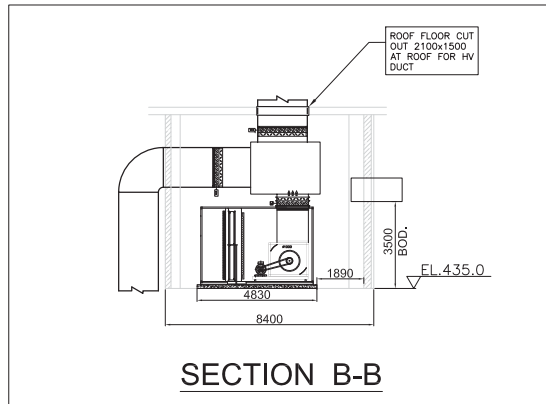

SECTION B-B

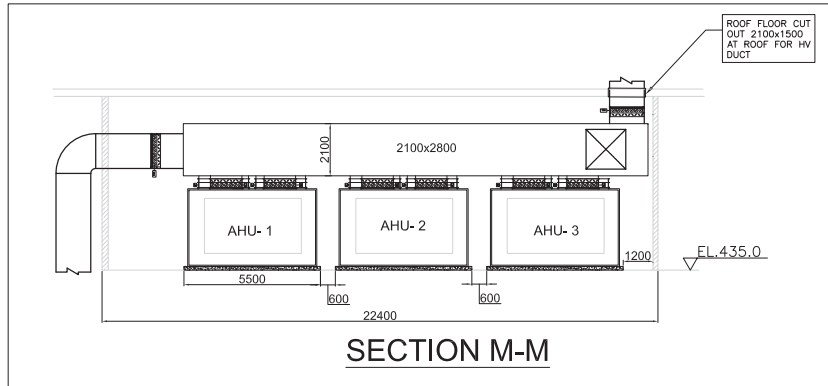


SECTION M-M

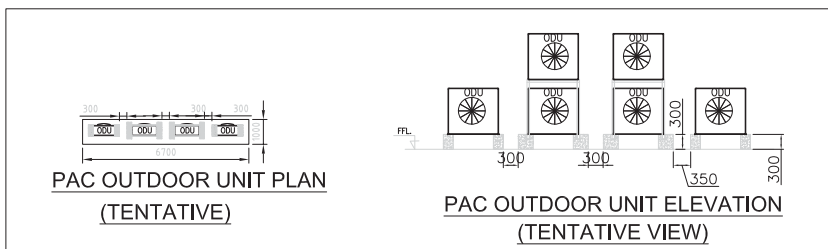

NOTE:


- 1: THIS VENTILATION DUCT LAYOUT IS INDICATIVE AND DETAILED DRAWING SHALL BE PREPARED AFTER FINALIZATION OF HVAC SUPPLIER.
- 2: SPACE REQUIREMENT FOR HVAC EQUIPMENT ARE TENTATIVE AND FINAL LAYOUT SHALL BE PREPARED AFTER FINALIZATION OF HVAC SUPPLIER.
- 3: OUTDOOR UNIT FOR PAC FOR CONTROL ROOM (EL. 435.00) SHALL BE PLACED ON THE ROOF OF CONTROL ROOM/PAC ROOM.
- 4: OUTDOOR UNIT FOR PAC FOR CONTROL PROTECTION AND CONFERENCE ROOM (EL. 420.25) SHALL BE PLACED AT EL. 416 OUTSIDE THE POWER HOUSE.
- 5: LOCATION OF EQUIPMENT MAY CHANGED DURING DETAILED ENGINEERING.

AHU ROOM EQUIPMENT PLAN AND ELEVATION (TENTATIVE)

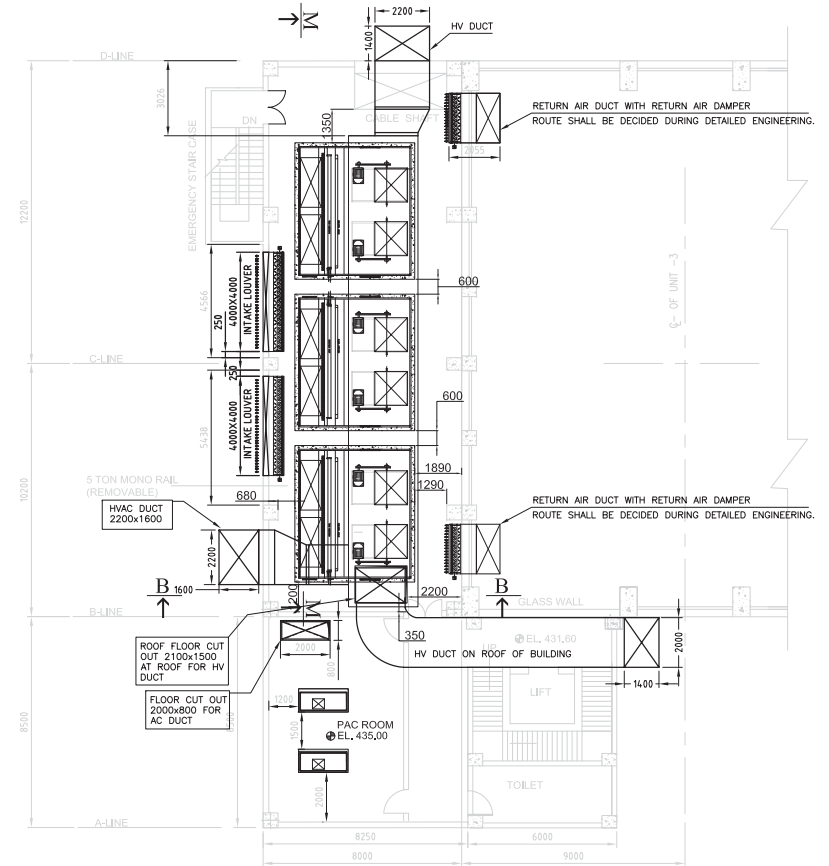AUXILIARY FLOOR
PLAN AT EL. 435.00

REV.	DATE	ALTERED	CHECKED	APPD.	REV.	DATE	ALTERED	CHECKED	APPD.	REV.	DATE	ALTERED	CHECKED	APPD.
ZONE					ZONE					ZONE				

CUSTOMER:		एन टी पी सी NTPC		एन. टी. पी. सी. लिमिटेड NTPC LIMITED (A GOVERNMENT OF INDIA ENTERPRISE)	
PROJECT		RAMMAM STAGE - III HYDROELECTRIC PROJECT [3X40MW]			
DEPT.		NAME		SIGN	DATE
HPE		DRN T. KHAN			12.06.18
415		CKD S. SAHU			12.06.18
SUB-VENDOR DRG. NO.		APPD. R. SINGH		PO REF	NO. OF ITEMS
TITLE		LAYOUT OF POWER HOUSE AUX. BLOCK AHU ROOM AND PAC ROOM (EL. 435.00)			
SUB-VENDOR NAME		WEIGHT (kg)		SCALE 1:100	REV.
					00
SHEET NO.		01		NO. OF SHT. 01	

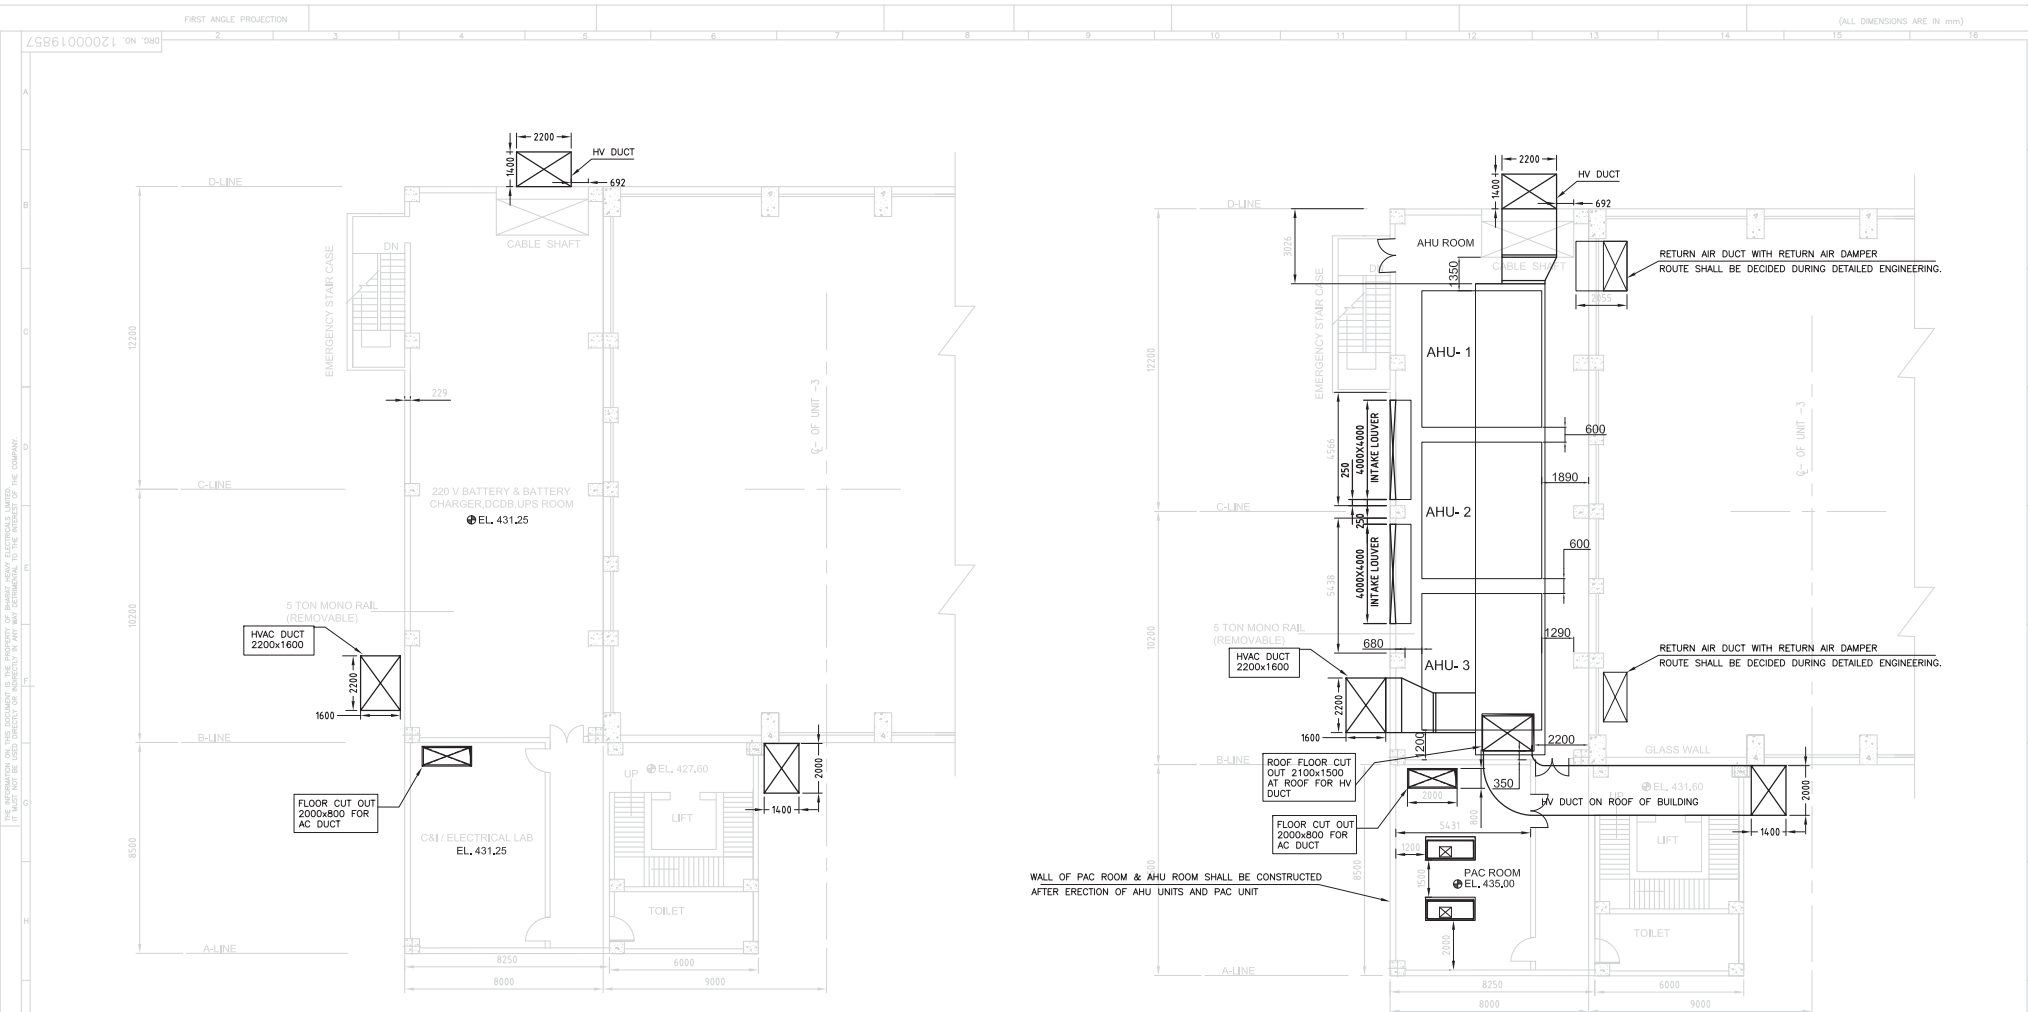


AUXILIARY FLOOR
PLAN AT EL. 431.25

AUXILIARY FLOOR
PLAN AT EL. 435.00

NOTE: THIS VENTILATION DUCT LAYOUT IS INDICATIVE AND
DETAILED DRAWING SHALL BE PREPARED AFTER FINALIZATION
OF HVAC SUPPLIER.

REV.	DATE	ALTERED	CHECKED	REV.	DATE	ALTERED	CHECKED	REV.	DATE	ALTERED	CHECKED
			APPD.				APPD.				APPD.
ZONE				ZONE				ZONE			

CUSTOMER:		एन टी पी सी NTPC		एन.टी.पी.सी. लिमिटेड NTPC LIMITED (A GOVERNMENT OF INDIA ENTERPRISE)				
PROJECT		RAMMAM STAGE - III HYDROELECTRIC PROJECT [3X40MW]						
		BHARAT HEAVY ELECTRICALS LTD. BHOPAL		DEPT. CODE	NAME	SIGN	DATE	NO. OF
				HPE	CKD S.SAHU		12.06.18	VAR
				415	APPD/R.SINGH		12.06.18	
				SUB-VENDOR DRG. NO.		PO REF		NO. OF
TITLE		LAYOUT OF POWER HOUSE AUX. BLOCK AT EL. 431.50 & 435.00		NTPC DRG. NO.		5602-906-H115-PVM-F-104		
SUB-VENDOR NAME				BHEL DRG. NO.		12000019858		REV.
				WEIGHT (kg)		SCALE 1:100		
						SHEET NO. 01		NO. OF SHT. 01

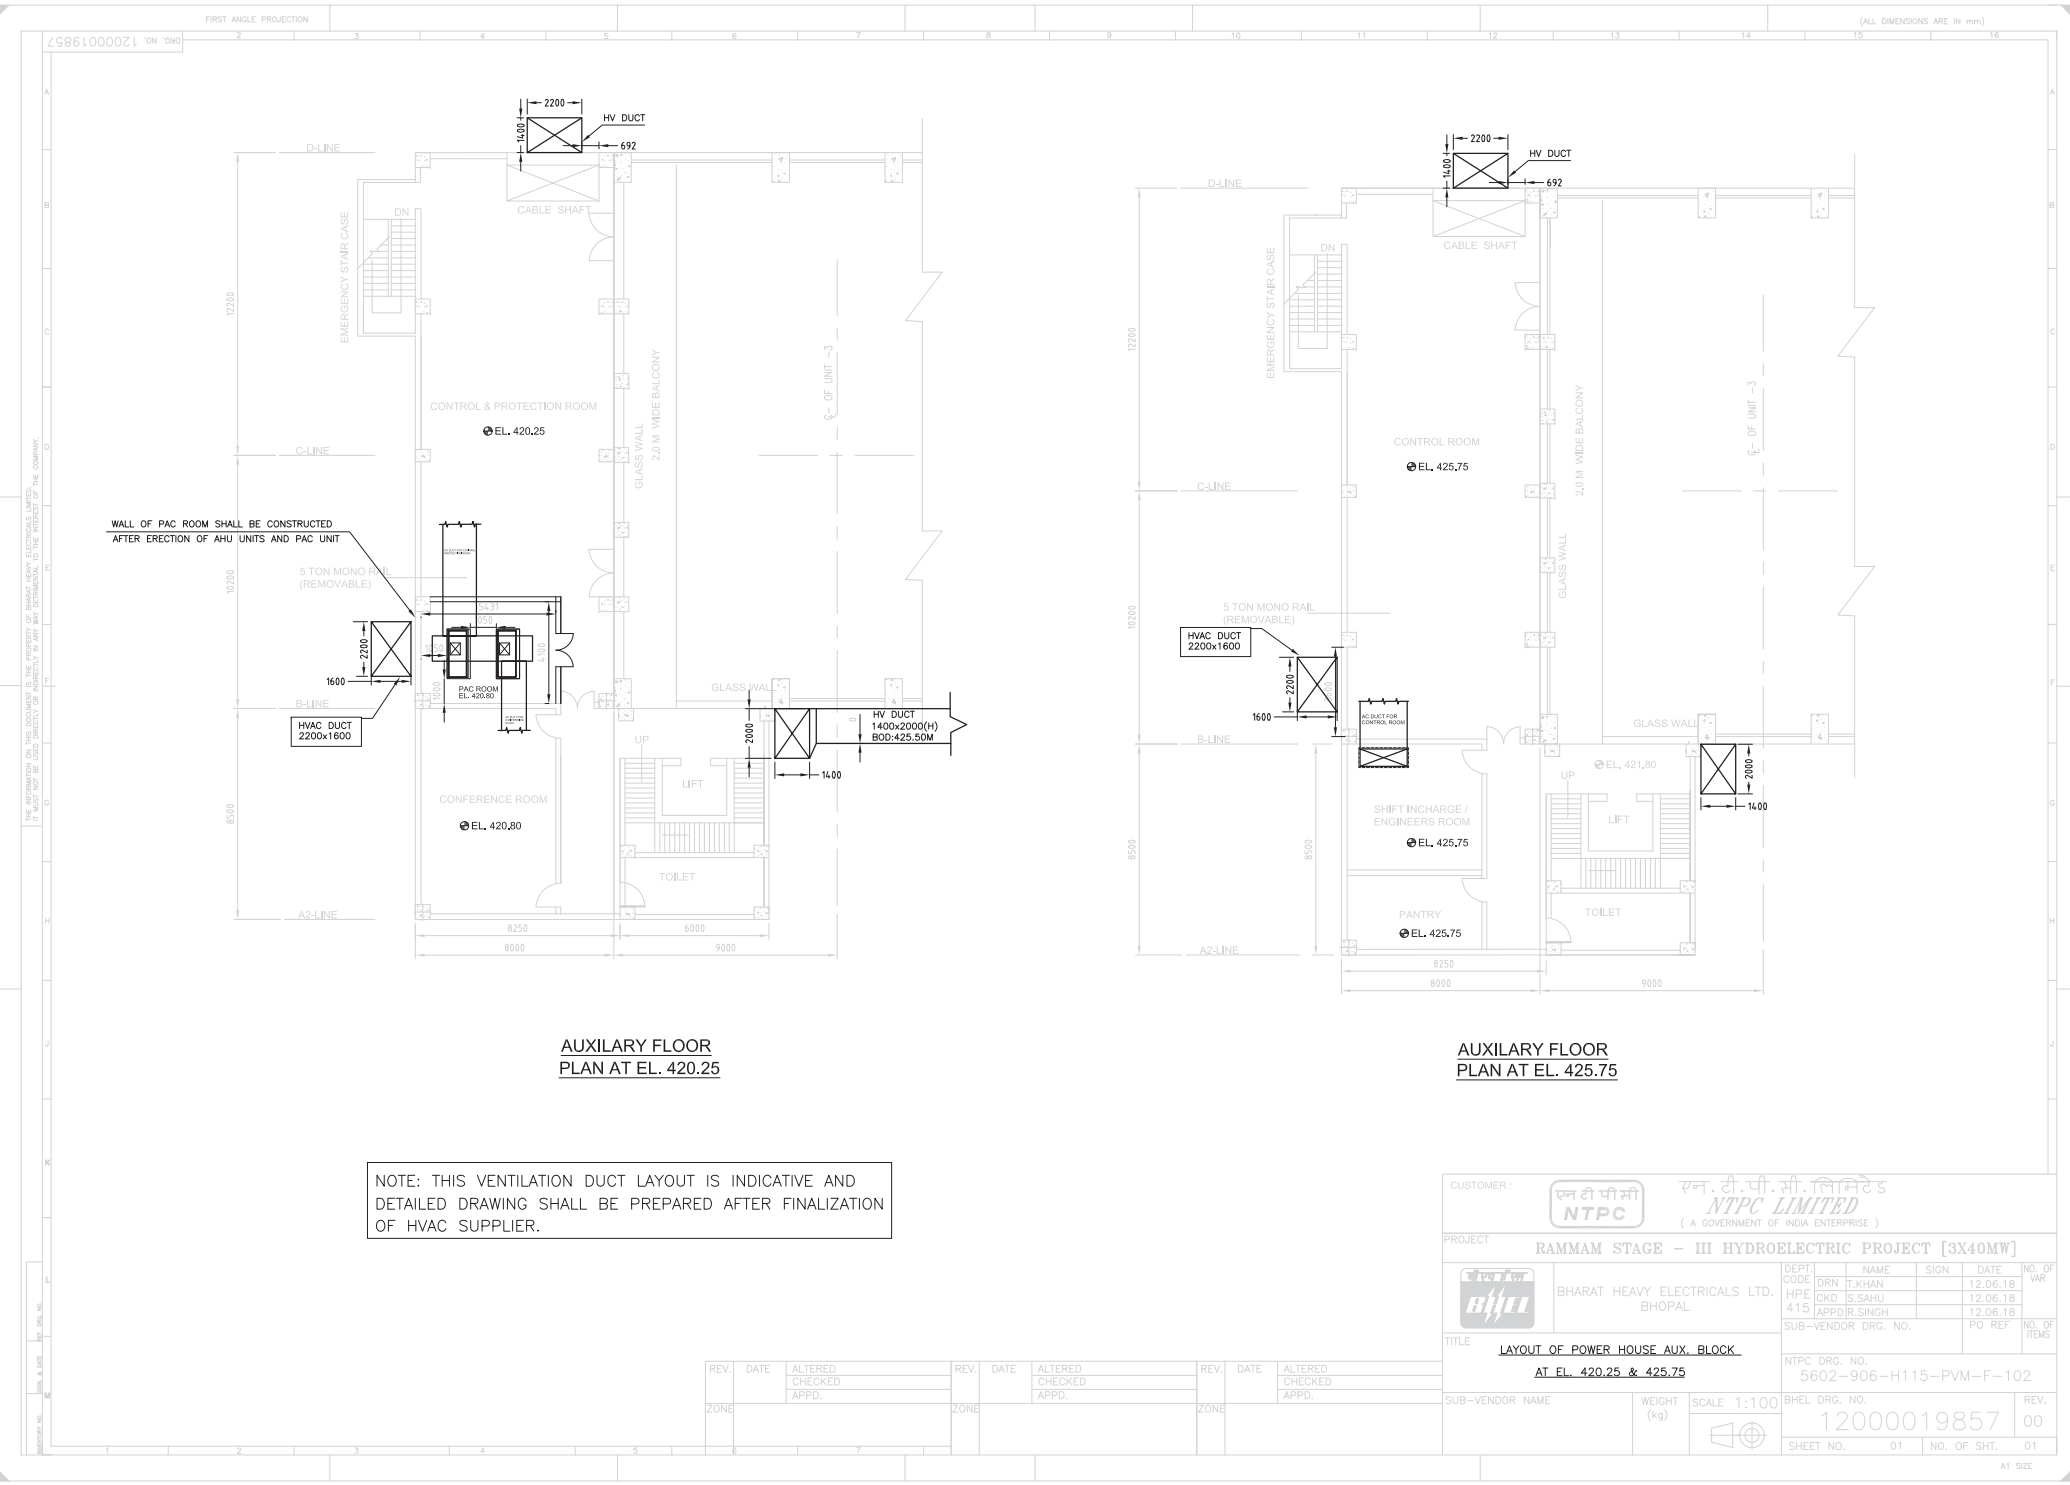


**AUXILIARY FLOOR
PLAN AT EL. 420.25**

**AUXILIARY FLOOR
PLAN AT EL. 425.75**

NOTE: THIS VENTILATION DUCT LAYOUT IS INDICATIVE AND DETAILED DRAWING SHALL BE PREPARED AFTER FINALIZATION OF HVAC SUPPLIER.

CUSTOMER:		एन टी पी सी NTPC		एन. टी. पी. सी. लिमिटेड			
				NTPC LIMITED			
				(A GOVERNMENT OF INDIA ENTERPRISE)			
PROJECT		RAMMAM STAGE - III HYDROELECTRIC PROJECT [3X40MW]					
एन टी पी सी BHEL	BHARAT HEAVY ELECTRICALS LTD. BHOPAL		DEPT	NAME	SIGN	DATE	NO. OF
			CODE	DRN T.KHAN		12.06.18	VAR
			HPE	CKD S.SAHU		12.06.18	
			415	APPD R.SINGH		12.06.18	
SUB-VENDOR DRG. NO.			PO REF			NO. OF	
TITLE			LAYOUT OF POWER HOUSE AUX. BLOCK			REV.	
AT FL. 420.25 & 425.75			NTPC DRG. NO.			00	
			5602-906-H115-PVM-F-102				
SUB-VENDOR NAME		WEIGHT (kg)	SCALE 1:100		BHEL DRG. NO.		REV.
					12000019857		00
					SHEET NO. 01		NO. OF SHT. 01

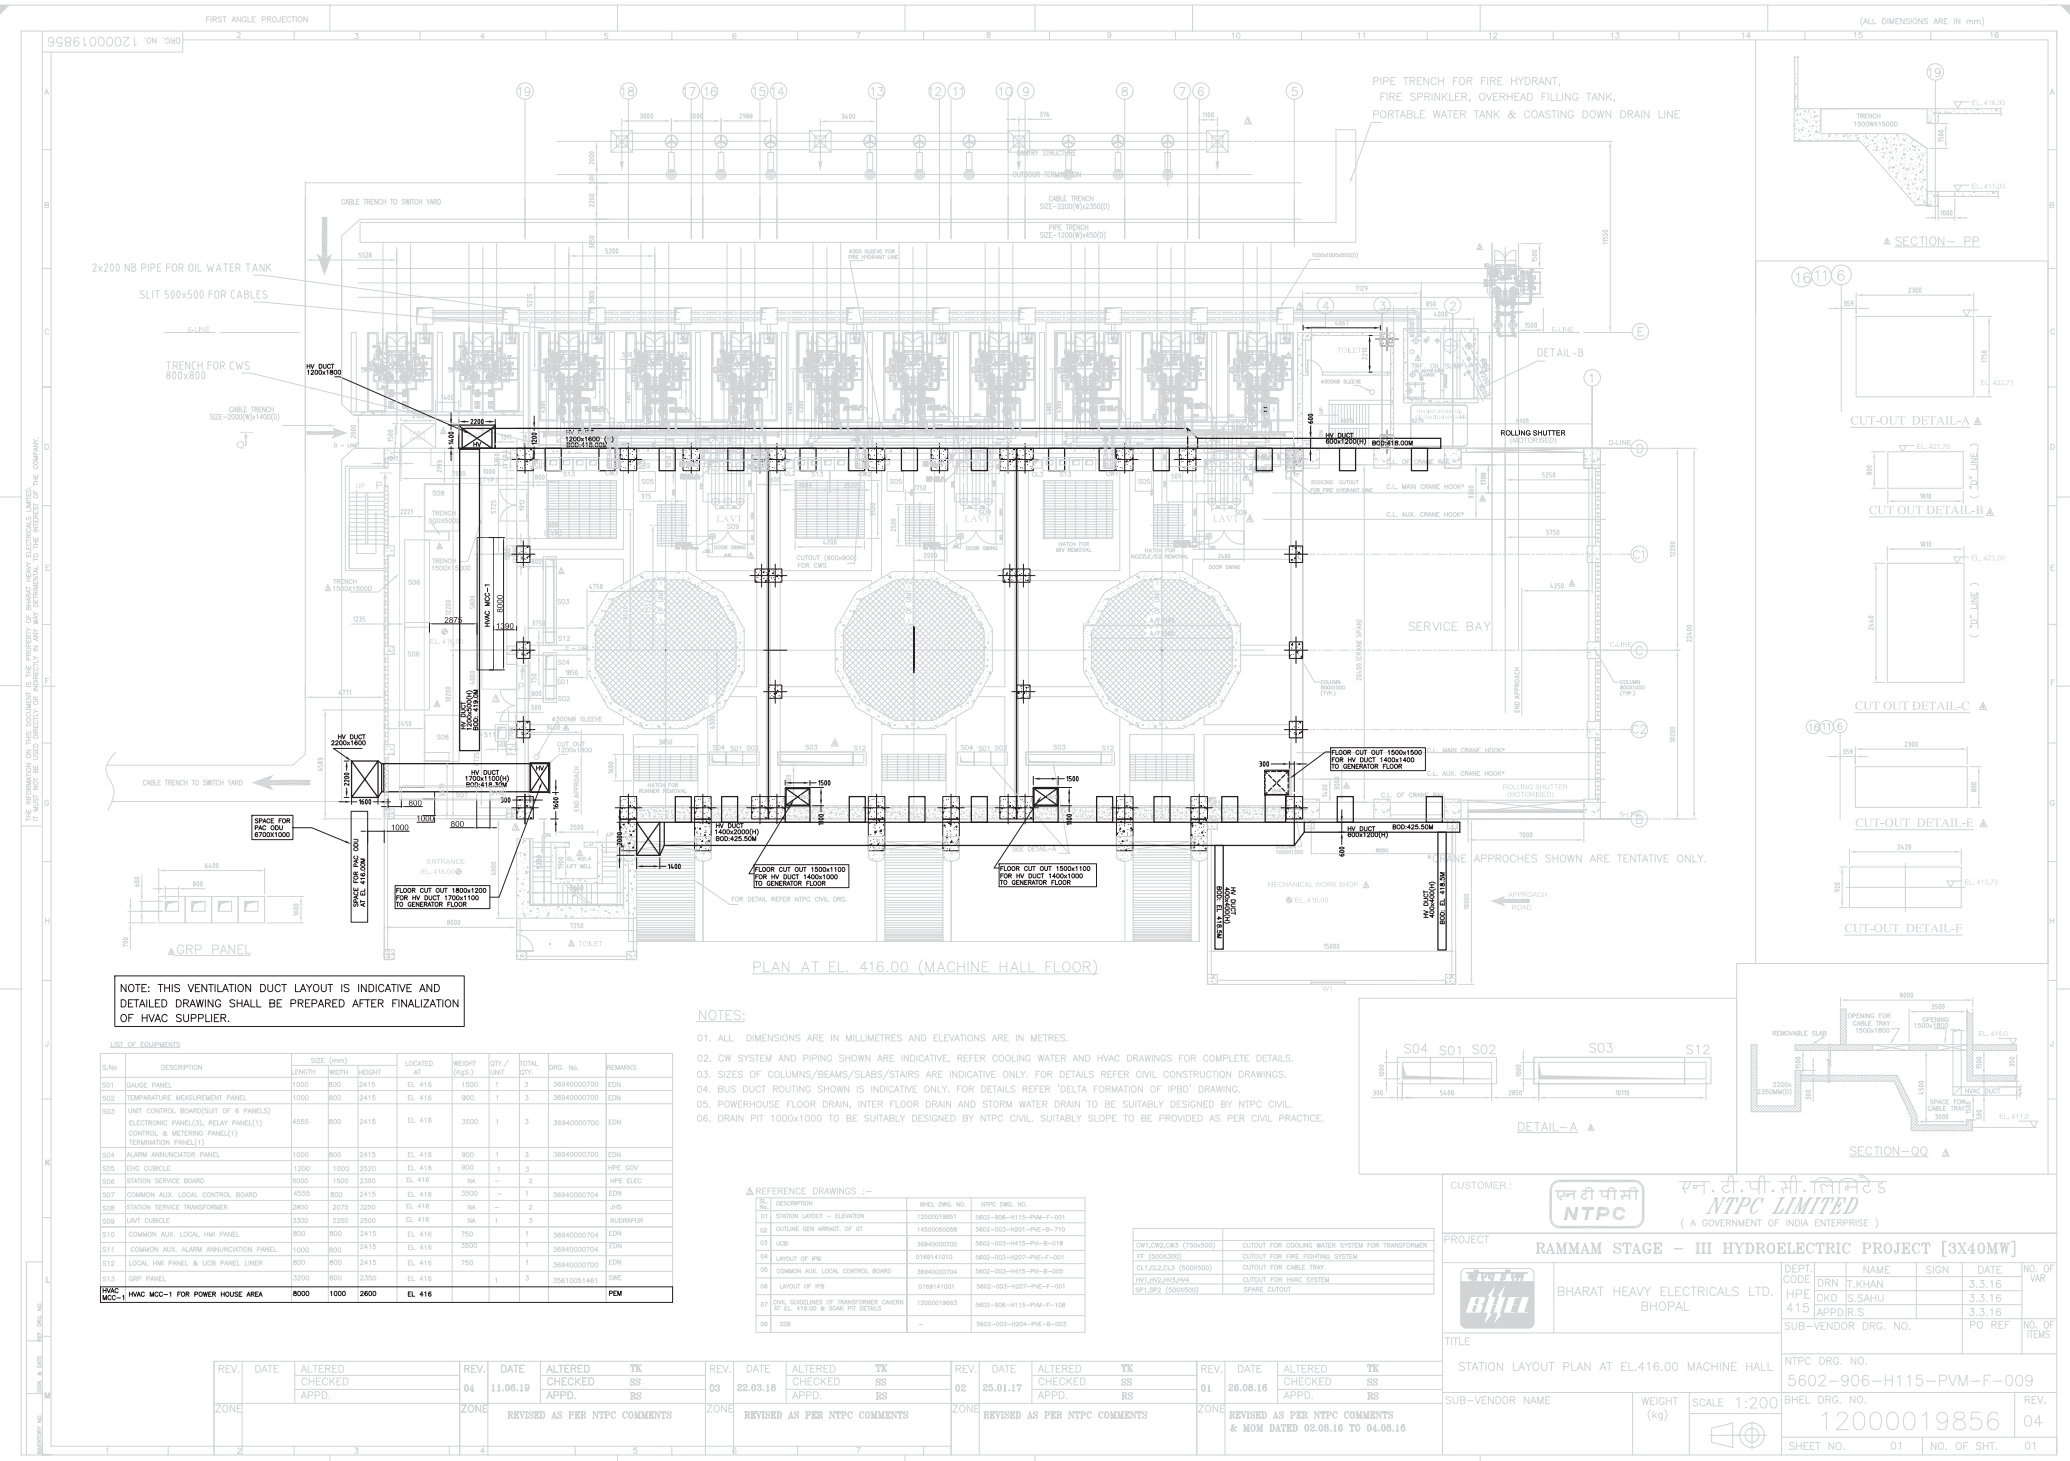

NOTE: THIS VENTILATION DUCT LAYOUT IS INDICATIVE AND DETAILED DRAWING SHALL BE PREPARED AFTER FINALIZATION OF HVAC SUPPLIER.

LIST OF EQUIPMENTS		SIZE (mm)		LOCATED AT	HEIGHT (mgs)	QTY / UNIT	TOTAL QTY.	DRG. NO.	REMARKS
S.No	DESCRIPTION	LENGTH	WIDTH						
S01	GAUGE PANEL	1000	800	EL. 416	1500	1	3	36840000700	EDN
S02	TEMPERATURE MEASUREMENT PANEL	1000	800	EL. 416	900	1	3	36840000700	EDN
S03	UNIT CONTROL BOARD/OUT OF 8 PANELS ELECTRONIC PANEL(S), RELAY PANEL(S) CONTROL & METERING PANEL(S) TERMINATION PANEL(S)	4555	800	EL. 416	3500	1	3	36840000700	EDN
S04	ALARM ANNUNCIATOR PANEL	1000	800	EL. 416	900	1	3	36840000700	EDN
S05	ENV. CUBICLE	1200	1000	EL. 416	900	1	3		HPE GOV
S06	STATION SERVICE BOARD	9000	1500	EL. 416	NA	—	2		HPE ELEC
S07	COMMON AUX. LOCAL CONTROL BOARD	4555	800	EL. 416	3500	—	1	36840000704	EDN
S08	STATION SERVICE TRANSFORMER	3800	2075	EL. 416	NA	—	2		JMS
S09	LVNT CUBICLE	3300	2250	EL. 416	NA	1	3		WILCOX/UPR
S10	COMMON AUX. LOCAL HMI PANEL	800	800	EL. 416	750	1	3	36840000704	EDN
S11	COMMON AUX. ALARM ANNUNCIATOR PANEL	1000	800	EL. 416	3500	—	1	36840000704	EDN
S12	LOCAL HMI PANEL & USB PANEL LINER	800	800	EL. 416	750	1	3	36840000700	EDN
S13	DRP PANEL	5200	800	EL. 416	—	1	3	356100051461	DRP
HVC MCC-1 FOR POWER HOUSE AREA		8000	1000	2600	EL. 416				PEM

NOTES:

01. ALL DIMENSIONS ARE IN MILLIMETRES AND ELEVATIONS ARE IN METRES.
02. CW SYSTEM AND PIPING SHOWN ARE INDICATIVE, REFER COOLING WATER AND HVAC DRAWINGS FOR COMPLETE DETAILS.
03. SIZES OF COLUMNS/BEAMS/SLABS/STAIRS ARE INDICATIVE ONLY. FOR DETAILS REFER CIVIL CONSTRUCTION DRAWINGS.
04. BUS DUCT ROUTING SHOWN IS INDICATIVE ONLY. FOR DETAILS REFER 'DELTA FORMATION OF IPED' DRAWING.
05. POWERHOUSE FLOOR DRAIN, INTER FLOOR DRAIN AND STORM WATER DRAIN TO BE SUITABLY DESIGNED BY NTPC CIVIL.
06. DRAIN PIT 1000x1000 TO BE SUITABLY DESIGNED BY NTPC CIVIL. SUITABLY SLOPE TO BE PROVIDED AS PER CIVIL PRACTICE.

REFERENCE DRAWINGS :-

NO.	DESCRIPTION	BHEL DRG. NO.	NTPC DRG. NO.
S1	STATION LAYOUT - ELEVATION	12000019851	5602-906-H115-PVM-F-001
S2	STATION GEN ARRANG. OF GT	14000000058	5602-906-H115-PVE-B-710
S3	LVNT	36840000700	5602-906-H115-PVE-B-018
S4	LVNT OF PVE	6188141010	5602-906-H115-PVE-F-001
S5	COMMON AUX. LOCAL CONTROL BOARD	36840000704	5602-906-H115-PVE-B-008
S6	LAYOUT OF PVE	6188141021	5602-906-H115-PVE-F-001
S7	CW BUSINESSES OF TRANSFORMER, OVERHEAD AT EL. 416.00 & SINK PIT DETAILS	12000019853	5602-906-H115-PVM-F-108
S8		—	5602-906-H115-PVE-B-003

CW/LVNT/CW (750x500)	CUTOUT FOR COOLING WATER SYSTEM FOR TRANSFORMER
LT (500x300)	CUTOUT FOR FIRE EXTINGUISHING SYSTEM
CL/LVNT/LVNT (300x500)	CUTOUT FOR CABLE TRAY
LVNT/LVNT/LVNT (300x500)	CUTOUT FOR HVAC SYSTEM
SP1/SP2 (300x500)	SPARE CUTOUT

CUSTOMER:



रन. टी. पी. सी. लिमिटेड
NTPC LIMITED
(A GOVERNMENT OF INDIA ENTERPRISE)

PROJECT

RAMMAM STAGE - III HYDROELECTRIC PROJECT [3X40MW]



BHARAT HEAVY ELECTRICALS LTD.
BHOPAL

DEPT. CODE	NAME	SIGN	DATE	NO. OF VAR
DRN T.KHAN			3.3.16	
HPE CKD S.SAHU			3.3.16	
415 APPD/R.S.			3.3.16	
SUB-VENDOR DRG. NO.				PO REF
				NO. OF ITEMS

TITLE

STATION LAYOUT PLAN AT EL.416.00 MACHINE HALL

NTPC DRG. NO.

5602-906-H115-PVM-F-009

SUB-VENDOR NAME

WEIGHT (kg)

SCALE 1:200



REVISION NO.

12000019856


SHEET NO. 01 NO. OF SHT. 01

DETAILED DRAWING SHALL BE PREPARED AFTER FINALIZATION
OF HVAC SUPPLIER.

S No	DESCRIPTION	SIZE (mm)	LOCATED HEIGHT (mm)	WEIGHT (Kgs)	TOTAL QTY.	DRG. No.	REMARKS
001	FIELD SUPPRESSION CUBICLE	1150 1260 2295	EL 411.00	1000	1	3	EDN
002	REGULATION CUBICLE	1150 1260 2295	EL 411.00	1000	1	3	EDN
003	THRUSTOR & TRUNNING CUBICLE	2773 1250 2995	EL 411.00	3500	1	3	EDN
004	H.S. LUB UNIT COMMON	2000 800 800	EL 411.00	400	1	1	HCE BPL
005	UNIT AUXILIARY BOARD	5600 1500 2300	EL 411.00	NA	1	3	HPE
006	NG CUBICLE	2200 1600 2035	EL 411.00	NA	1	3	RP
007	AIR PRESSURIZATION EQUIPMENT	3500 1500 2200	EL 411.00	NA	-	2	RP
008	MARSHALLING BOX	1500 200 1200	EL 411.00	100	1	3	HCE BPL
009	NEEDLE CONTROL CABINET	1525 1500 2830	EL 411.00	1700	1	3	HTE BPL
010	HMC FOR GOVERNOR	1125 800 2800	EL 411.00	1700	1	3	HTE BPL
G11	EXCITATION TRANSFORMER	3050 1500 2700	EL 411.00	1000	1	3	EDN
012	DYNAMIC BRAKING CUBICLE	2400 1500 2350	EL 411.00	2000	1	3	EDN
G13	UNIT AUXILIARY TRANSFORMER	3300 1900 2500	EL 411.00	4800	1	3	EDN
G14	NORMAL LIGHTING PANEL (WALL MOUNTED)	650 500 500	EL 411.00	NA	-	1	HTE BPL
G15	EMERGENCY LIGHTING PANEL (WALL MOUNTED)	650 500 500	EL 411.00	NA	-	1	HTE BPL
G16	LP COMPRESSOR	1500 1000 1100	EL 411.00	NA	-	2	HTE BPL
G17	LP AIR RECEIVER	#1000 - 2500	EL 411.00	NA	-	2	HTE BPL
G18	AIR DRYER	750 1340 1400	EL 411.00	NA	-	2	HTE GOV
G19	PRESSURE RECEIVER FOR GENERATOR BRAKE AIR	#350 - 1750	EL 411.00	NA	1	3	HTE BPL
G20	AIR BREAKER & TRANSFORMER	2476 1250 2370	EL 411.00	NA	-	3	EDN
G21	HP FOR GENERATOR STARTER TREATER	600 350 800	EL 411.00	NA	-	3	HPE BPL
G22	HP FOR GENERATOR STARTER TREATER	600 350 800	EL 411.00	NA	-	3	HPE BPL
G23	MCP FOR HP LUB OIL PUMP	600 350 800	EL 411.00	NA	-	1	HPE BPL
004	HVC - HVC MCC - 2 FOR POWER HOUSE	5000 1000 2600	EL 411.00	NA	-	-	PEM



12000019853

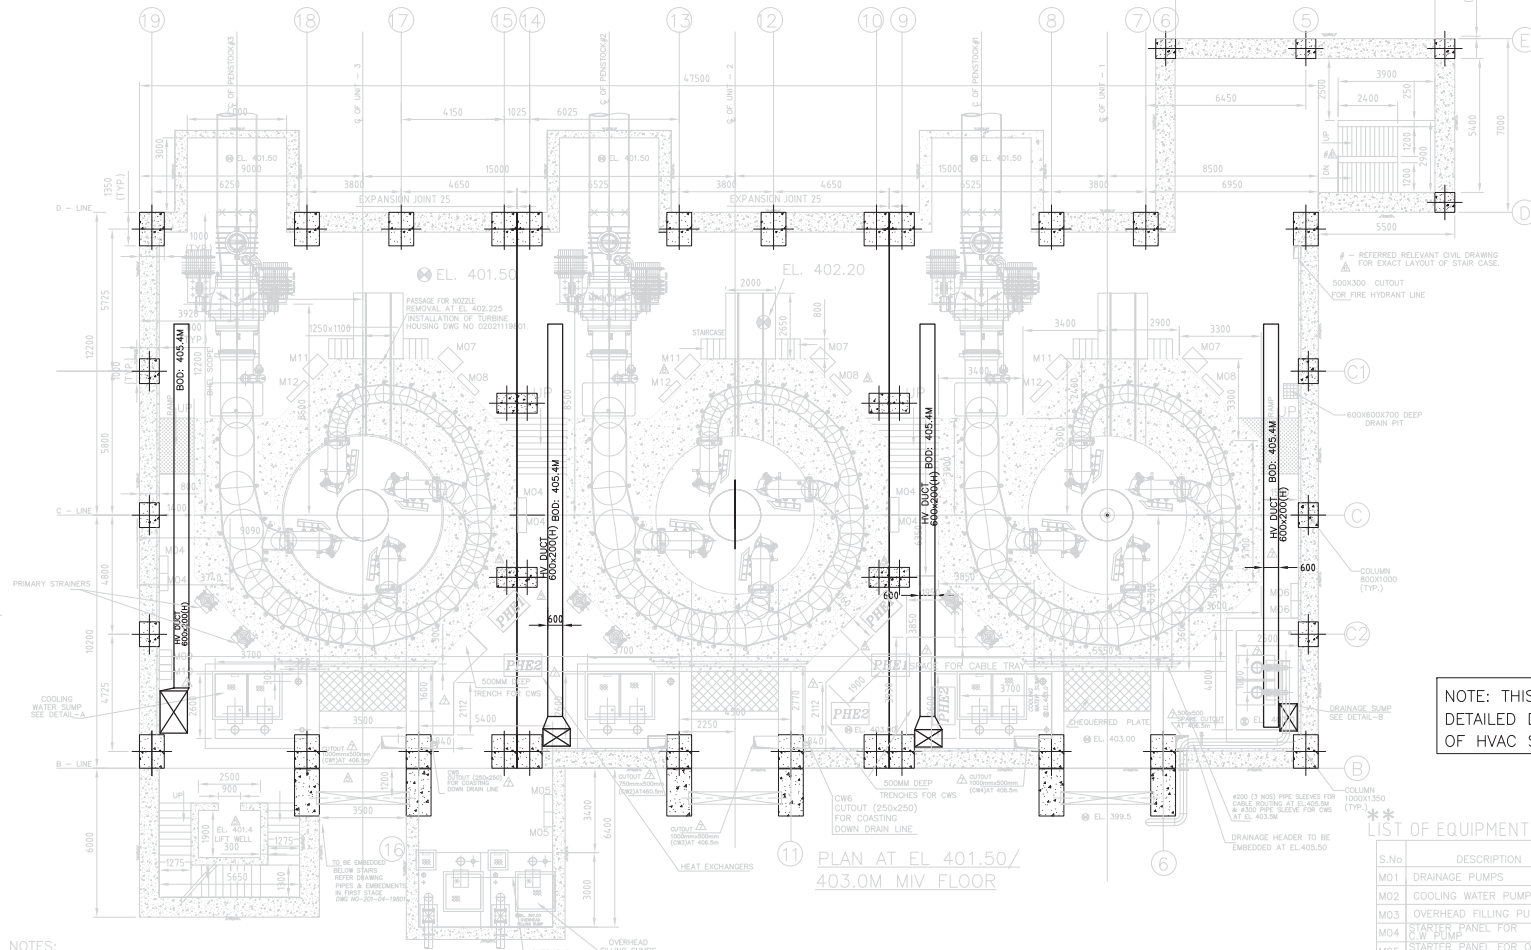

NOTE: THIS VENTILATION DUCT LAYOUT IS INDICATIVE AND DETAILED DRAWING SHALL BE PREPARED AFTER FINALIZATION OF HVAC SUPPLIER.

LIST OF EQUIPMENTS (TENTATIVE) NA - NOT AVAILABLE

S.No	DESCRIPTION	SIZE (mm)	LENGTH	WIDTH	HEIGHT	LOCATED AT	WEIGHT (KGS.)	QTY./TOTAL QTY.	DRG. No.	REMARKS
M01	DRAINAGE PUMPS	-	-	-	-	EL. 396.0	NA	-	2(1M+1S)	HPE BPL
M02	COOLING WATER PUMPS	-	-	-	-	EL. 397.0	NA	2	6(3M+3S)	HTE BPL
M03	OVERHEAD FILLING PUMPS	-	-	-	-	EL. 397.0	NA	-	2(1M+1S)	HTE BPL
M04	STARTER PANEL FOR C.W. PUMP	2X700	350	1275	EL. 403.0	NA	2	6		HPE BPL
M05	STARTER PANEL FOR OVERHEAD TANK FILLING PUMP	2X700	350	1275	EL. 403.0	NA	-	2		HPE BPL
M06	STARTER PANEL FOR DRAINAGE PUMP	2X600	300	1000	EL. 403.0	NA	-	2		HPE BPL
M07	OIL LEAKAGE UNIT FOR MIV	850	600	900	EL. 403.0	NA	1	3		HPE BPL
M08	MCP FOR OIL LEAKAGE UNIT FOR MIV (WALL MOUNTED)	1000	250	800	EL. 403.0	NA	1	3		HPE BPL
M09	NORMAL LIFTING PANEL (WALL MOUNTED)	650	500	500	EL. 403.0	NA	-	1		
M10	MERGENCY LIFTING PANEL (WALL MOUNTED)	650	500	500	EL. 403.0	NA	-	1		
M11	OIL LEAKAGE UNIT FOR TURBINE	850	600	900	EL. 403.0	NA	1	3		HPE BPL
M12	MCP FOR OIL LEAKAGE UNIT FOR TURBINE (WALL MOUNTED)	1000	250	800	EL. 403.0	NA	1	3		HPE BPL

NOTES:

- ALL DIMENSIONS ARE IN MILLIMETRES AND ELEVATIONS ARE IN METRES.
- EQUIPMENT SHOWN AND LISTED ARE TENTATIVE AND SHALL BE FINALISED INCLUDING SIZES DURING DETAILED DESIGN.
- REFER COOLING WATER AND HVAC DRAWINGS FOR COMPLETE DETAILS.
- FOR STAGE WISE CONCRETING AND EMBEDMENT DETAILS REFER TURBINE DRAWINGS OF BHEL.
- FOR MIV, MIV FOUNDATION AND COUNTERWEIGHT PIT DETAILS REFER TURBINE DRAWINGS OF BHEL.
- SIZES OF COLUMNS/BEAMS/SLABS/STAIRS ARE INDICATIVE ONLY. FOR DETAILS REFER CIVIL CONSTRUCTION DRAWINGS.
- ** SHALL BE SHOWN LATER AFTER FINALIZATION OF CW DRG "LAYOUT OF COOLING WATER SYSTEM" (5602-406-H140-PVM-F-004).
- THIS DRAWING IS INTENDED FOR SHOWING LAYOUT & CIVIL REQUIREMENTS OF FLOOR ONLY. FOR CIVIL DETAILS/EMBEDMENTS INSIDE BARREL/HOUSING RESPECTIVE SYSTEM DRAWING AS GIVEN IN TABLE OF REFERENCE DRAWING TO BE FOLLOWED.
- POWERHOUSE FLOOR AND OVERALL DRAIN TO BE SUITABLY DESIGNED BY NTPC CIVIL.

LINKED DRAWINGS :-


SL. No.	DESCRIPTION	BHEL DWG. NO.	(NTPC DWG. NO.)
01	STATION LAYOUT - ELEVATION	12000019851	(5602-906-H115-PVM-F-001)
02	PLAN AT EL. 399.50	12000019852	(5602-906-H115-PVM-F-011)
03	FIRST STAGE PIPES AND EMBEDMENTS DRG.	02010419801	(5602-906-H115-PVM-F-002)
04	EMBEDMENTS & PIPES IN SECOND STAGE	02020819801	(5602-906-H115-PVM-F-004)
05	POWER HOUSE DRAINAGE AND WATERING SUMP CONCRETE	(5602-305(R2)-POC-C-135)	
06	LAYOUT OF COOLING WATER SYSTEM	02292019801	(5602-406-H140-PVM-F-004)

REV.	DATE	ALTERED	TK	REV.	DATE	ALTERED	TK	REV.	DATE	ALTERED	TK	REV.	DATE	ALTERED	TK	REV.	DATE	ALTERED	TK
06	06.11.16	CHECKED	SS	05	10.09.16	CHECKED	SS	04	02.08.16	CHECKED	SS	03	18.06.16	CHECKED	SS	02			
		APPD.	RS			APPD.	RS			APPD.	RS			APPD.	RS				
ZONE	REVISED AS PER NTPC COMMENTS				ZONE	REVISED AS PER NTPC COMMENTS				ZONE	REVISED AS PER NTPC COMMENTS & MOM DATED 02.08.16 TO 04.08.16				ZONE	REVISED AS PER NTPC COMMENTS			

CUSTOMER:		एन टी पी सी NTPC		एन. टी. पी. सी. लिमिटेड NTPC LIMITED (A GOVERNMENT OF INDIA ENTERPRISE)	
PROJECT		RAMMAM STAGE - III HYDROELECTRIC PROJECT [3X40MW]			
DEPT. CODE		DRN T.KHAN		NAME	
HPE CKD		S.SAHU		SIGN	
APPD.R.S				DATE	
SUB-VENDOR DRG. NO.				PO REF	
TITLE		STATION LAYOUT PLAN AT EL.401.50/403.00M		NTPC DRG. NO. 5602-906-H115-PVM-F-003	
SUB-VENDOR NAME		BHARAT HEAVY ELECTRICALS LTD. BHOPAL		BHEL DRG. NO. 12000019853	
WEIGHT (kg)		SCALE 1:100		REV. 07	
SHEET NO. 01		NO. OF SHT. 01		AT SIZE	


FIRST ANGLE PROJECTION

(ALL DIMENSIONS ARE IN mm)

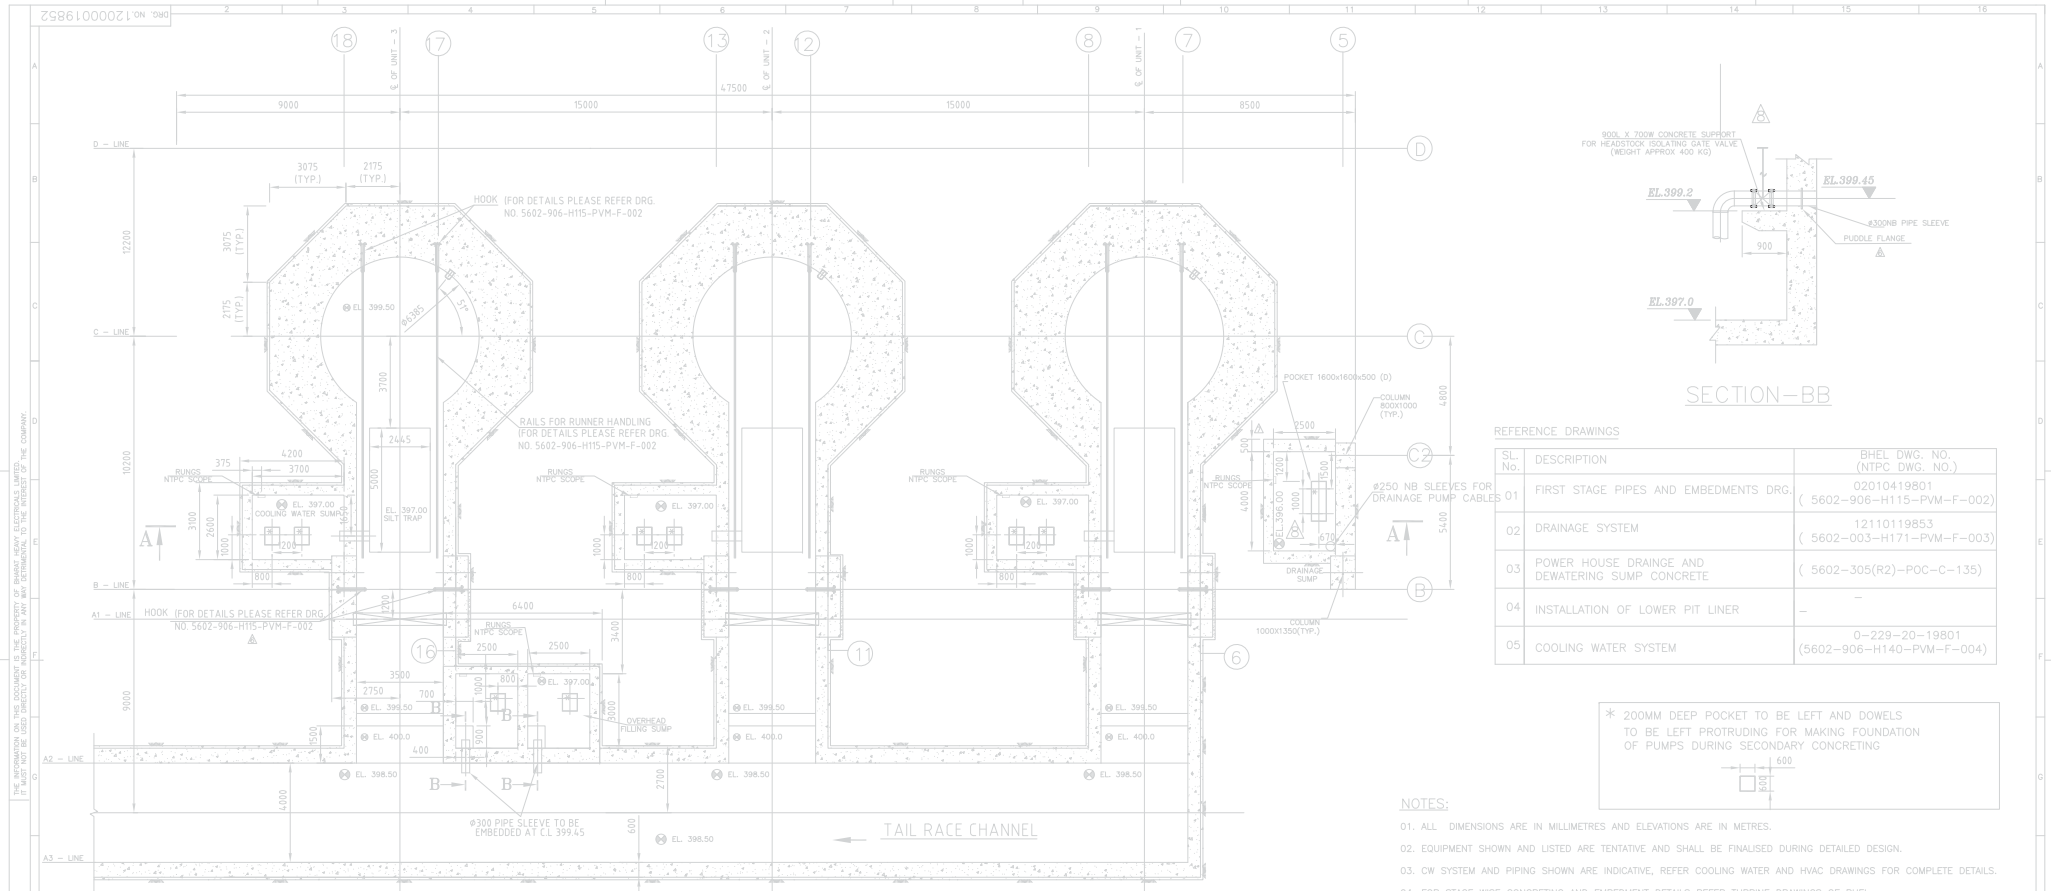

PLAN AT EL 399.50

NO HV DUCT FOR THIS AREA

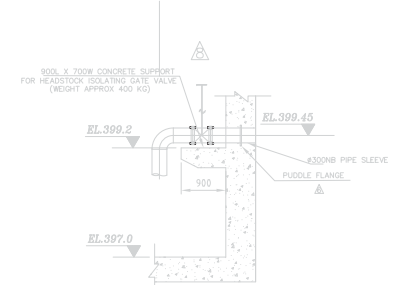

SECTION-BB

REFERENCE DRAWINGS

SL. No.	DESCRIPTION	BHEL DWG. NO. (NTPC DWG. NO.)
01	FIRST STAGE PIPES AND EMBEDMENTS DRG.	02010419801 (5602-906-H115-PVM-F-002)
02	DRAINAGE SYSTEM	12110119853 (5602-003-H171-PVM-F-003)
03	POWER HOUSE DRAINAGE AND DEWATERING SUMP CONCRETE	(5602-305(R2)-POC-C-135)
04	INSTALLATION OF LOWER PIT LINER	-
05	COOLING WATER SYSTEM	0-229-20-19801 (5602-906-H140-PVM-F-004)


* 200MM DEEP POCKET TO BE LEFT AND DOWELS TO BE LEFT PROTRUDING FOR MAKING FOUNDATION OF PUMPS DURING SECONDARY CONCRETING



NOTES:

- ALL DIMENSIONS ARE IN MILLIMETRES AND ELEVATIONS ARE IN METRES.
- EQUIPMENT SHOWN AND LISTED ARE TENTATIVE AND SHALL BE FINALISED DURING DETAILED DESIGN.
- CW SYSTEM AND PIPING SHOWN ARE INDICATIVE, REFER COOLING WATER AND HVAC DRAWINGS FOR COMPLETE DETAILS.
- FOR STAGE WISE CONCRETING AND EMBEDMENT DETAILS REFER TURBINE DRAWINGS OF BHEL.
- FOR MIV, MV FOUNDATION AND COUNTERWEIGHT PIT DETAILS REFER TURBINE DRAWINGS OF BHEL.
- SIZES OF COLUMNS/BEAMS/SLABS/STAIRS ARE INDICATIVE ONLY. FOR DETAILS REFER CIVIL CONSTRUCTION DRAWINGS.
- THIS DRAWING IS INTENDED FOR SHOWING LAYOUT & CIVIL REQUIREMENTS OF FLOOR ONLY. FOR CIVIL DETAILS/EMBEDMENTS INSIDE BARREL/HOUSING RESPECTIVE SYSTEM DRAWING AS GIVEN IN TABLE OF REFERENCE DRAWING TO BE FOLLOWED.
- POWERHOUSE FLOOR AND OVERALL DRAIN TO BE SUITABLY DESIGNED BY NTPC CIVIL.
- REFER RELEVANT HM DRAWING FOR DETAIL OF DRAFT TUBE GATE EMBEDMENT.
- REFER SEPARATE RELEVANT DRAWING FOR FOUNDATION DETAILS.
- FOR EMBEDMENT OF LOWER PIT REFER RESPECTIVE DRAWING OF LOWER PIT LINER.

NOTE: THIS VENTILATION DUCT LAYOUT IS INDICATIVE AND DETAILED DRAWING SHALL BE PREPARED AFTER FINALIZATION OF HVAC SUPPLIER.

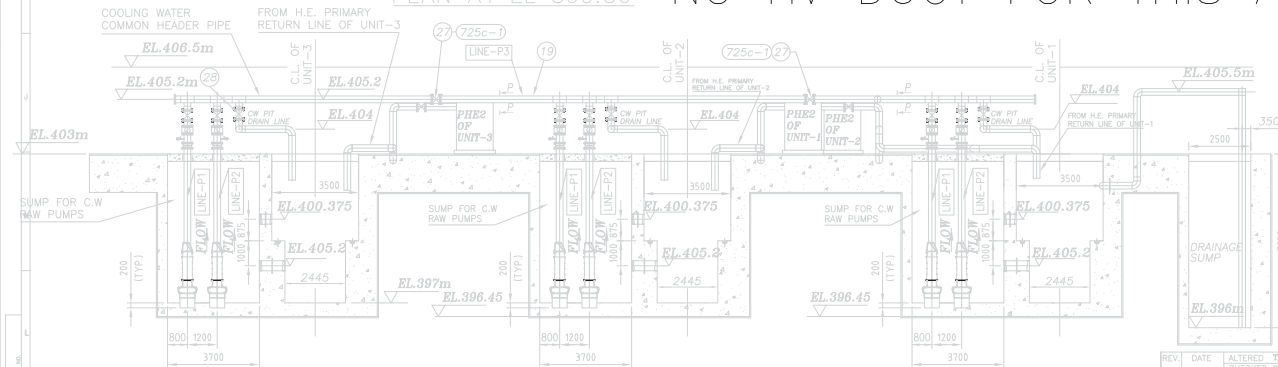

SECTION-AA

REV.	DATE	ALTERED BY	CHKD.	APPD.	REV.	DATE	ALTERED BY	CHKD.	APPD.	REV.	DATE	ALTERED BY	CHKD.	APPD.	REV.	DATE	ALTERED BY	CHKD.	APPD.	REV.	DATE	ALTERED BY	CHKD.	APPD.
06	10.09.16	CHECKED	SS	BS	05	02.08.16	CHECKED	SS	BS	04	18.06.16	CHECKED	SS	BS	03	18.06.16	CHECKED	SS	BS	02	28.02.16	CHECKED	SS	BS
ZONE 1					ZONE 2					ZONE 3					ZONE 4					ZONE 5				
REVISED AS PER NTPC COMMENTS					REVISED AS PER NTPC COMMENTS & MOM DATED 02.08.16 TO 04.08.16					REVISED AS PER NTPC COMMENTS					REVISED AS PER NTPC COMMENTS					REVISED AS PER NTPC COMMENTS				

CUSTOMER:		एन टी सी लिमिटेड NTPC		स. टी. पी. सी. लिमिटेड NTPC LIMITED (A GOVERNMENT OF INDIA ENTERPRISE)	
PROJECT		RAMMAM STAGE - III HYDROELECTRIC PROJECT [3X40MW]			
DEPT. CODE		Bharat Heavy Electricals Ltd. Bhopal		NAME: S. KHAN SIGN: CKD S. SAHU DATE: 20.09.15 APPD: R.S. DATE: 20.09.15	
TITLE		STATION LAYOUT PLAN AT EL.399.50M			
SUB-VENDOR NAME		WEIGHT (kg)		SCALE 1:100	
REV. DATE		01 28.02.16		BHEL DRG. NO. 5602-906-H115-PVM-F-011	
SHEET NO.		01		NO. OF SHT. 08	